

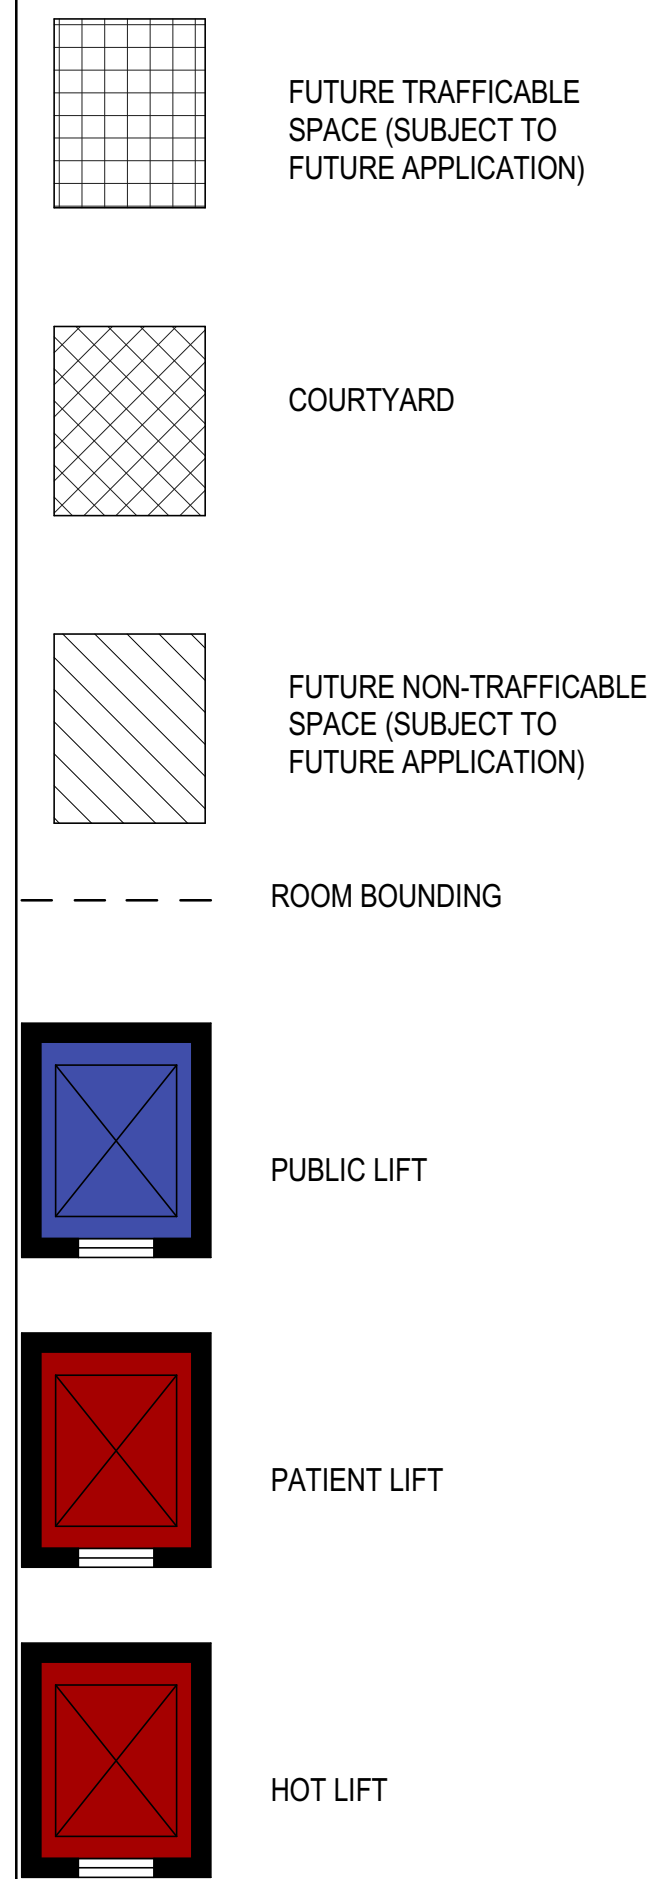
 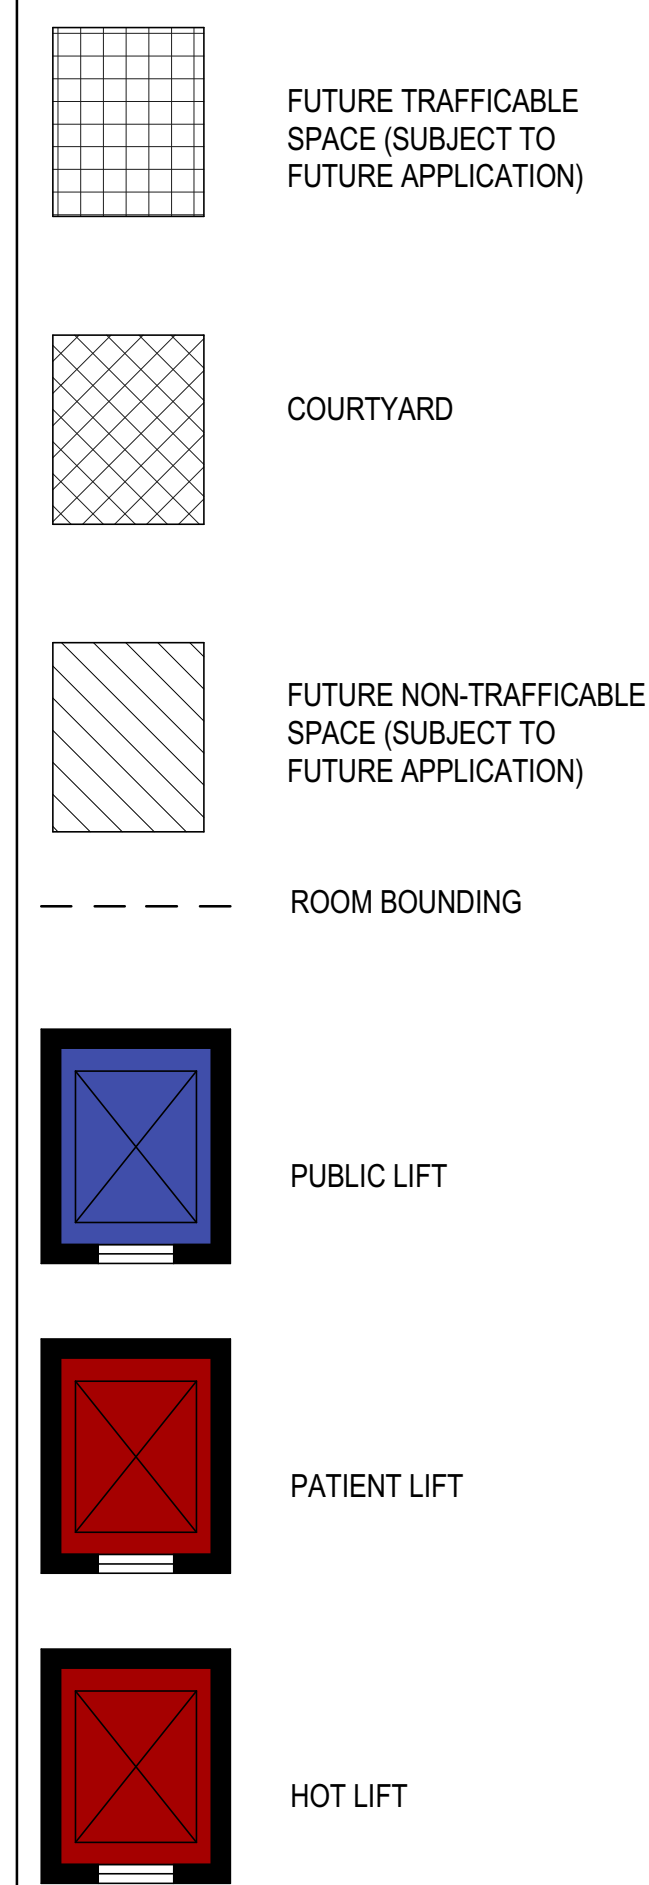
 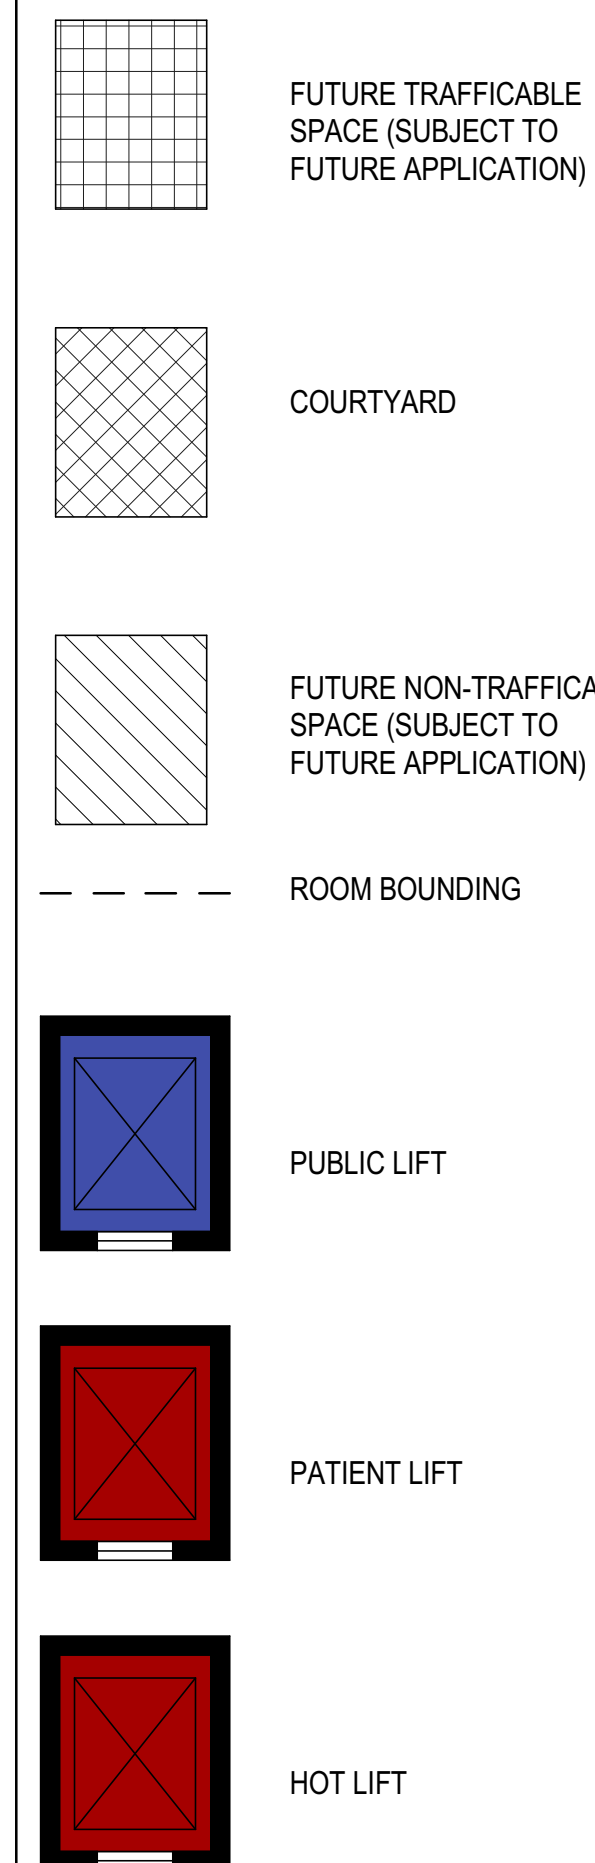
 



[illegible]




LV 01	+24.800
-------	---------




	
Telephone: +61 2 8337 7200 Facsimile: +61 2 8337 7299 www.bvn.com.au	
NSW ARCHITECTS REGISTRATION BOARD/ NOMINATED ARCHITECTS	
401 ADELAIDE CIRCLE 2ND FLOOR 7105 LINDFIELD NSW 1585 TEL: 02 9363 7400 FAX: 02 9363 7401 WWW.BVN.COM.AU	
INTELLECTUAL PROPERTY COPYRIGHT IN AN ARCHITECTURAL PLAN, LIMITED, UNLESS OTHERWISE AGREED IN WRITING, IS THE PROPERTY OF BVN. THE DOCUMENT IS SUBJECT TO PAYMENT IN FULL OF ALL BILLS CHARGED AND IS NOT TO BE REPRODUCED OR USED FOR ANY OTHER PURPOSE AND PROJECT FOR WHICH IT HAS BEEN PREPARED AND IS NOT TO BE REPRODUCED OR USED FOR ANY OTHER PURPOSE WITHOUT THE WRITTEN PERMISSION OF BVN. THE DOCUMENT IS NOT TO BE REPRODUCED OR USED FOR ANY OTHER PURPOSE WITHOUT THE WRITTEN PERMISSION OF BVN. THE DOCUMENT IS NOT TO BE REPRODUCED OR USED FOR ANY OTHER PURPOSE WITHOUT THE WRITTEN PERMISSION OF BVN. THE DOCUMENT IS NOT TO BE REPRODUCED OR USED FOR ANY OTHER PURPOSE WITHOUT THE WRITTEN PERMISSION OF BVN.	
NOTICE CONTRACTOR TO CHECK AND VERIFY ALL DIMENSIONS ON SITE PRIOR TO COMMENCEMENT OF WORK OR PREPARATION OF SHOP DRAWINGS DO NOT SCALE THIS DRAWING.	
ISSUE DATE DESCRIPTION 4 1/10/19 SCHEMATIC DESIGN 3 5 2/10/19 FOR INFORMATION 6 10/11/19 SB DRAFT 1 7 15/11/19 FOR INFORMATION - GPS 8 10/11/19 SB DRAFT 2 9 12/11/19 FOR INFORMATION - GAV 10 13/11/19 FOR INFORMATION 11 17/11/19 FOR INFORMATION 12 11/11/19 D01 ISSUE FOR TENDER 2030 13 16/11/19 D02 ISSUE 14 19/11/19 SS1 ISSUE 15 13/11/19 SS2 ISSUE 16 25/11/19 SS3 ISSUE	
CLIENT  Health Infrastructure MANAGING CONTRACTOR MULTIPLEX Build to outperform.	
PROJECT MANAGER CBRE 01 9333 3333  STRUCTURE / FACADE / CIVIL TTW 01 9439 7288 MANAGERIAL / MEDICAL GASES / ESD EMF Griffiths 01 9283 8445  ELECTRICAL / DOMESTIC / VERTICAL / TRANSPORT JHA 01 9437 1000  HYDRAULIC / FIRE Werner Smith & Partners 01 9299 1312  PCA / BDA / BDA / I Group DLA 01 8090 1493  PGE ENGINEERING PGA  PROJECT NEW MATTLAND HOSPITAL CORNER OF METFORD RD AND FIELDSEND ST. METFORD, NSW 2333 BIM PROJECT NUMBER 1801060.001 DRAWING KEY  TRUE NORTH 1:200 @A0 DO NOT SCALE 0 1000 4000 8000 1:200 DESIGNED BY: Designer CHECKED BY: Checker DRAWN BY: Designer APPROVED BY: Approver DESIGN DEVELOPMENT DRAWING HOSPITAL - GENERAL ARRANGEMENT PLAN - LEVEL 02 DRAWING NUMBER B1N-ARR- 11B-200-100 ISSUE 16	

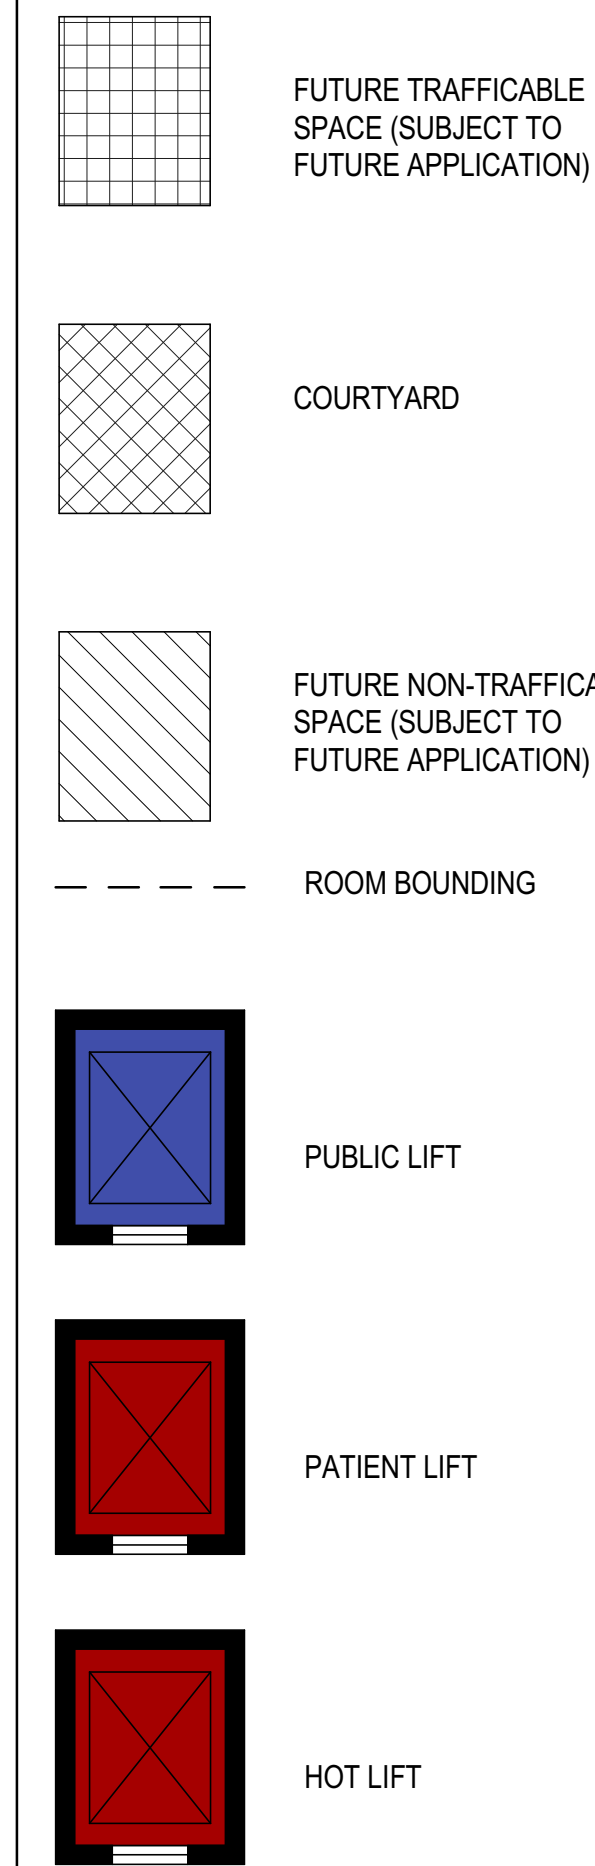


DRAWING NUMBER	ISSUE
BVN-ARH- 11B-300-100	15

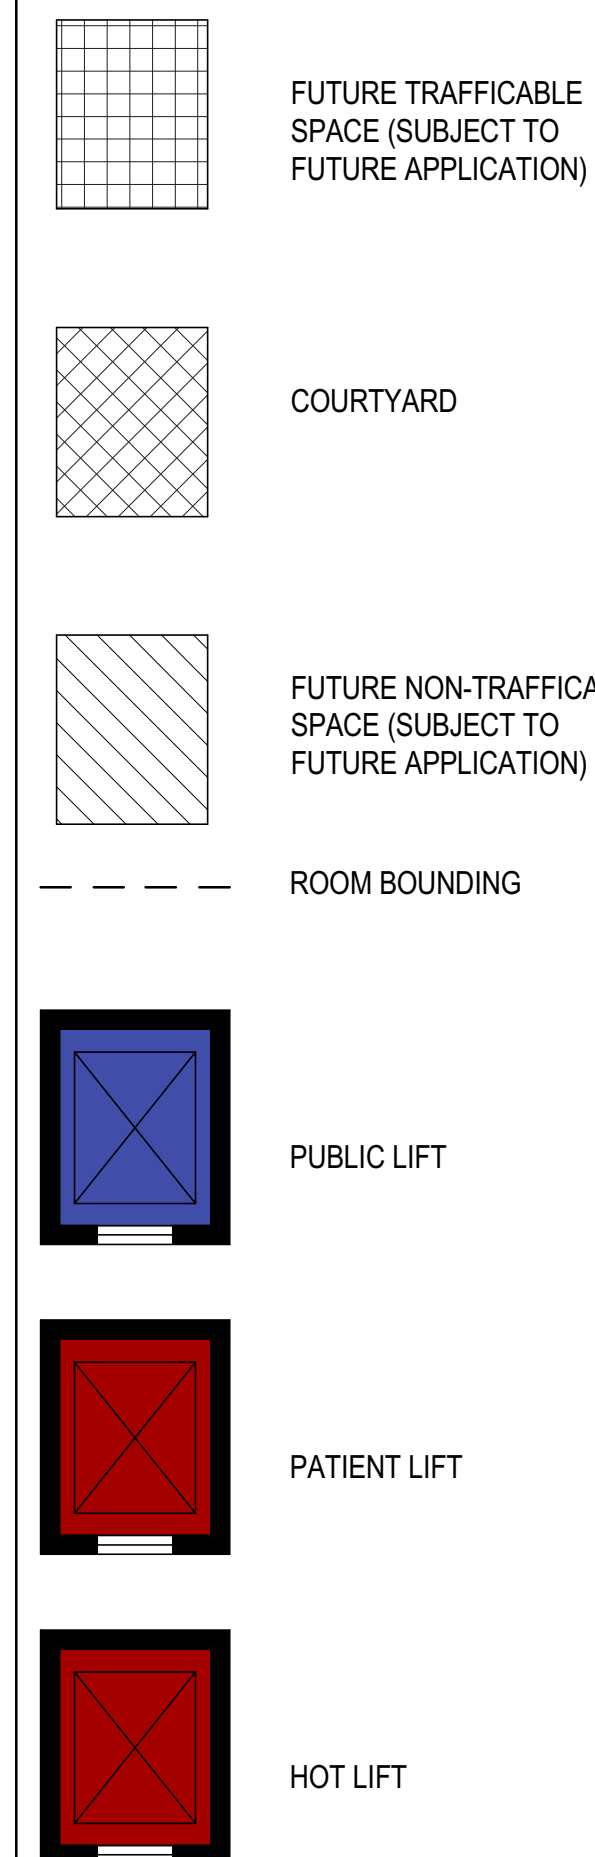


LV 04 +22.400

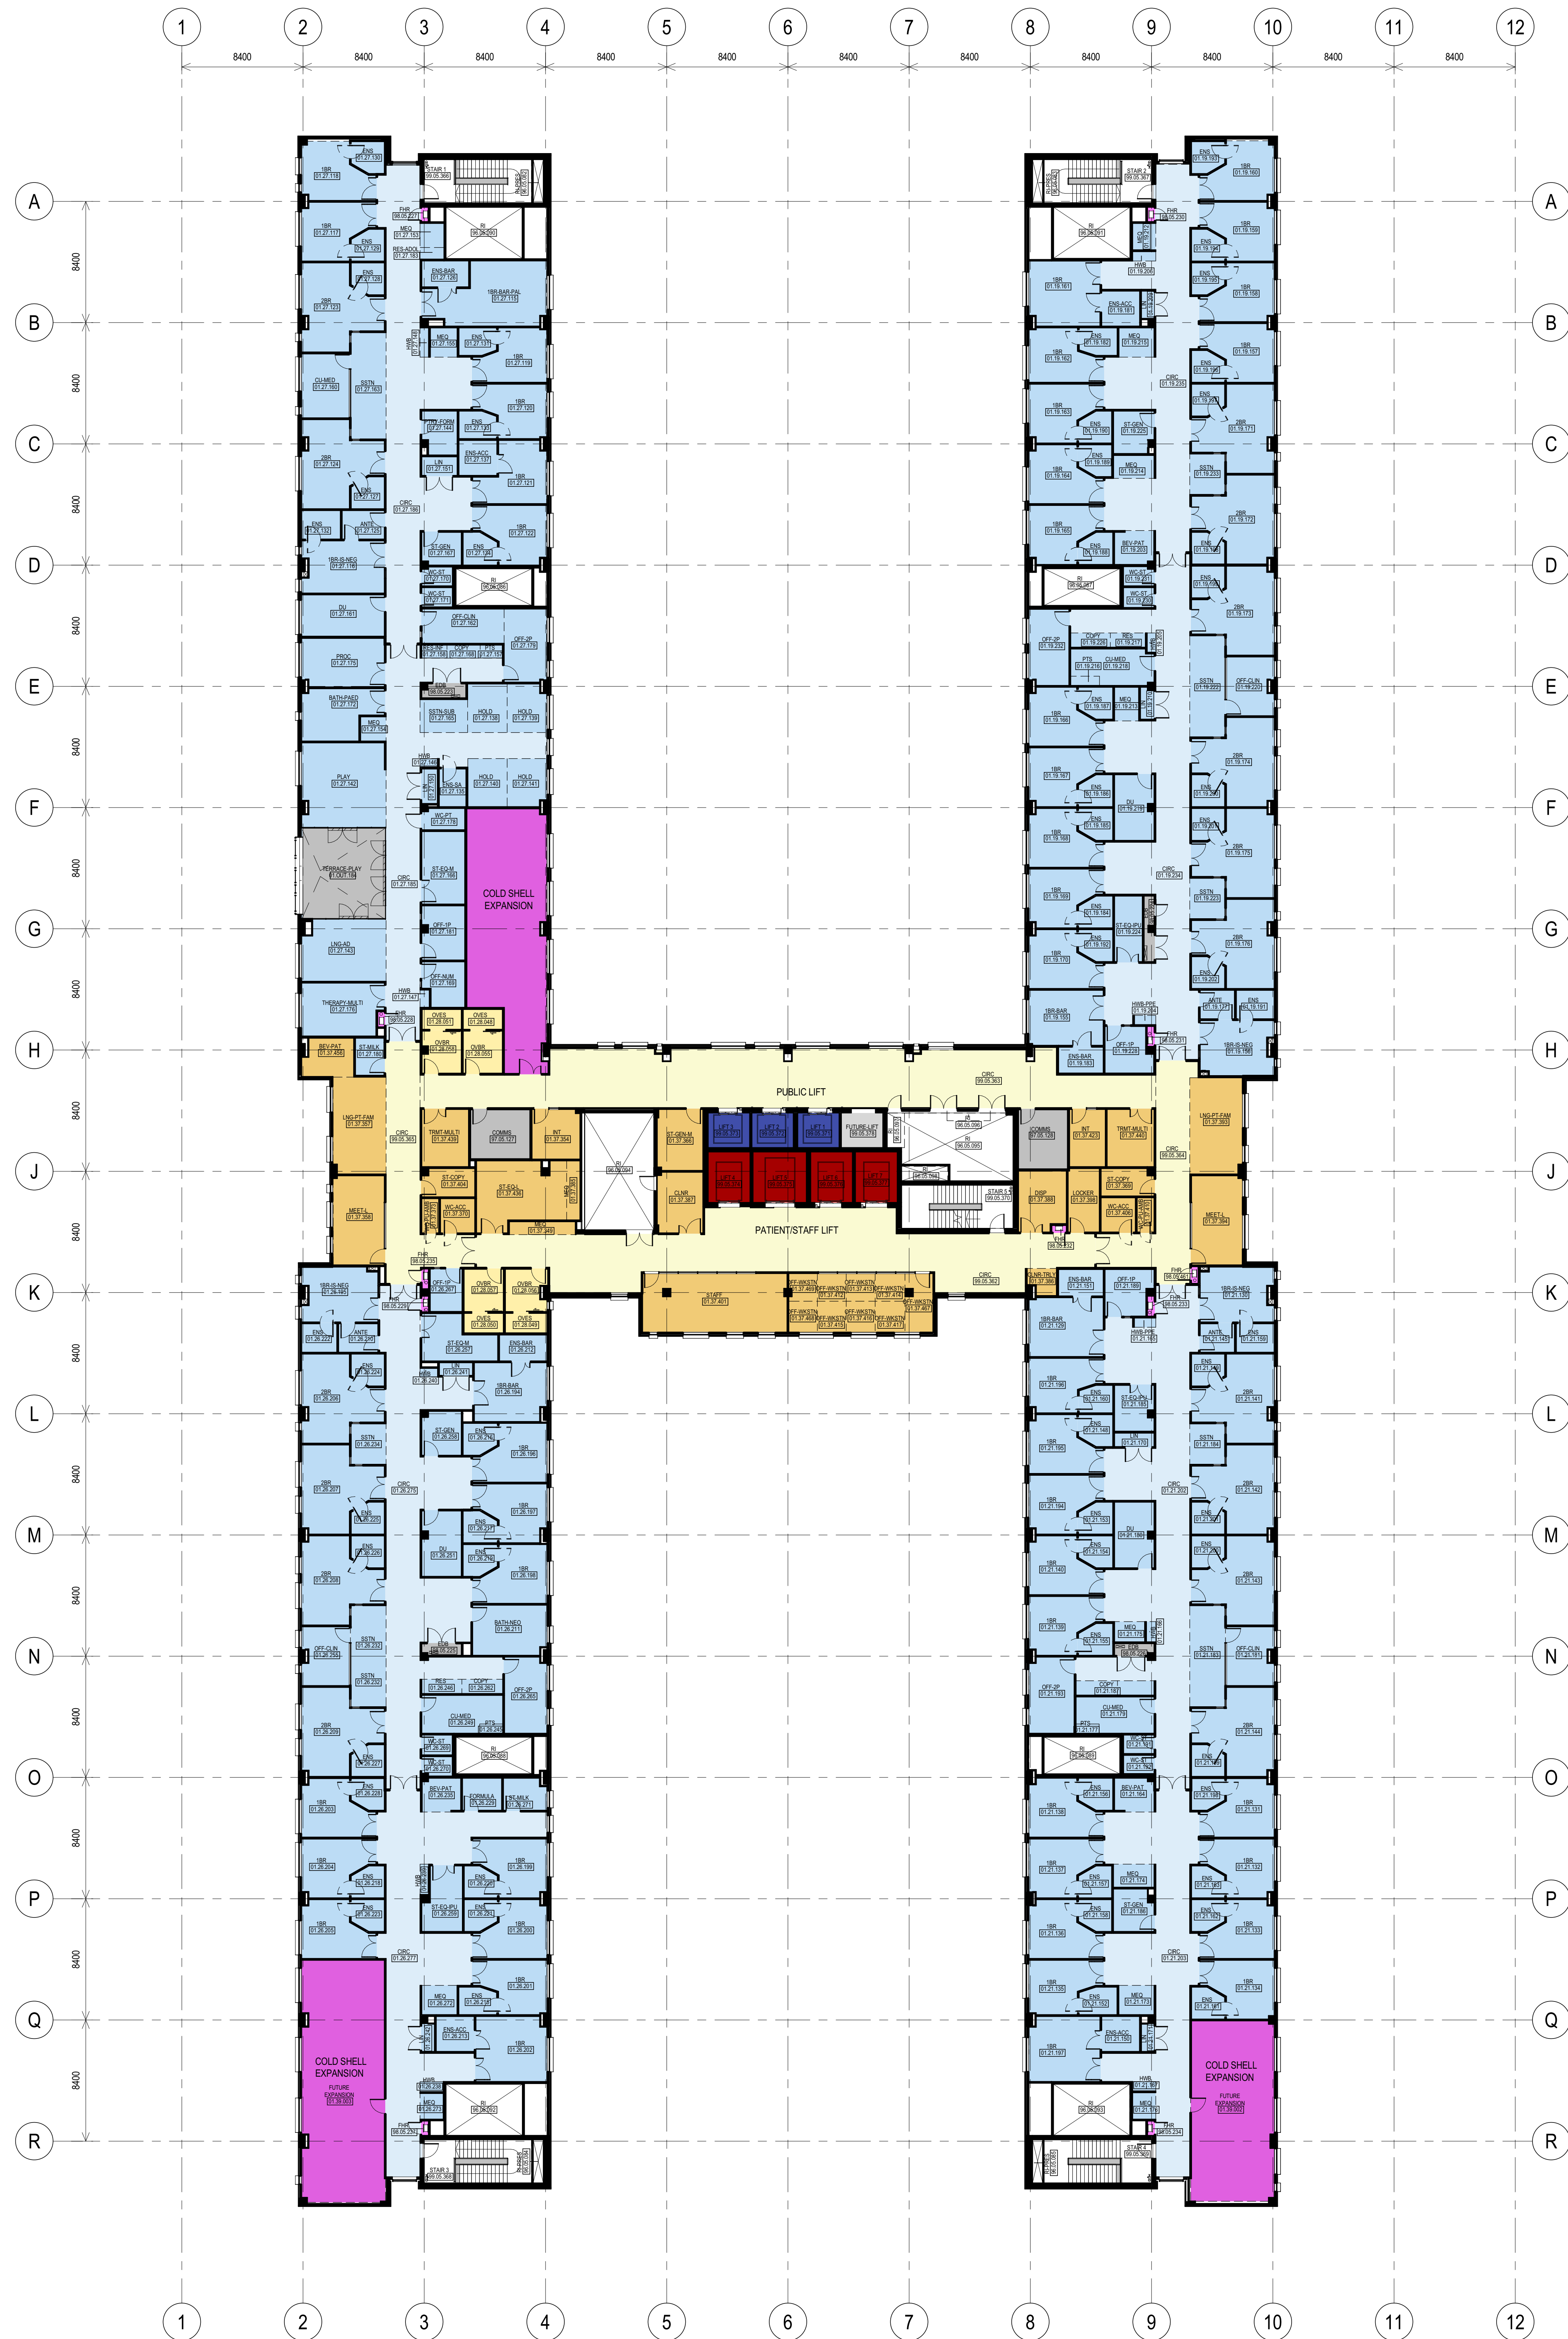


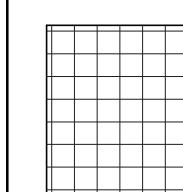


FUTURE TRAFFICABLE SPACE (SUBJECT TO FUTURE APPLICATION)

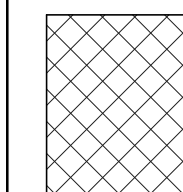


COURTYARD

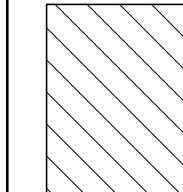

 
FUTURE NON-TRAFFICABLE SPACE (SUBJECT TO FUTURE APPLICATION)




ROOM BOUNDING

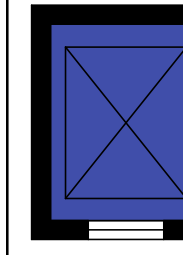

PUBLIC LIFT

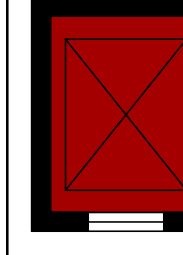

PATIENT LIFT

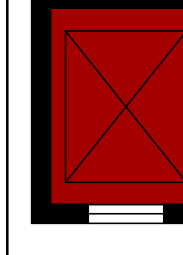

HOT LIFT

LV 05 +41.900



Telephone +61 2 8391 7300
Facsimile +61 2 8391 7309
www.bvn.com.au

NEW ARCHITECTS
REGISTRATION BOARD
REGISTERED ARCHITECTS

8801 ADELE CAYAN
8802 BACHMAN TROSKOSKY
730 ALAN SMITH
730 MATTHEW BLAIR
730 PHILIP KOSKOVICH
4801 JAMES GROSS

INTELLECTUAL PROPERTY
COPYRIGHT BVA ARCHITECTURE PTY LIMITED UNLESS OTHERWISE AGREED IN WRITING. ALL RIGHTS TO THIS DOCUMENT ARE SUBJECT TO PAYMENT IN FULL OF ALL FEES. CHANGES TO THIS DOCUMENT MAY NOT BE MADE FOR THE EXPRESS PURPOSE AND PROJECT FOR WHICH IT HAS BEEN CREATED AND ANY UNAUTHORIZED USE OF THIS DOCUMENT BY ANYONE IS PROHIBITED. THE USER RELEASES AND AGREES TO HOLD BVA ARCHITECTURE PTY LIMITED HARMLESS FROM AND AGAINST ALL LOSS OR DAMAGE.

NOTE
CONTRACTOR TO CHECK AND VERIFY ALL DIMENSIONS ON SITE PRIOR TO COMMENCEMENT OF WORK OR PREPARATION OF SHOP DRAWINGS. DO NOT SCALE THIS DRAWING.

ISSUE	DATE	DESCRIPTION
4	11/03/19	SCHEMATIC DESIGN 3
5	22/03/19	FOR INFORMATION
6	01/04/19	ISS DRAFT ISSUE
7	05/04/19	FOR INFORMATION - GAS
8	10/04/19	ISS DRAFT ISSUE
9	12/04/19	FOR INFORMATION - GAS
10	13/05/19	MAJOR ISSUE - FOR INFORMATION
11	07/06/19	FOR INFORMATION
12	21/07/19	CONTRIBUTOR FOR TENDER
13	16/08/19	DOX ISSUE
14	06/09/19	ISS 2 ISSUE
15	25/09/19	ISS 2 ISSUE

CLIENT

HEALTH INFRASTRUCTURE
MANAGING CONTRACTOR
MULTIPLEX
Built to outperform.

PROJECT MANAGER
CBRE
(02) 9333 3333

CBRE
STRUCTURE / FACADE / CIVIL
TTW
(02) 9439 7288
MECHANICAL / MEDICAL GASES / ESD
EMF Griffiths
(02) 9283 8445
ELECTRICAL / CORES / VERTICAL TRANSPORT
JHA
(02) 9437 1000
HYDRAULIC / FIRE
Warren Smith & Partners
(02) 9299 1312
PCA / BCA / DDA / Group DLA
(02) 8090 1493
FIRE ENGINEERING
PGA

PROJECT
NEW MAITLAND HOSPITAL
CORNER OF METFORD RD AND
FIELDSEND ST,
METFORD, NSW 2323
BVA PROJECT NUMBER
S1806011.000
DRAWING KEY

TRUE NORTH
PROJECT NORTH

SCALE
1:200 @A0 DO NOT SCALE
0 1000 4000 8000
1:200


DRAWN BY: CHECKED BY:
STATUS: APPROVED BY:


DESIGN DEVELOPMENT
DRAWING

HOSPITAL - GENERAL
ARRANGEMENT PLAN -
LEVEL 05







DRAWING NUMBER	ISSUE
BVN-ARH-11B-500-100	15

 C:\REVIT\LOCAL2019\BVA\ARH\100M-A00-017\Level 05_mgaasdaa.rvt 25/09/2019 6:12:28 PM



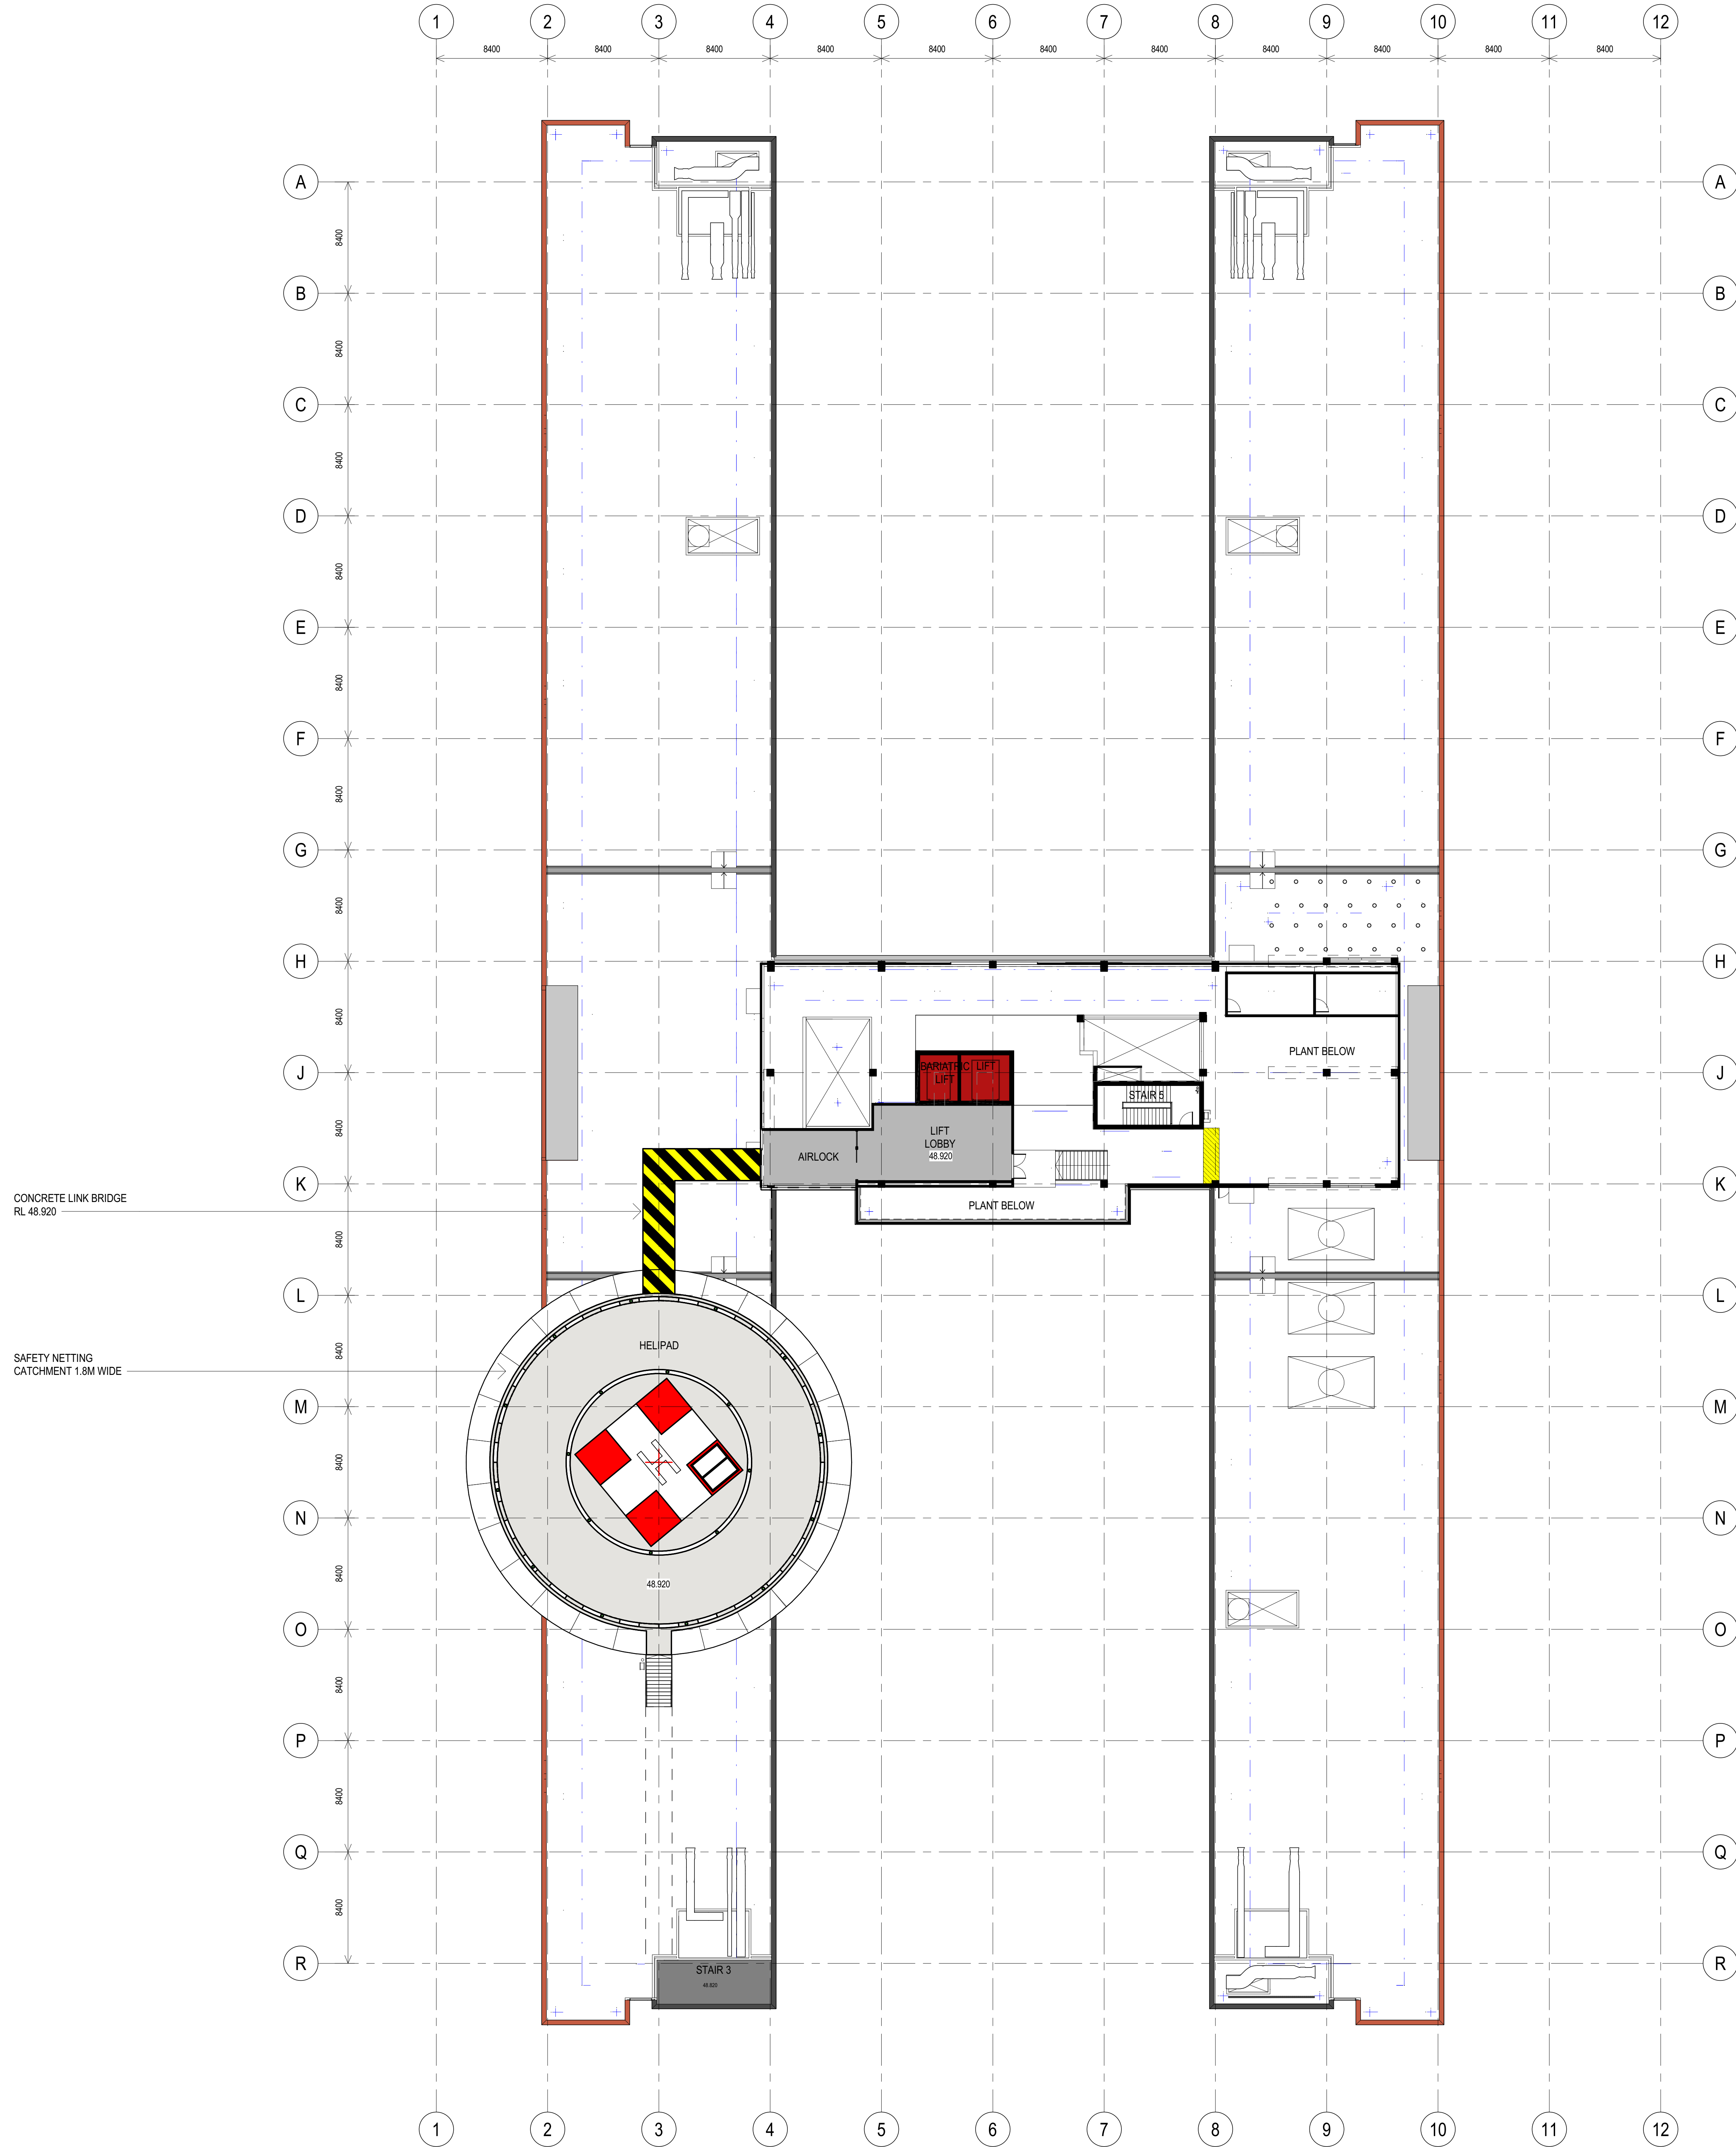

+RL 48.920 L6
MEZZANINE

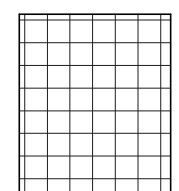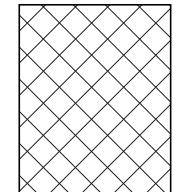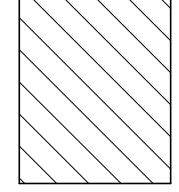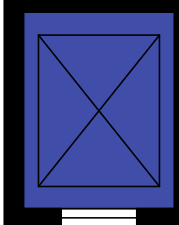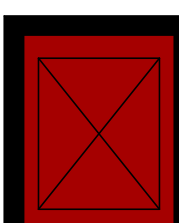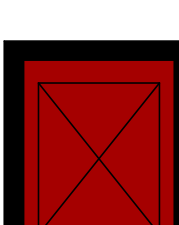-  FUTURE TRAFFICABLE SPACE (SUBJECT TO FUTURE APPLICATION)
-  COURTYARD
-  FUTURE NON-TRAFFICABLE SPACE (SUBJECT TO FUTURE APPLICATION)
-  ROOM BOUNDING
-  PUBLIC LIFT
-  PATIENT LIFT
-  HOT LIFT



Telephone: +61 2 8307 7300
Facsimile: +61 2 8307 7328
www.bvn.com.au

NSW ARCHITECTS
REGISTRATION BOARD
NOMINATED ARCHITECTS

0001 ABIE CAULIN
0002 BENJAMIN HODGSON
0003 ALAN MATHIAS
0004 MATTHEW BLAIR
0005 PHILIP KOSMINSKI
0006 JAMES DODGE

INTELLECTUAL PROPERTY
COPYRIGHT BVA ARCHITECTURE PTY LIMITED UNLESS OTHERWISE AGREED IN WRITING. ALL RIGHTS TO THIS DOCUMENT ARE SUBJECT TO PAYMENT IN FULL OF ALL BILLS. CHANGES TO THIS DOCUMENT MAY ONLY BE MADE FOR THE EXPRESS PURPOSE AND PROJECT FOR WHICH IT HAS BEEN CREATED AND NO OTHER. ANY REUSE OR REPRODUCTION OF THIS DOCUMENT MAY NOT BE OTHERWISE USED, OR COPIED, ANY REPRODUCTION OF THIS DOCUMENT IS AT THE USER'S SOLE RISK AND WITHOUT LIMITING BILLS, RIGHTS THE USER RELEASES AND HOLDING HIMSELF FROM AND AGAINST ALL LOSS SO ARISING.

NOTE
CONTRACTOR TO CHECK AND VERIFY ALL DIMENSIONS ON SITE PRIOR TO COMMENCEMENT OF WORK OR PREPARATION OF SHOP DRAWINGS. DO NOT SCALE THIS DRAWING.

ISSUE	DATE	DESCRIPTION
4	11/02/19	SCHEMATIC DESIGN 3
5	22/03/19	FOR INFORMATION
6	01/04/19	SSI DRAFT ISSUE
7	10/04/19	SSI DRAFT ISSUE
8	12/04/19	FOR INFORMATION - CIVIL
9	13/05/19	MODEL ISSUE - FOR INFORMATION
10	07/06/19	FOR INFORMATION
11	01/07/19	DO-TO ISSUE FOR TENDER
12	16/08/19	DO-TO ISSUE
13	12/09/19	SSI ISSUE 2
14	25/09/19	SSI ISSUE 2

CLIENT
 **NSW Health**
Infrastructure
HEALTH INFRASTRUCTURE
MANAGING CONTRACTOR
MULTIPLEX
Built to outperform.

PROJECT MANAGER
CBRE
(02) 9333 3333

CBRE
STRUCTURE / FACADE / CIVIL
TTW
(02) 9439 7288

MECHANICAL / MEDICAL GASES / ESD
EMF Griffiths
(02) 9263 8445 


ELECTRICAL / COMMS / VERTICAL TRANSPORT
JHA
(02) 9437 1000 

 
 
HYDRAULIC / FIRE
Warren Smith & Partners
(02) 9299 1312 

PCA / BCA / DDA / Group DLA
(02) 8090 1493 

FIRE ENGINEERING
PGA 

PROJECT
NEW MAITLAND HOSPITAL
CORNER OF METFORD RD AND
FIELDBEND ST,
METFORD, NSW 2323
BVA PROJECT NUMBER
S1806011.000
DRAWING KEY

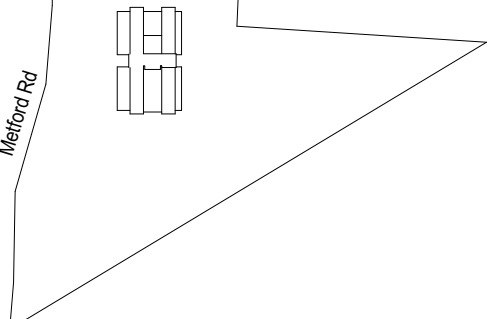

TRUE NORTH  PROJECT NORTH 


SCALE
1:200 @A0 DO NOT SCALE
0 1000 4000 8000
1:200

DRAWN BY: _____ CHECKED BY: _____
STATUS: _____ APPROVED BY: _____

DESIGN DEVELOPMENT
DRAWING

HOSPITAL - GENERAL
ARRANGEMENT PLAN -
LEVEL 06 MEZZANINE

DRAWING NUMBER	ISSUE
BVN-ARH-11B-600-102	14

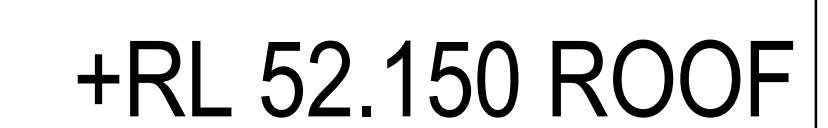

ISSUE	DATE	DESCRIPTION
1	10/12/18	FOR INFORMATION
2	17/12/18	ISSUE
3	08/03/19	FOR INFORMATION
4	08/04/19	FOR INFORMATION
5	13/05/19	ISSUE
6	01/07/19	ISSUE
7	16/08/19	ISSUE
8	21/08/19	ISSUE
9	06/09/19	ISSUE
10	17/09/19	ISSUE
11	18/09/19	ISSUE

CLIENT

NSW Health
Infrastructure

HEALTH INFRASTRUCTURE

MANAGING CONTRACTOR
MULTIPLEX
Built to outperform.

PROJECT MANAGER
CBRE
(02) 9333 3333

CBRE

STRUCTURE / FACADE / CIVIL

TTW
(02) 9439 7288

MECHANICAL / MEDICAL GASES / ESD

EMF Griffiths
(02) 9283 8445

ELECTRICAL / COINS / VERTICAL TRANSPORT

JHA
(02) 9437 1000

HYDRAULIC / FIRE

Warren Smith & Partners
(02) 9299 1312

PCA / BCA / DDA /

Group DLA
(02) 8090 1493

FIRE ENGINEERING

PGA

PROJECT

NEW MAITLAND HOSPITAL

CORNER OF METFORD RD AND


FIELDBEND ST,

METFORD, NSW 2323

BVN PROJECT NUMBER

S1806011.000

DRAWING KEY

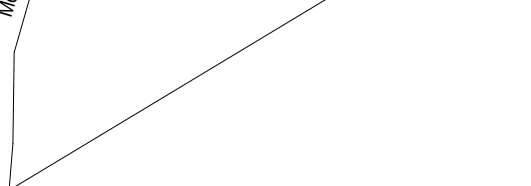

TRUE NORTH

PROJECT NORTH

SCALE

1:200 @A0 DO NOT SCALE

0 1000 4000 8000

1:200

DRAWN BY

CHECKED BY

DESIGNED BY

APPROVED BY

DESIGN DEVELOPMENT

DRAWING

HOSPITAL - ELEVATIONS

NORTH AND SOUTH

DRAWING NUMBER


BVN-ARH-11C-A00-102

ISSUE

11




1 NORTH ELEVATION
1:200

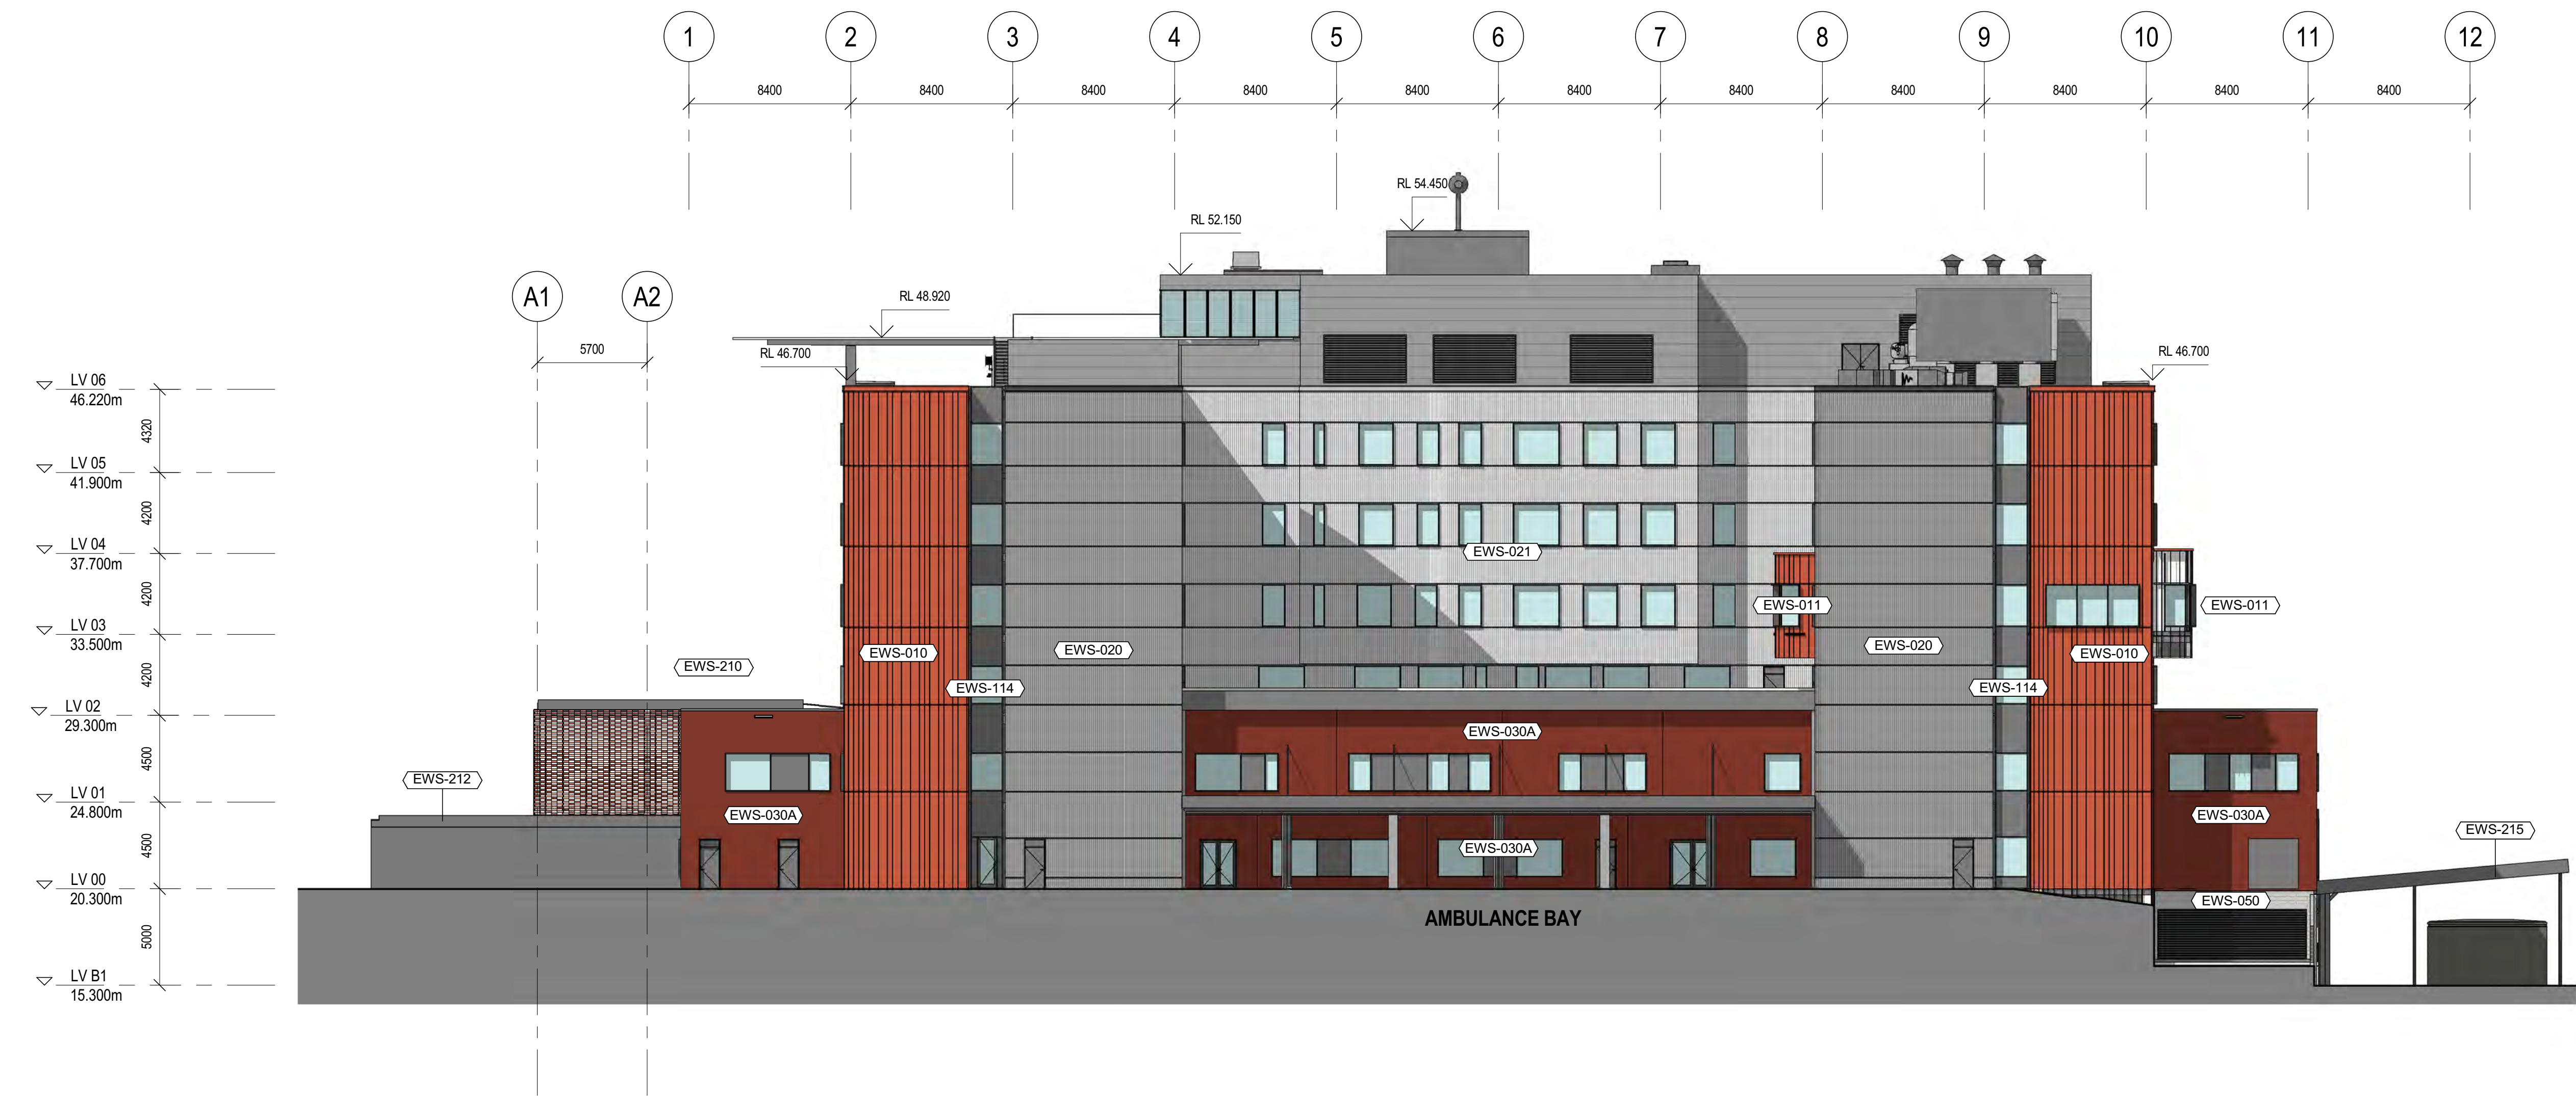


2 SOUTH ELEVATION
1:200




ISSUE	DATE	DESCRIPTION
1	10/12/18	FOR INFORMATION
2	17/12/18	ISSUE 1
3	08/01/19	FOR INFORMATION
4	08/04/19	FOR INFORMATION
5	13/05/19	ISSUE 2
6	01/07/19	ISSUE 3
7	18/08/19	ISSUE 4
8	21/08/19	ISSUE 5
9	06/09/19	ISSUE 6
10	17/09/19	ISSUE 7
11	18/09/19	ISSUE 8

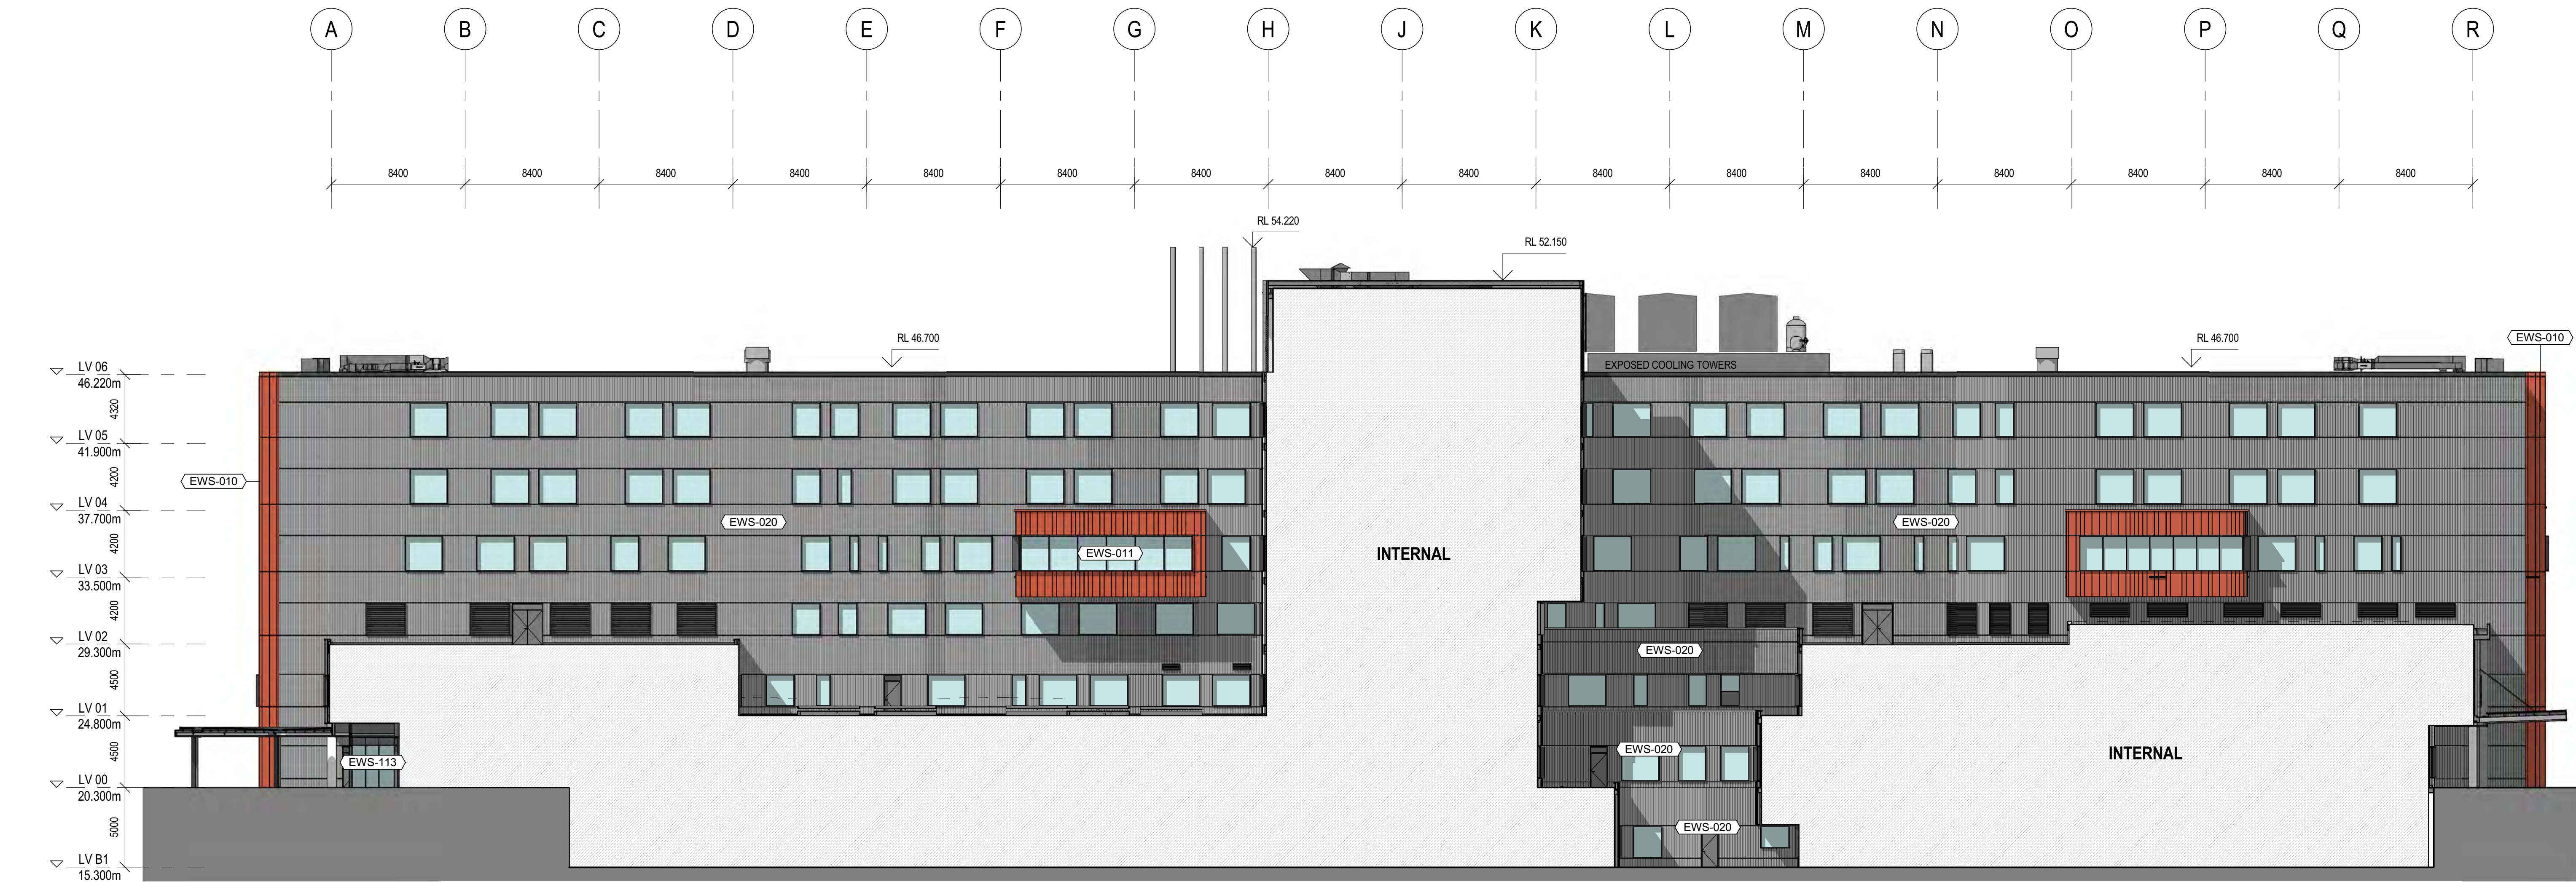


1 EAST PART ELEVATION
1:200

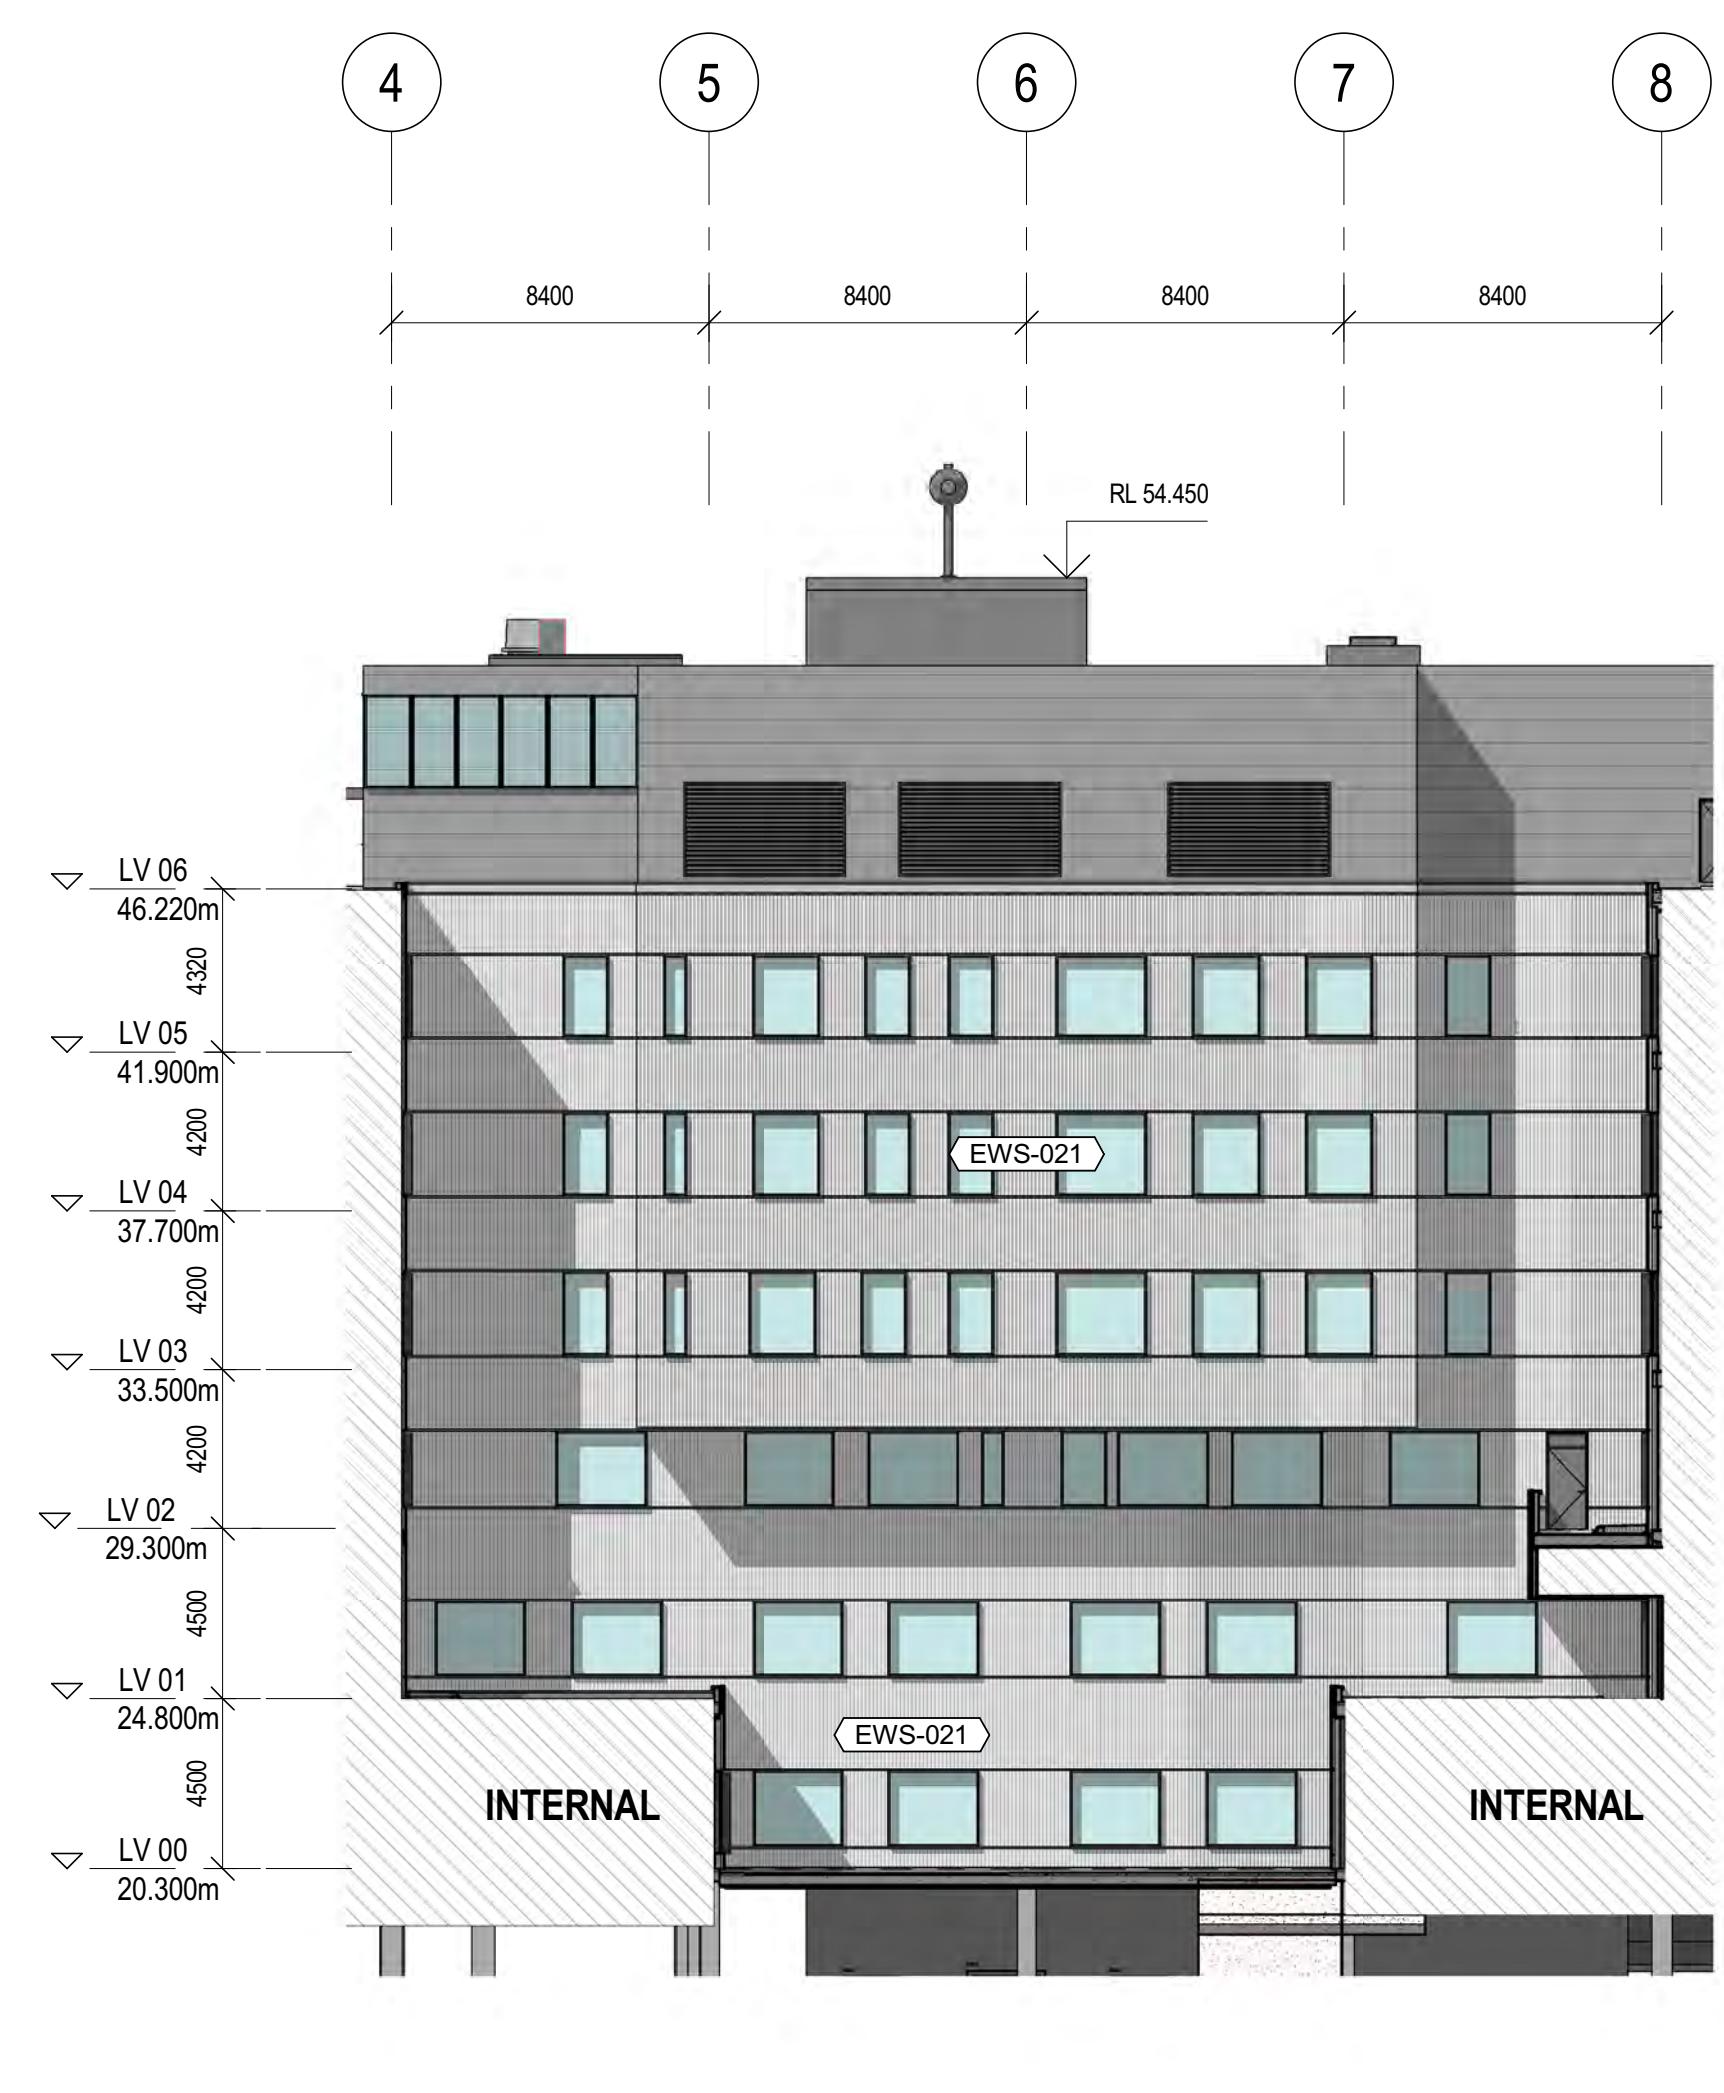


5 PART ELEVATION ZONE 40 NORTH
1:200

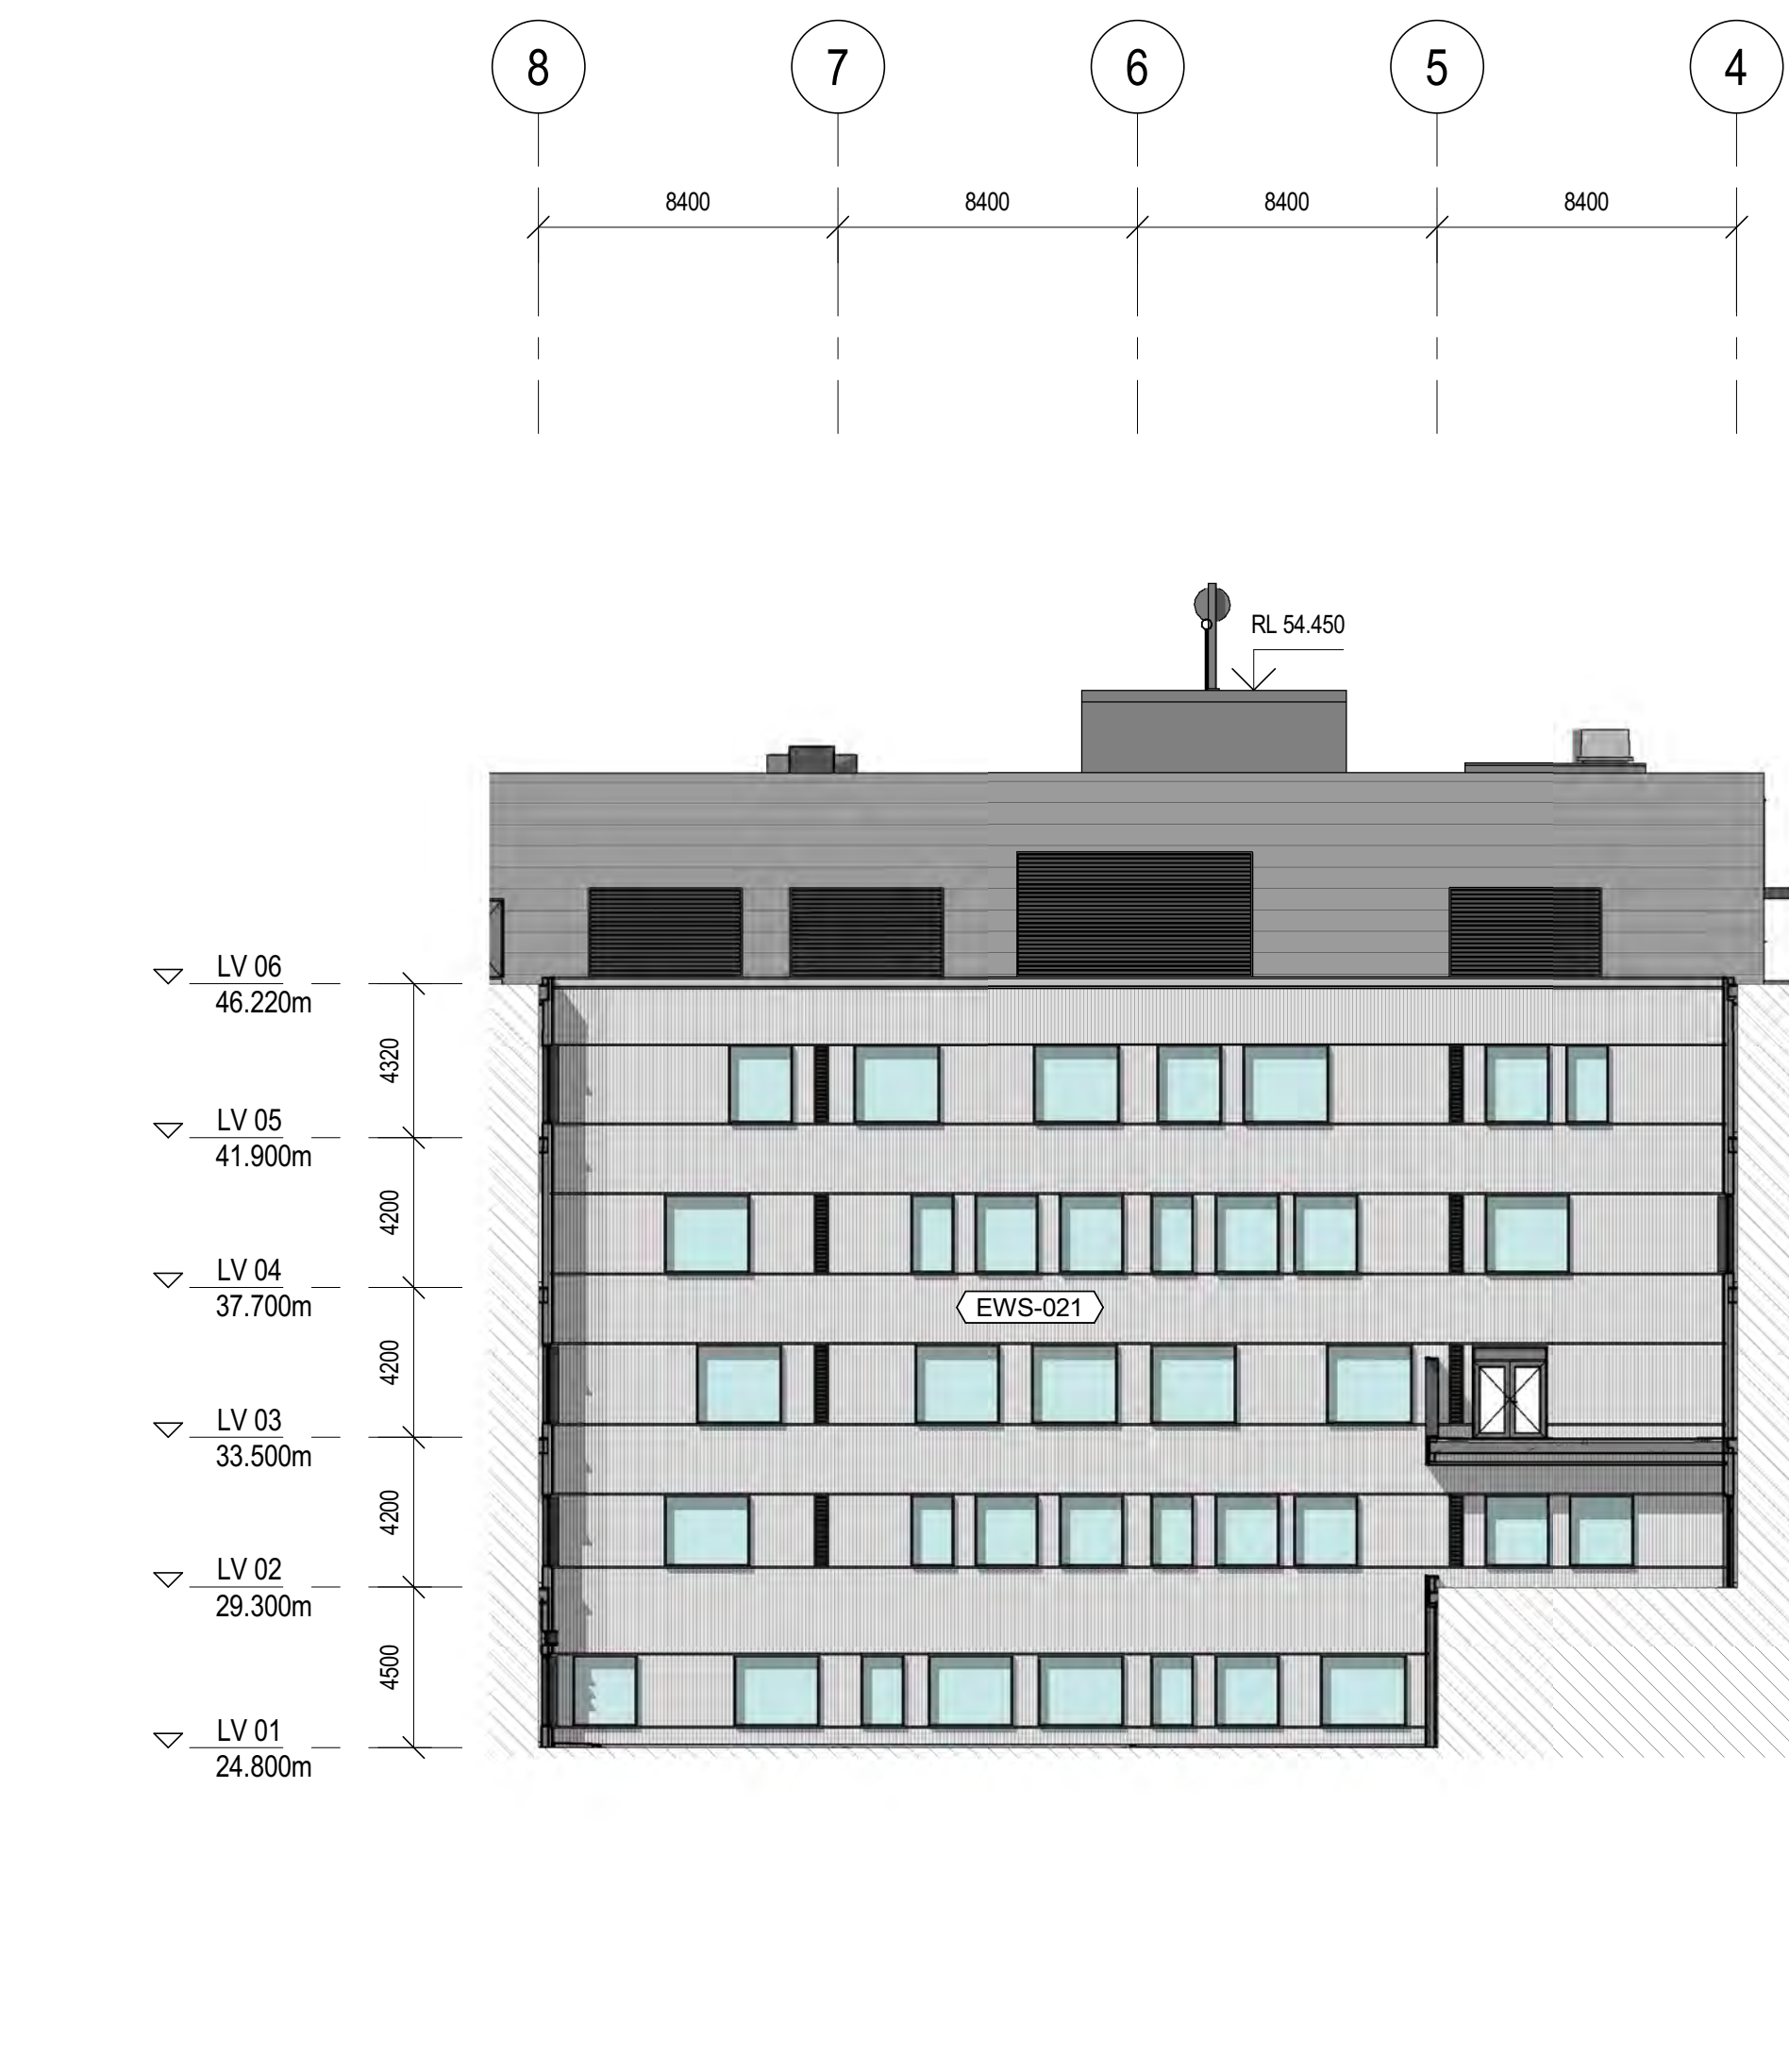


4 PART ELEVATION ZONE 20 SOUTH
1:200

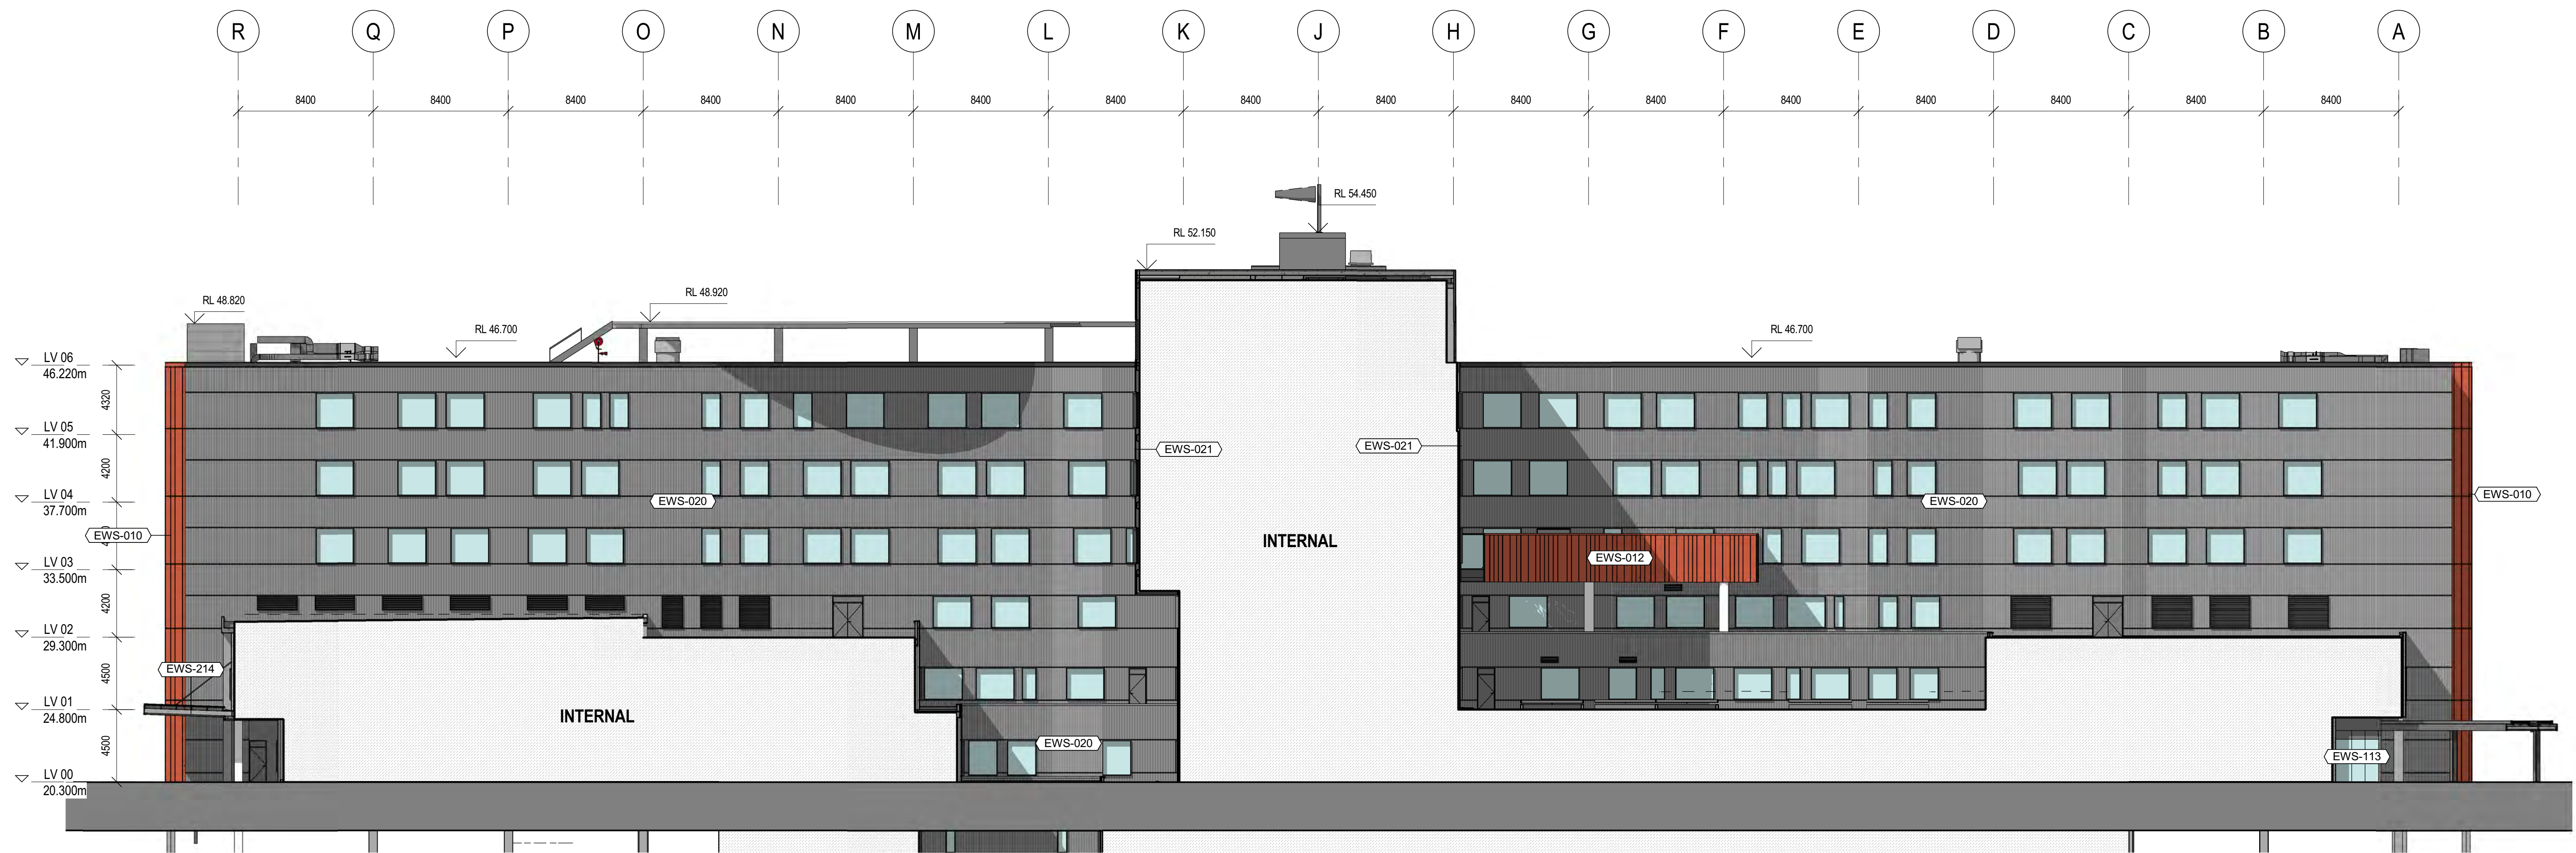

2 WEST PART ELEVATION
1:200

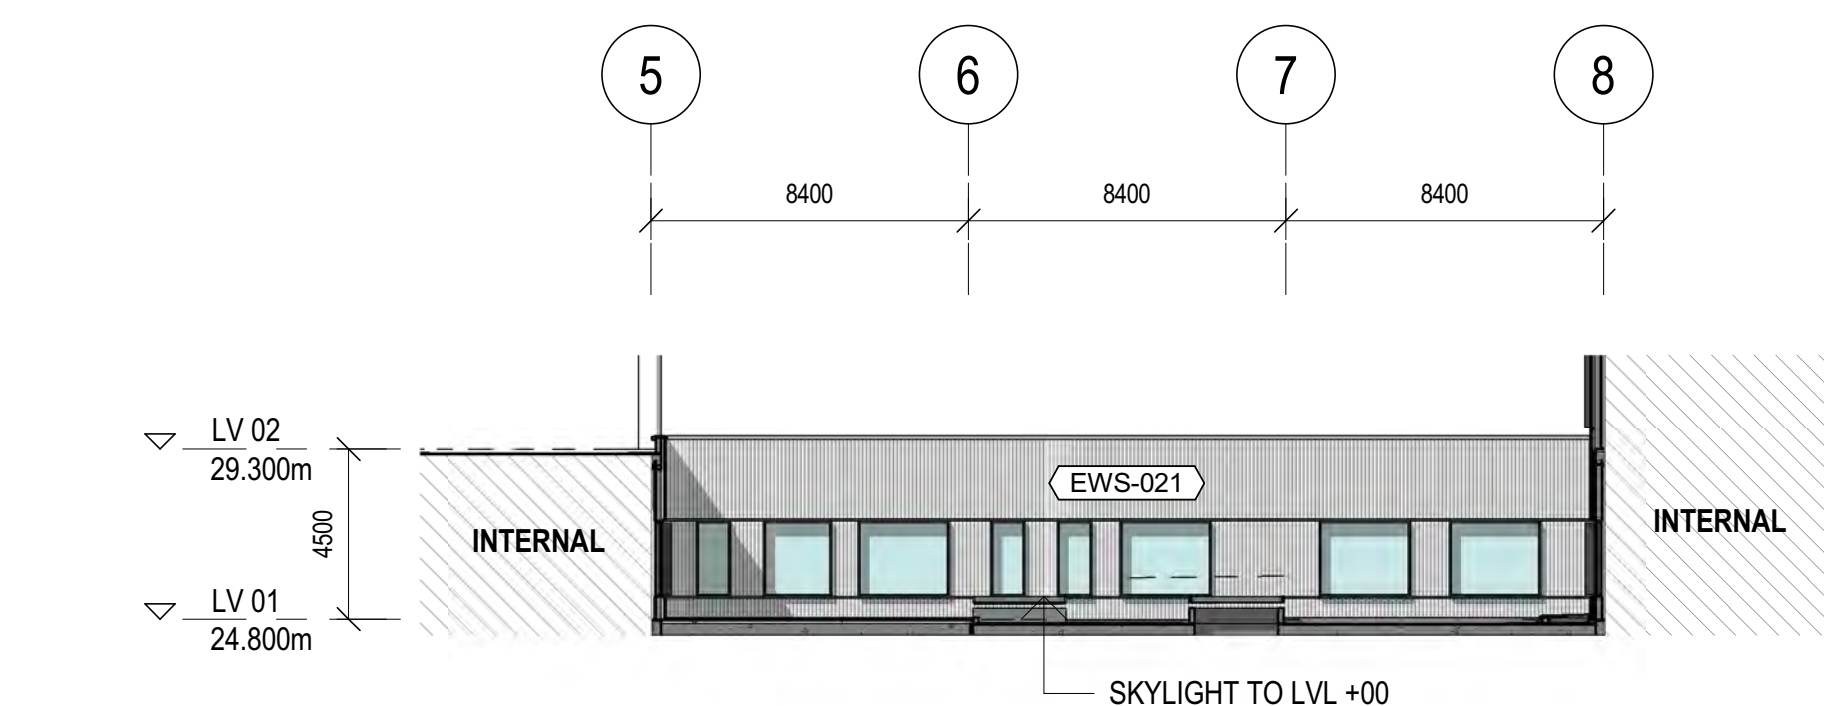

3 PART ELEVATION ZONE 20 NORTH
1:200

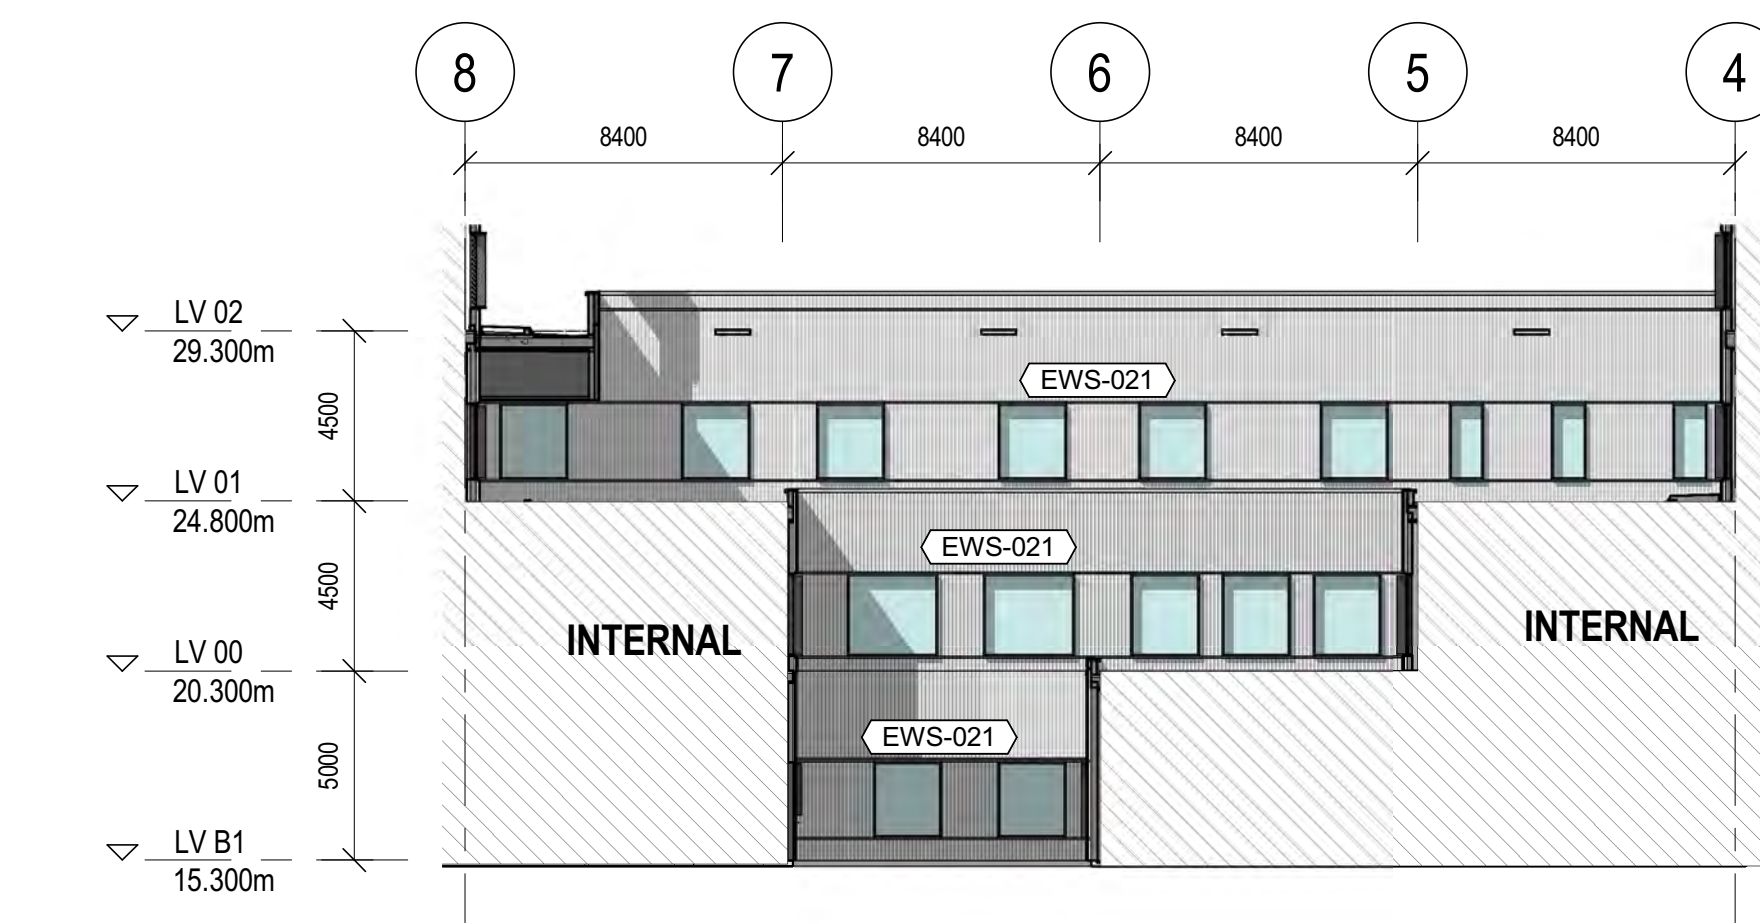

6 PART SOUTH ELEVATION ZONE 40
1:200

CLIENT

NSW Health
Infrastructure

HEALTH INFRASTRUCTURE

MANAGING CONTRACTOR
MULTIPLEX
Built to outperform.

PROJECT MANAGER
CBRE
(02) 9333 3333

CBRE

STRUCTURE / FACADE / CIVIL

TTW
(02) 9439 7288

MECHANICAL / MEDICAL GASES / ESD

EMF Griffiths
(02) 9263 8445

ELECTRICAL / COMM / VERTICAL TRANSPORT

JHA
(02) 9437 1000

HYDRAULIC / FIRE

Warren Smith & Partners
(02) 9299 1312

PCA / BCA / DDA /

Group DLA
(02) 8090 1493

FIRE ENGINEERING

PGA

PROJECT

NEW MAITLAND HOSPITAL

CORNER OF METFORD RD AND

FIELSEND ST,

METFORD, NSW 2323

BVN PROJECT NUMBER

S1806011.000

DRAWING KEY

TRUE NORTH

PROJECT NORTH

SCALE

1:200 @A0 DO NOT SCALE

0 1000 4000 8000

1:200

DRAWN BY

CHECKED BY

DESIGNED BY

APPROVED BY

STATUS

DESIGN DEVELOPMENT

DRAWING

HOSPITAL - ELEVATIONS

PART EAST AND WEST

DRAWING NUMBER

BVN-ARH-

11C-A00- 103

ISSUE

11

MAITLAND HOSPITAL MATERIALS BOARD

Government Architect
Endorsed

① PODIUM



REFERENCE IMAGE: Embassy red. Australian Embassy Thailand, BVN



REFERENCE IMAGE: Texture and variation to brick facade



Left: Lincoln Brickworks 'Central Red' to brick veneer podium
Right: Colourbond 'Monument' to window frames




VISUALISATION

④

③

②

①

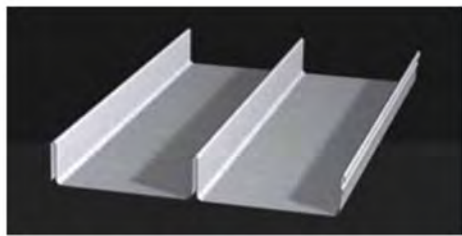

REFERENCE IMAGE: Metal profile sample




REFERENCE IMAGE: Metallic finish to metal cladding

③ IPU (External Bar)



Left: Colorbond 'Aries' (metallic) to standing seam metal cladding
Right: Colorbond 'Monument' to window frames

② ARBOUR

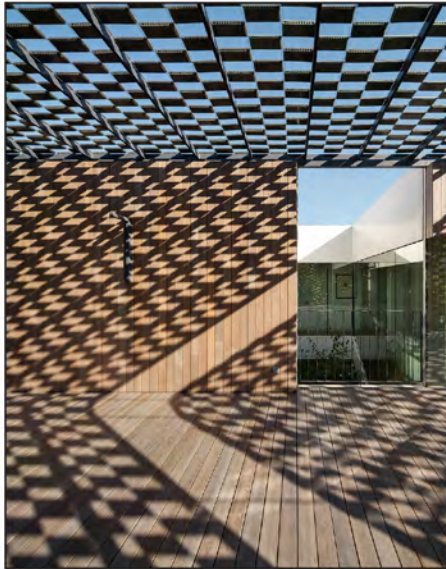

REFERENCE IMAGE: Flexbrick screening system to arbour



Tempio terracotta standard colour range to express variation on arbour screening

④ IPU (Internal Bar)



REFERENCE IMAGE: Metal profile sample



REFERENCE IMAGE: Projected window frame



Left: Colorbond 'Basalt' to corrugated profile metal cladding
Right: Colorbond 'Monument' to window frames