

Koondrook-Perricoota Forest Flood Enhancement Works

Appendix H Concept drawings for the main structures



9/02/2010 1:00:23 PM g:\is\water\tec\pcad\koondrook\design_09\upstream_structures\p4078-41.dgn

479

B1

960

© CROWN COPYRIGHT NSW MINISTER FOR COMMENCE

1100

1200

1300

TORRUMBARRY WEIR
OFFTAKE
REGULATOR
AND FISHWAY

SWAN LAGOON
REGULATOR
UPSTREAM

SWAN LAGOON
REGULATOR
DOWNSTREAM

MURRAY
RIVER

LANDING
ROAD

ROAD

RIVER

LOCK
ROAD

RIVER

RIVER ROAD
BRIDGE

ROAD

EXISTING
GULLY
EXCAVATED
CHANNEL

BULLOCK HEAD
CK

BLACK BOX ROAD

RIVER
ROAD

FREEMANS ROAD

MGA NORTH

1:10000 0 200 400m
200 100

DRAFT COPY

GRAEME HEAD - Director General
Department of Services, Technology and Administration
NSW WATER SOLUTIONS
DAMS AND CIVIL TECHNOLOGIES
LEVEL 13, MCKELL BUILDING
2-24 RAWSON PLACE
SYDNEY 2000
PHONE (02) 93727808 FAX (02) 93727822

DESIGNED	SP ENGINEER
A. AGARWAL	G. SAMIOS
DRAFTED	G.M. DAMS AND CIVIL TECHNOLOGIES
D.T.	J.R. LENEHAN
CHECKED	
G. SAMIOS	



 

KOONDROOK - PERRICOOTA
FLOOD ENHANCEMENT
UPSTREAM STRUCTURES
SITE PLAN

NO IN SET
FILE NO. DCF 6815
DRAWING NO. 4078 - 41
REVISION 0

g:\is\water\tec\pcad\koondrook\design_09\upstream_structures\p4078-50.dgn
No 1 on 2
11/02/2010 1:00:28 PM

OFFTAKE REGULATOR

RIVER ROAD BRIDGE

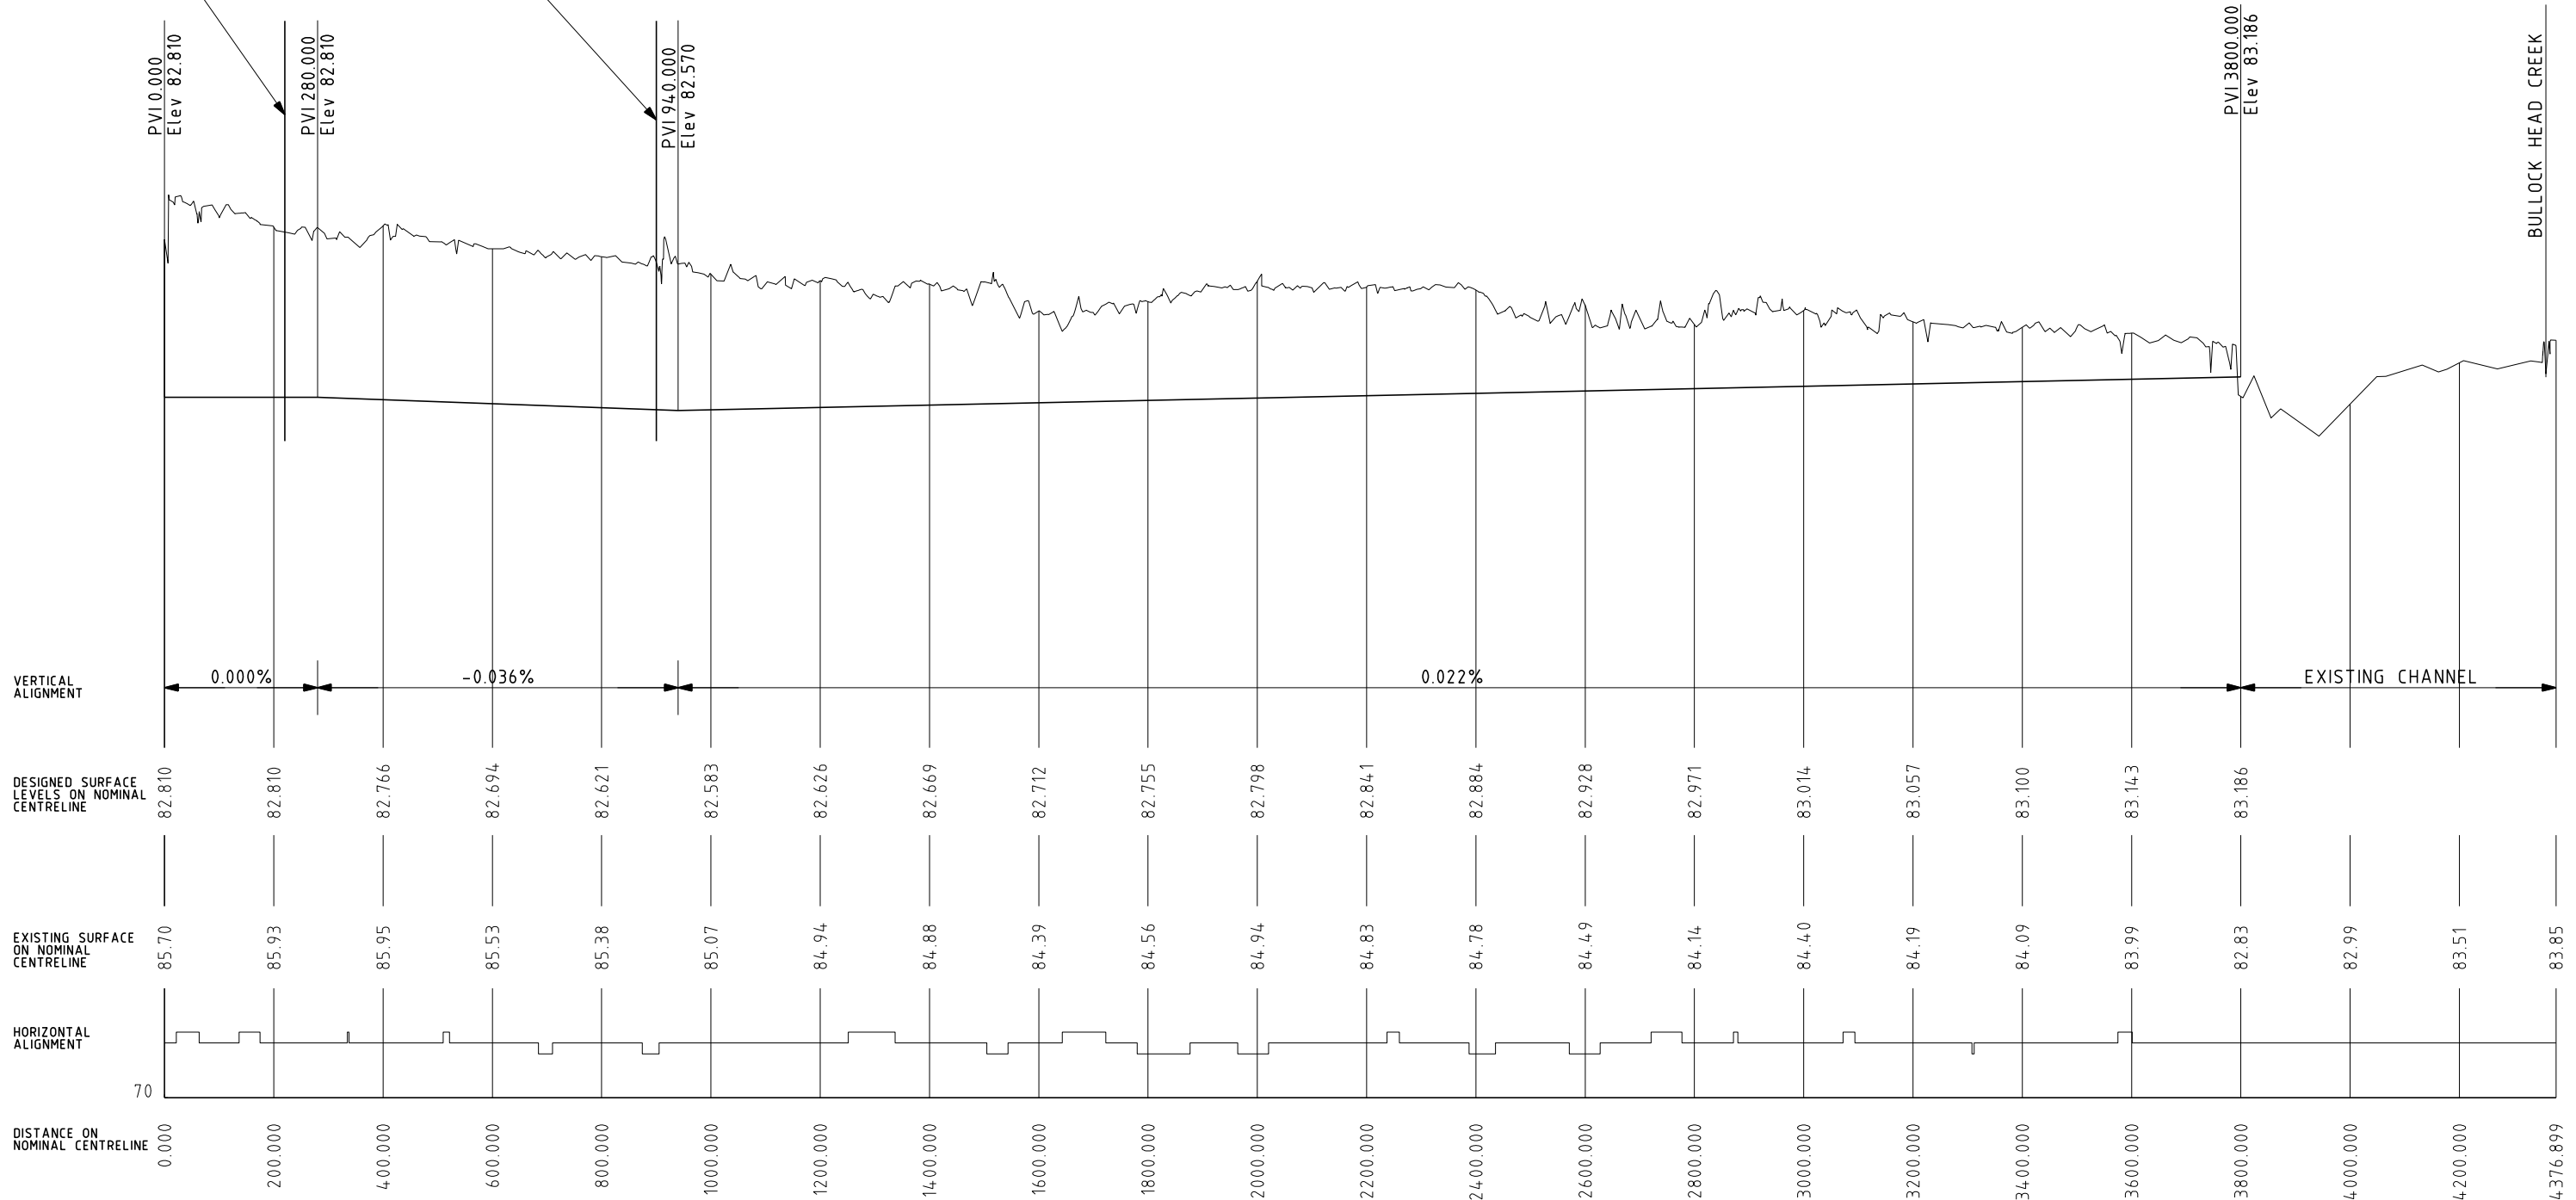

DRAFT COPY

GRAEME HEAD - Director General
Department of Services, Technology and Administration

NSW WATER SOLUTIONS
DAMS AND CIVIL TECHNOLOGIES
LEVEL 13, McKELL BUILDING
2-24 RAWSON PLACE
SYDNEY 2000
PHONE (02) 93727808 FAX (02) 93727822

PLAN RM NO

DESIGNED	S.P. ENGINEER
A. AGARWAL	G. SAMIOS
DRAFTED	G.M. DAMS AND CIVIL TECHNOLOGIES
D.T.	J.R. LENEHAN
CHECKED	
G. SAMIOS	



**KOONDROOK - PERRICOOTA
FLOOD ENHANCEMENT**




**UPSTREAM CHANNEL
LONGITUDINAL SECTION
CH. 0.0 TO CH. 4376.9**

NO IN SET

FILE NO.
DCF 6815

DRAWING NO.
4078 - 50

 REVISION 0

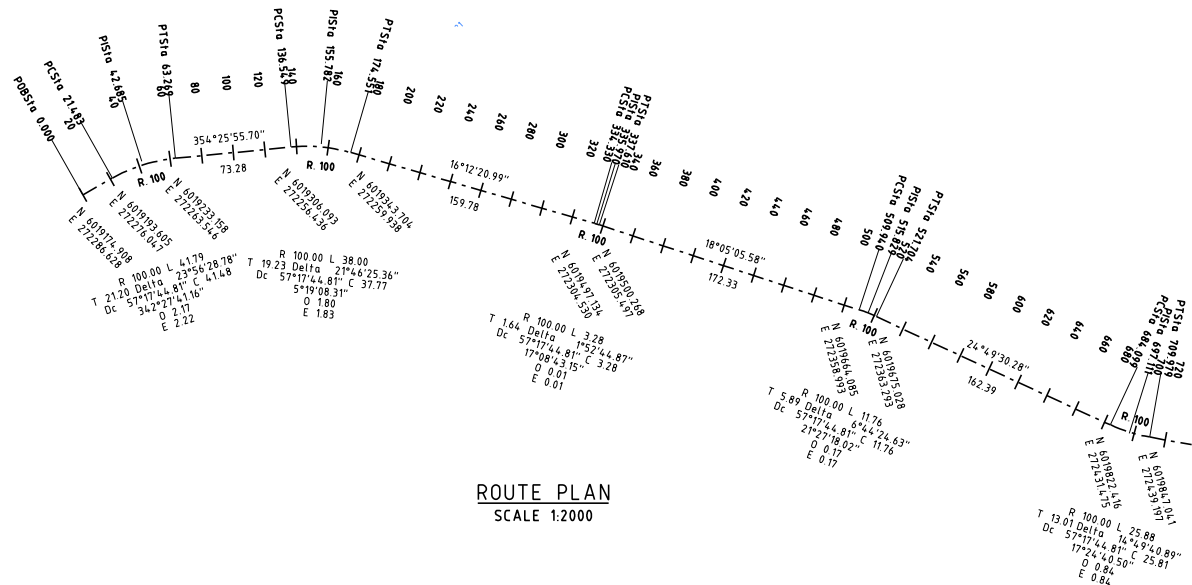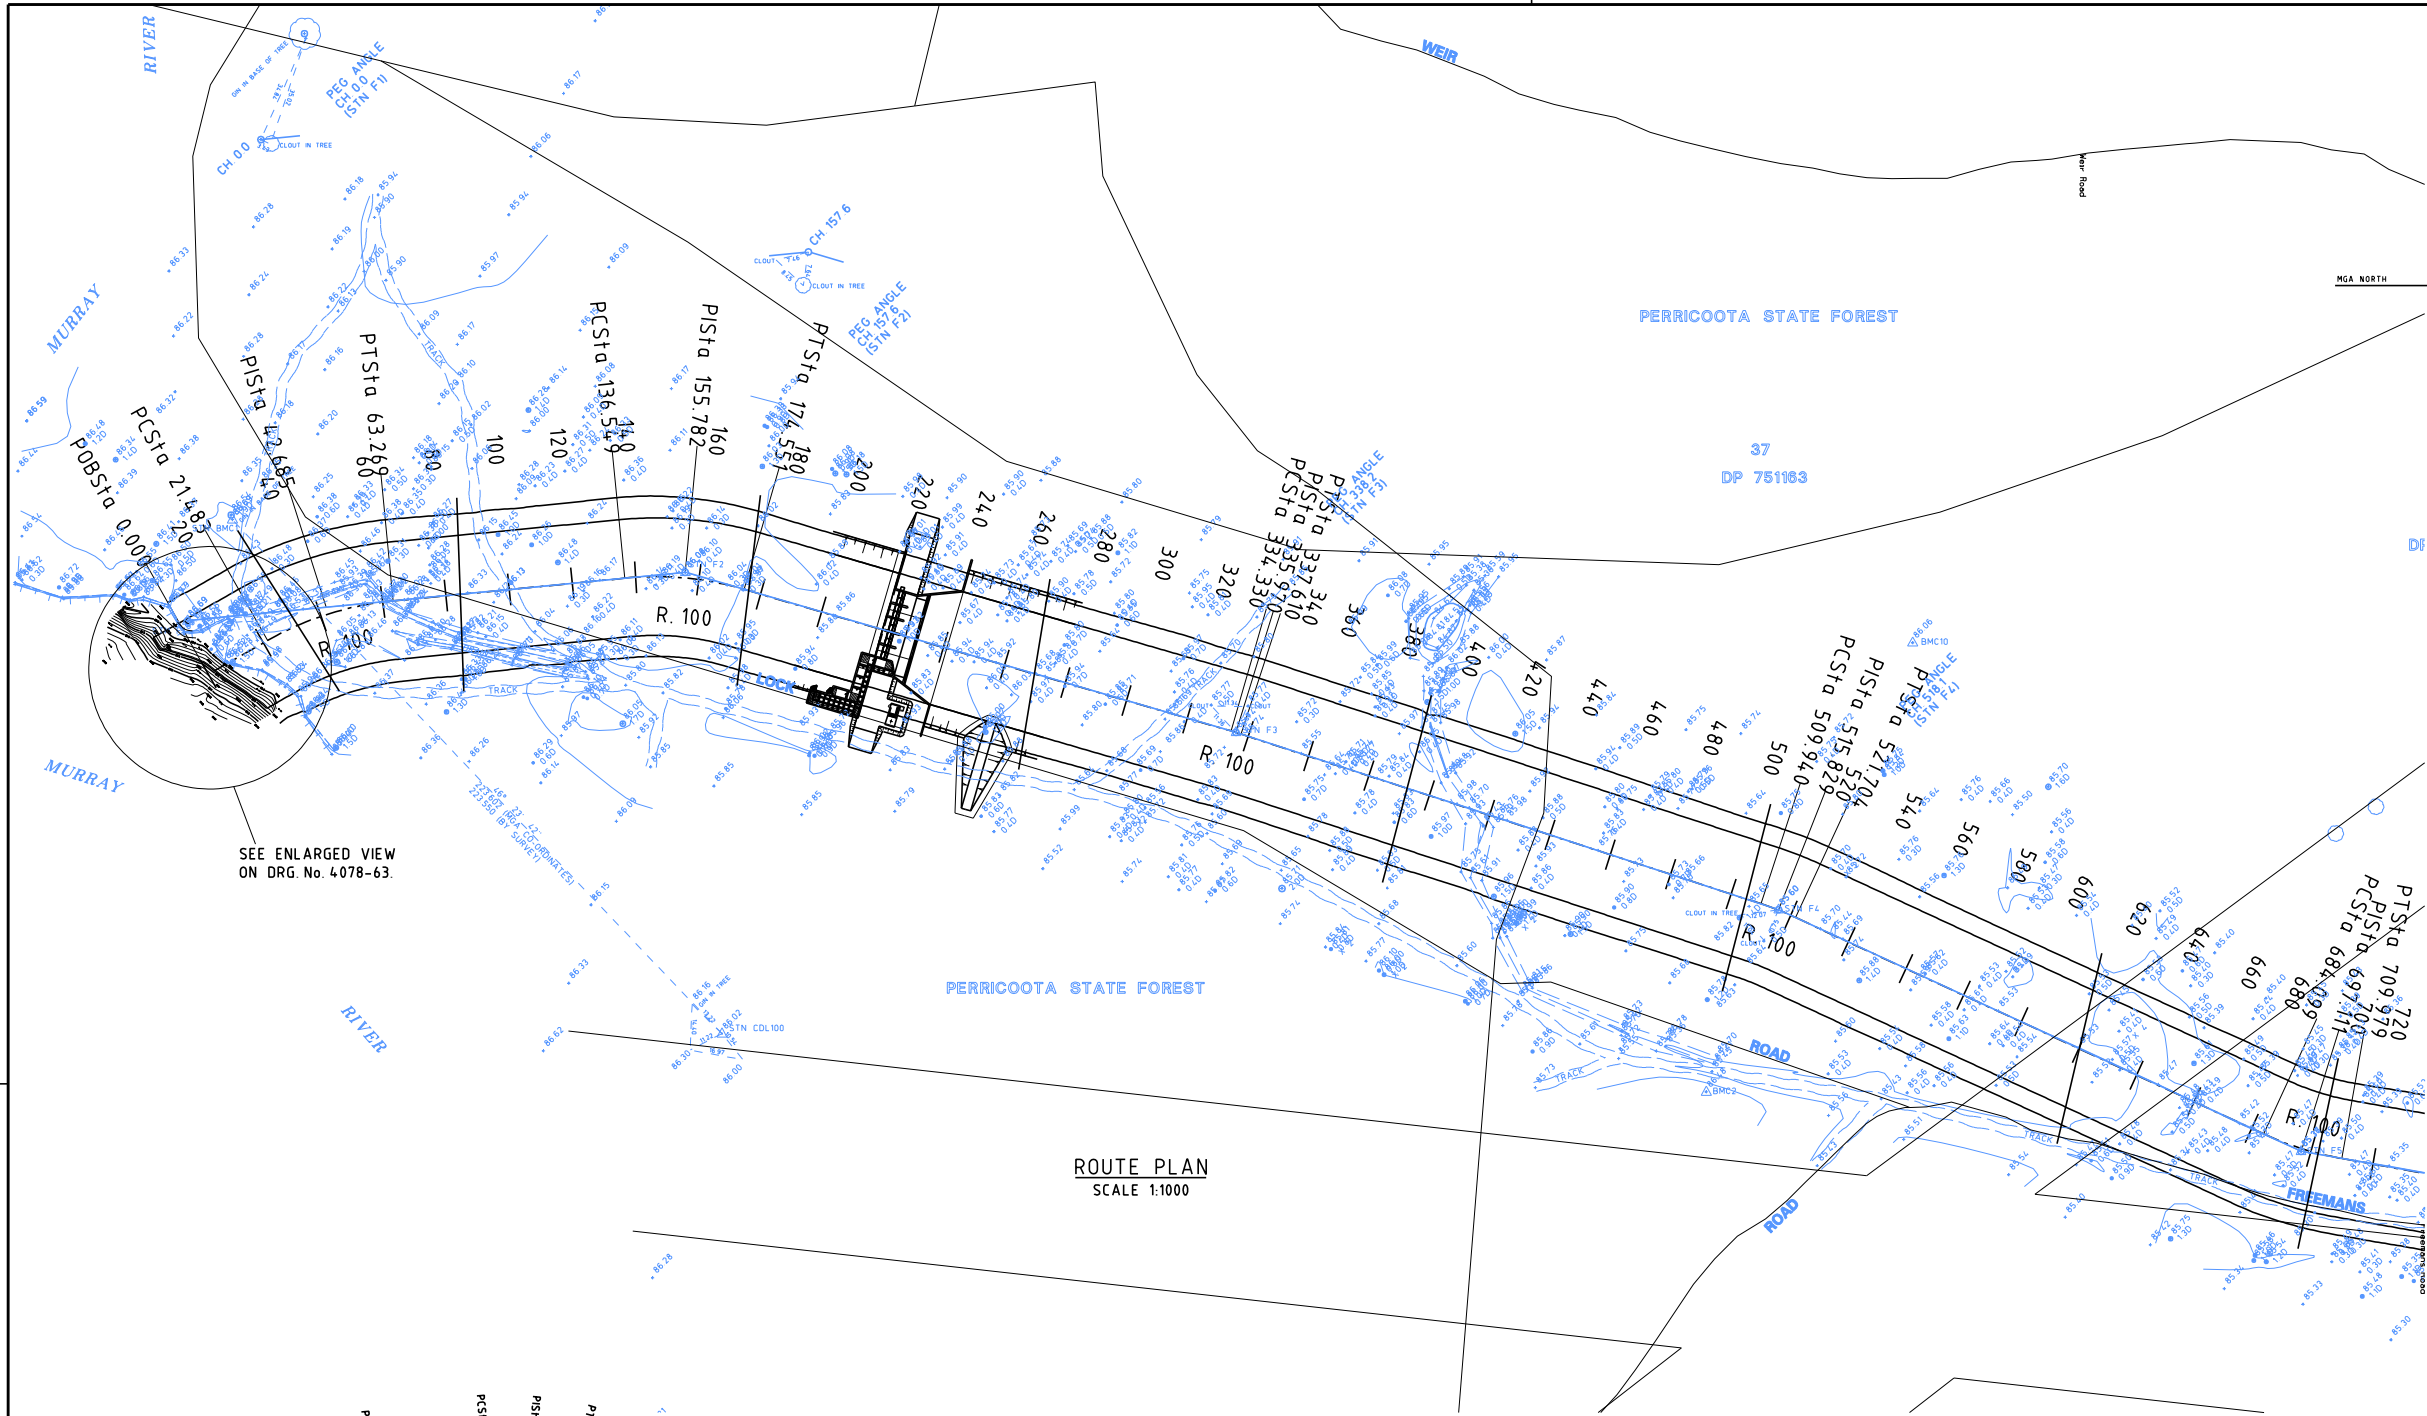

ISSUED FOR REVIEW.			
0	DETAILS OF AMENDMENTS	APPROVED	DATE
MK			

DRAFT COPY






GRAEME HEAD - Director General
Department of Services, Technology and Administration
NSW WATER SOLUTIONS
DAMS AND CIVIL TECHNOLOGIES
LEVEL 13, McKELL BUILDING
2-24 RAWSON PLACE
SYDNEY 2000
PHONE (02) 93727808 FAX (02) 93727822

PLAN RM NO	
DESIGNED	SP ENGINEER
A. AGARWAL	G. SAMIOS
DRAFTED	G.M DAMS AND CIVIL TECHNOLOGIES
	J.R. LENEHAN
CHECKED	
G. SAMIOS	




**KOONDROOK - PERRICOTA
FLOOD ENHANCEMENT**
**UPSTREAM CHANNEL
ROUTE PLAN
CH. 0.0 TO 600.0**

 
NO IN SET
FILE NO. DCF 6815
DRAWING NO. 4078 - 51
REVISION 0

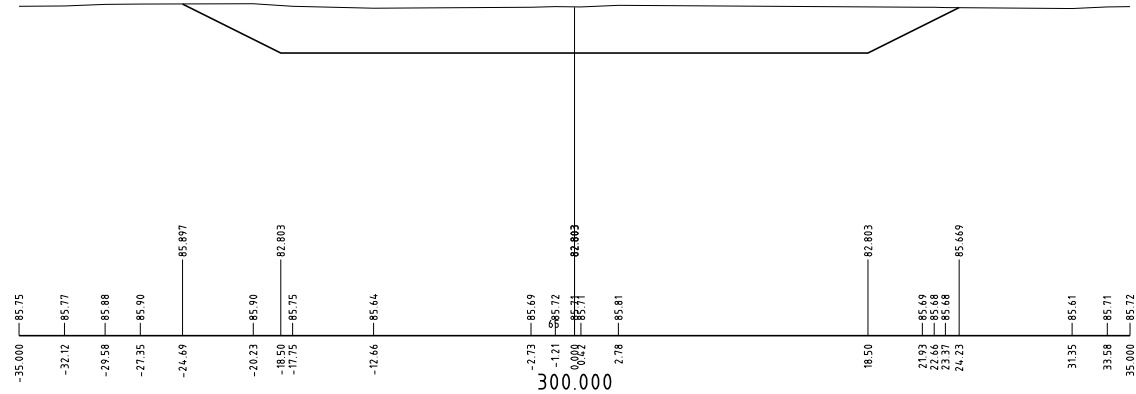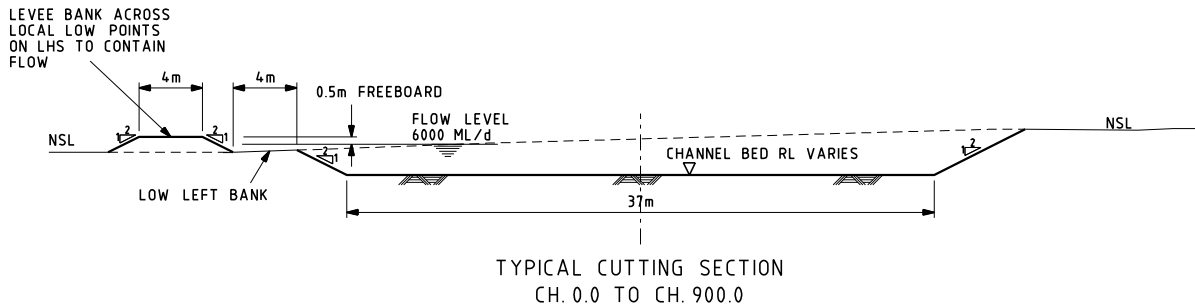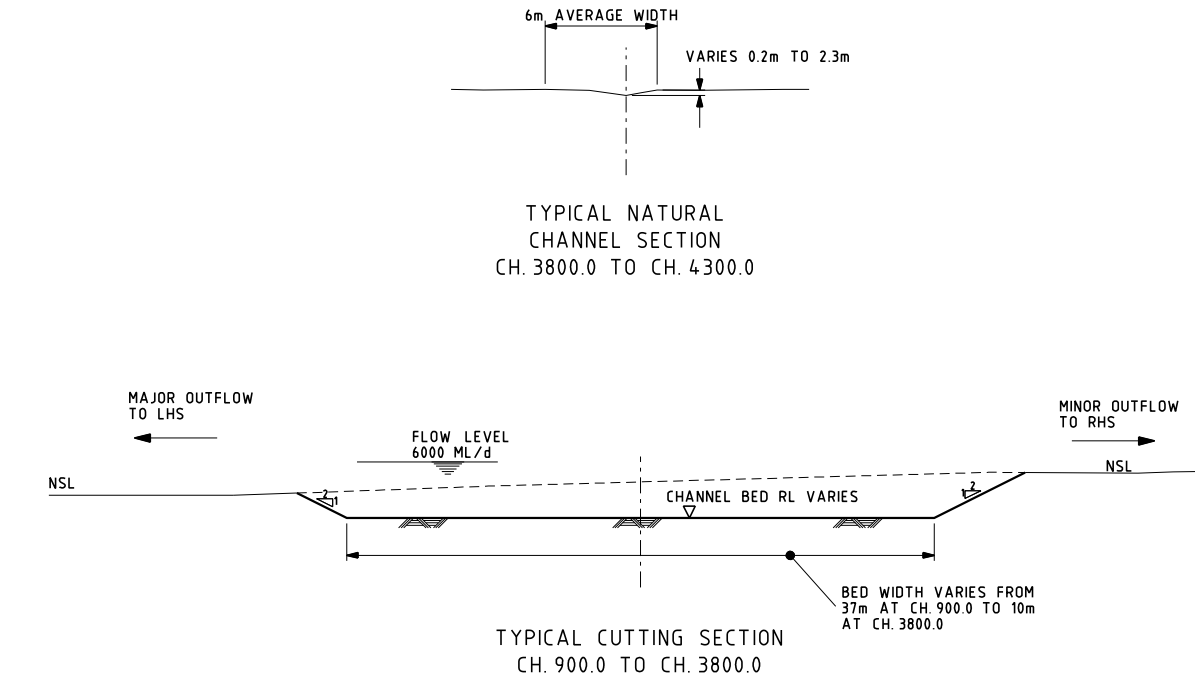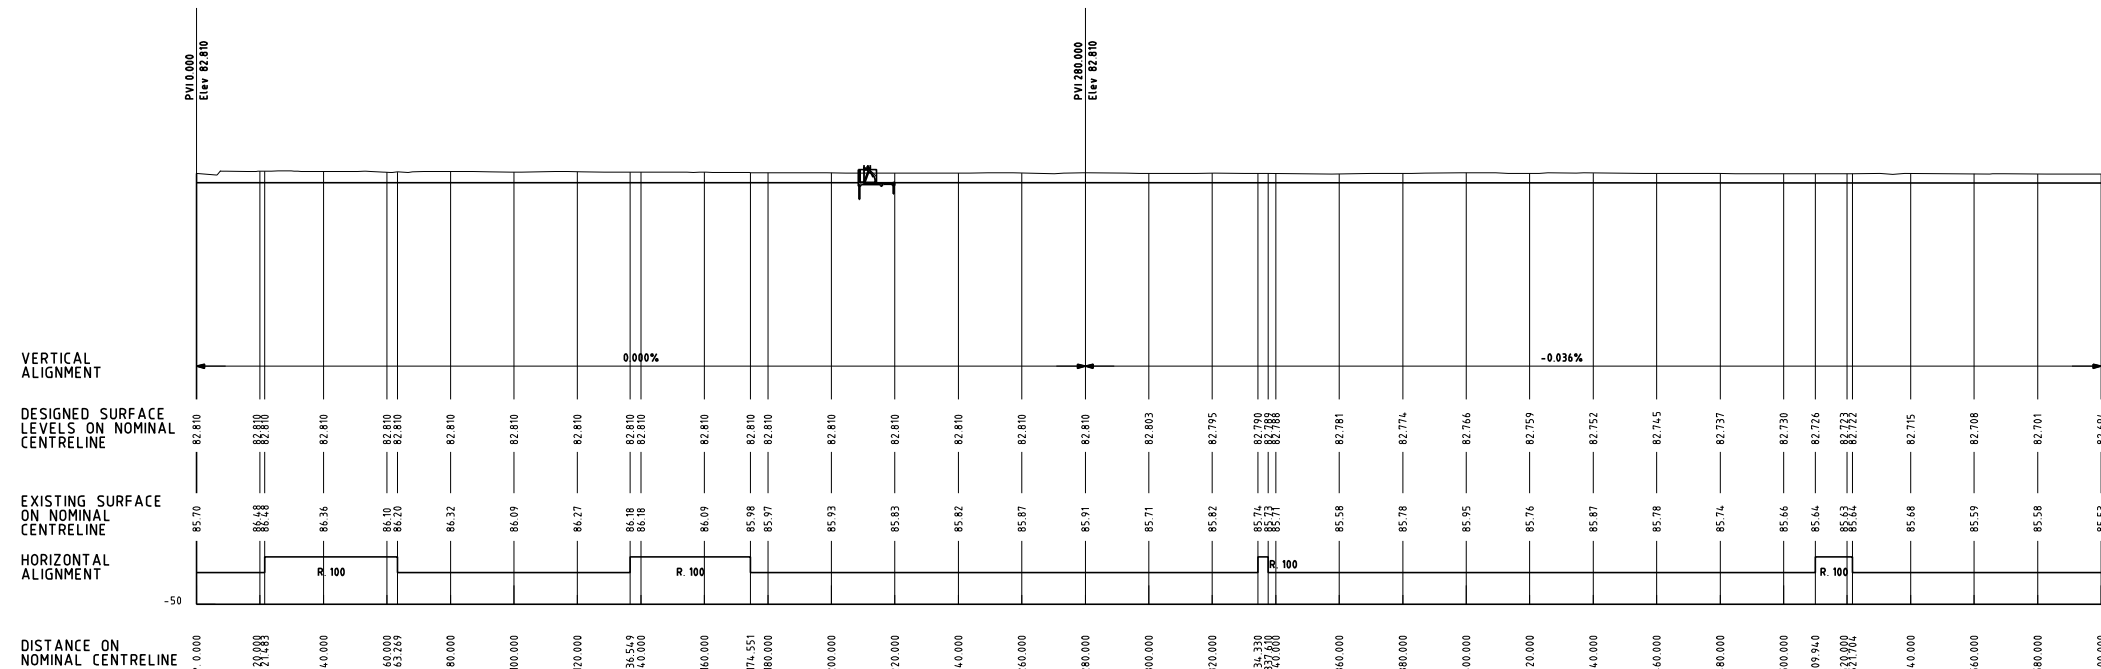


DRAFT COPY		GRAEME HEAD - Director General Department of Services, Technology and Administration		PLAN RM NO				KOONDROOK - PERRICOOTA FLOOD ENHANCEMENT		NO IN SET
		NSW WATER SOLUTIONS DAMS AND CIVIL TECHNOLOGIES LEVEL 13, MCKELL BUILDING 2-24 RAWSON PLACE SYDNEY 2000 PHONE (02) 93727808 FAX (02) 93727822		DESIGNED A. AGARWAL				SP ENGINEER G. SAMIOS		FILE NO. DCF 6815
				DRAFTED D.T.				G.M. DAMS AND CIVIL TECHNOLOGIES J.R. LENEHAN		DRAWING NO. 4078 - 52
				CHECKED G. SAMIOS						REVISION 0

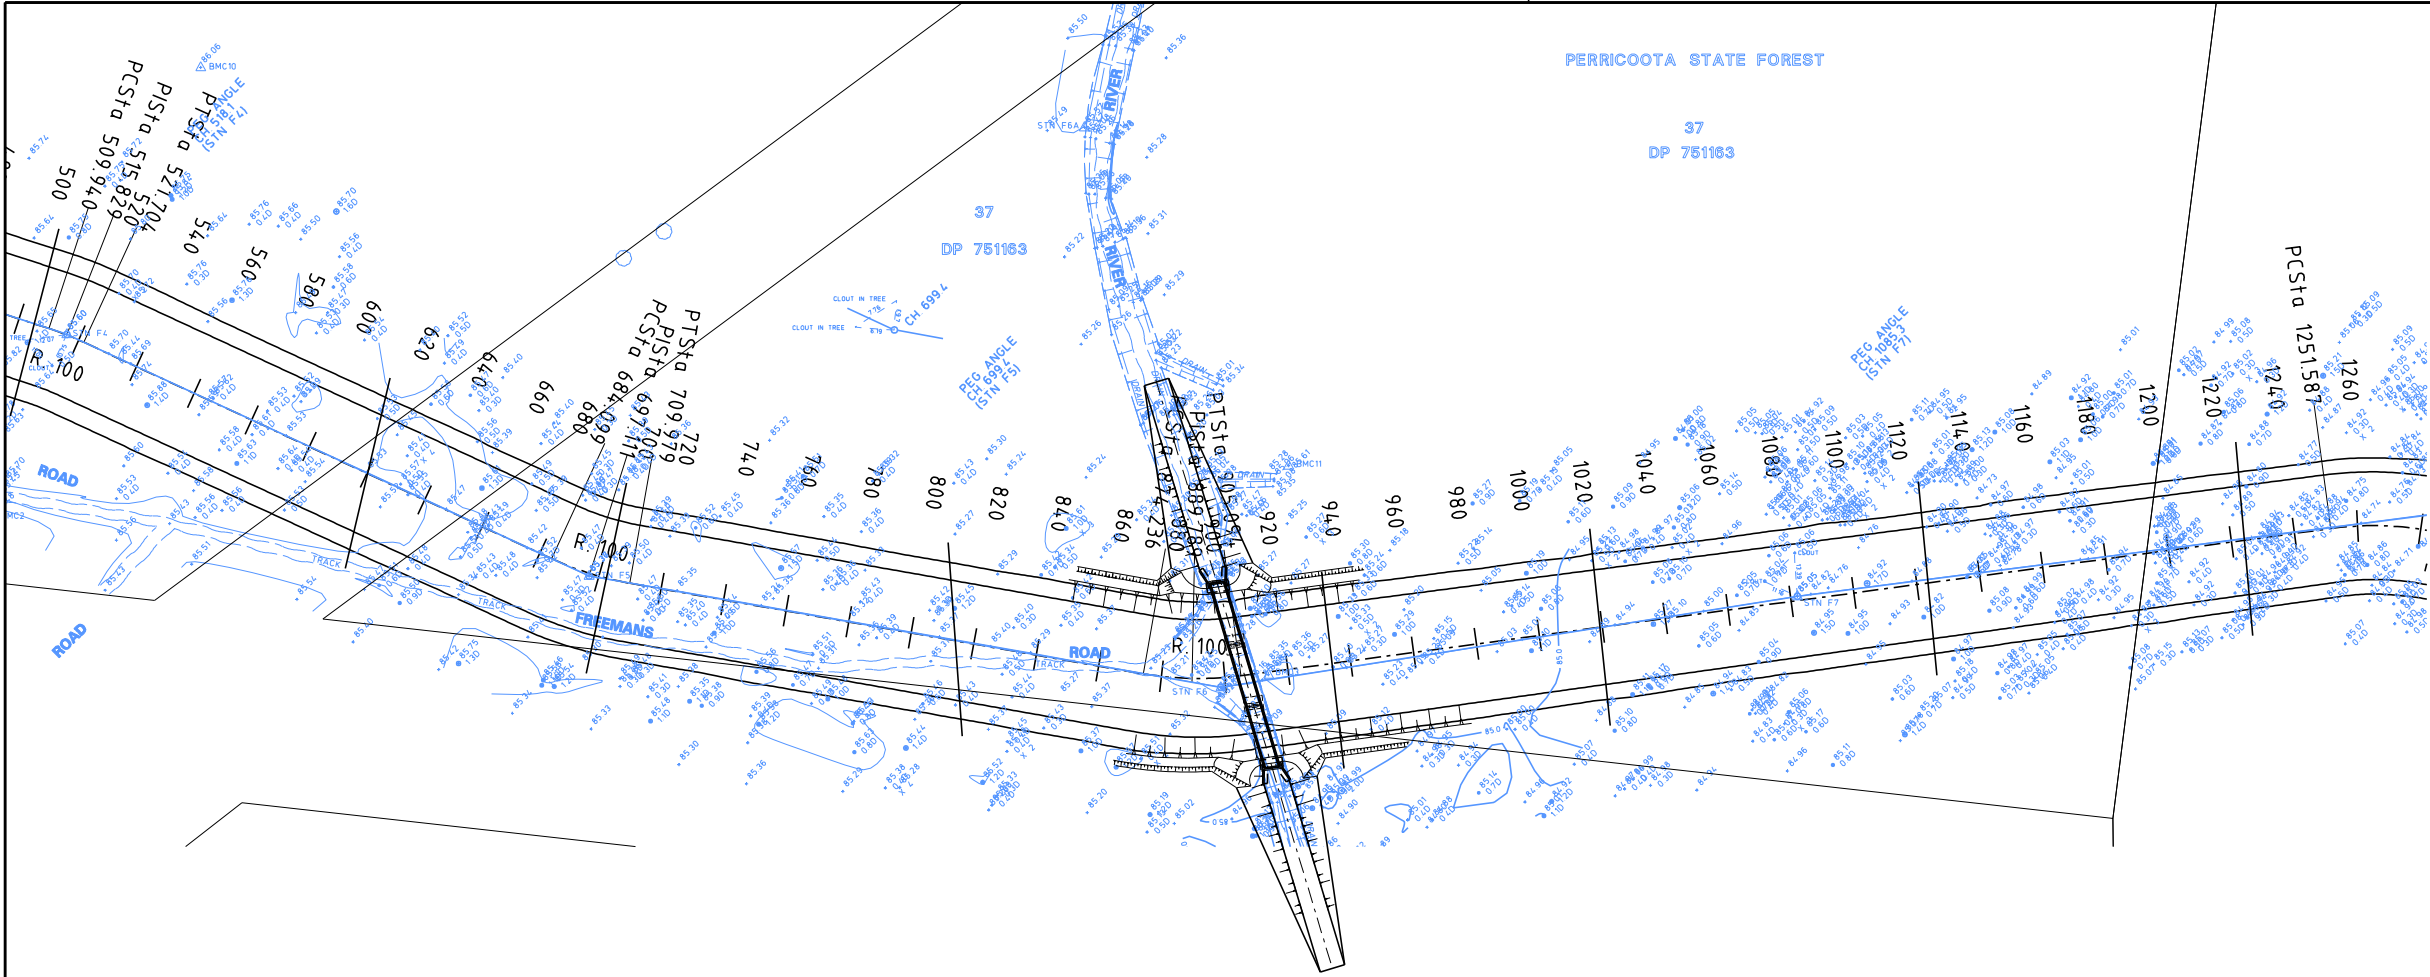

ROUTE PLAN
SCALE 1:1000

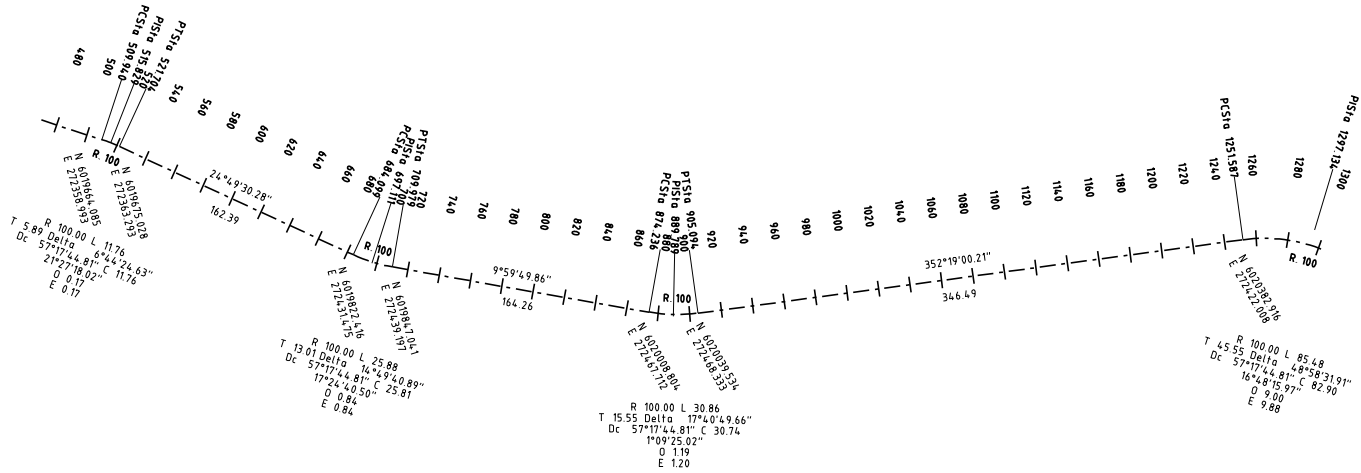

SETTING OUT DIAGRAM
SCALE 1:2000

 


DRAFT COPY

GRAEME HEAD - Director General
Department of Services, Technology and Administration
NSW WATER SOLUTIONS
DAMS AND CIVIL TECHNOLOGIES
LEVEL 13, MCKELL BUILDING
2-24 RAWSON PLACE
SYDNEY 2000
PHONE (02) 93727808 FAX (02) 93727822

DESIGNED	SP. ENGINEER
A. AGARWAL	G. SAMIOS
DRAFTED	G.M. DAMS AND CIVIL TECHNOLOGIES
D.T.	J.R. LENEHAN
CHECKED	
G. SAMIOS	



KOONDROOK - PERRICOOTA FLOOD ENHANCEMENT	
UPSTREAM CHANNEL ROUTE PLAN CH. 600.0 TO CH. 1200.0	
NO IN SET	FILE NO. DCF 6815
	DRAWING NO. 4078 - 53
	REVISION 0

 

DRAFT COPY




GRAEME HEAD - Director General
Department of Services, Technology and Administration
NSW WATER SOLUTIONS
DAMS AND CIVIL TECHNOLOGIES
LEVEL 13, MCKELL BUILDING
2-24 RAWSON PLACE
SYDNEY 2000
PHONE (02) 93727808 FAX (02) 93727822

PLAN RM NO	
DESIGNED A. AGARWAL	S.P. ENGINEER G. SAMIOS
DRAFTED	G.M. DAMS AND CIVIL TECHNOLOGIES J.R. LENEHAN
CHECKED G. SAMIOS	



**KOONDROOK - PERRICOOTA
FLOOD ENHANCEMENT**

 NO IN SET
FILE NO. DCF 6815
DRAWING NO. 4078 - 54
REVISION 0

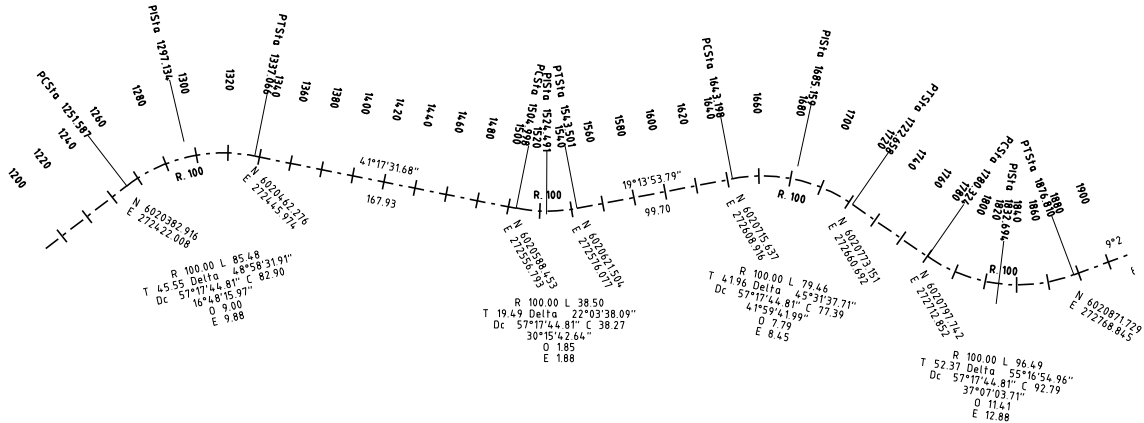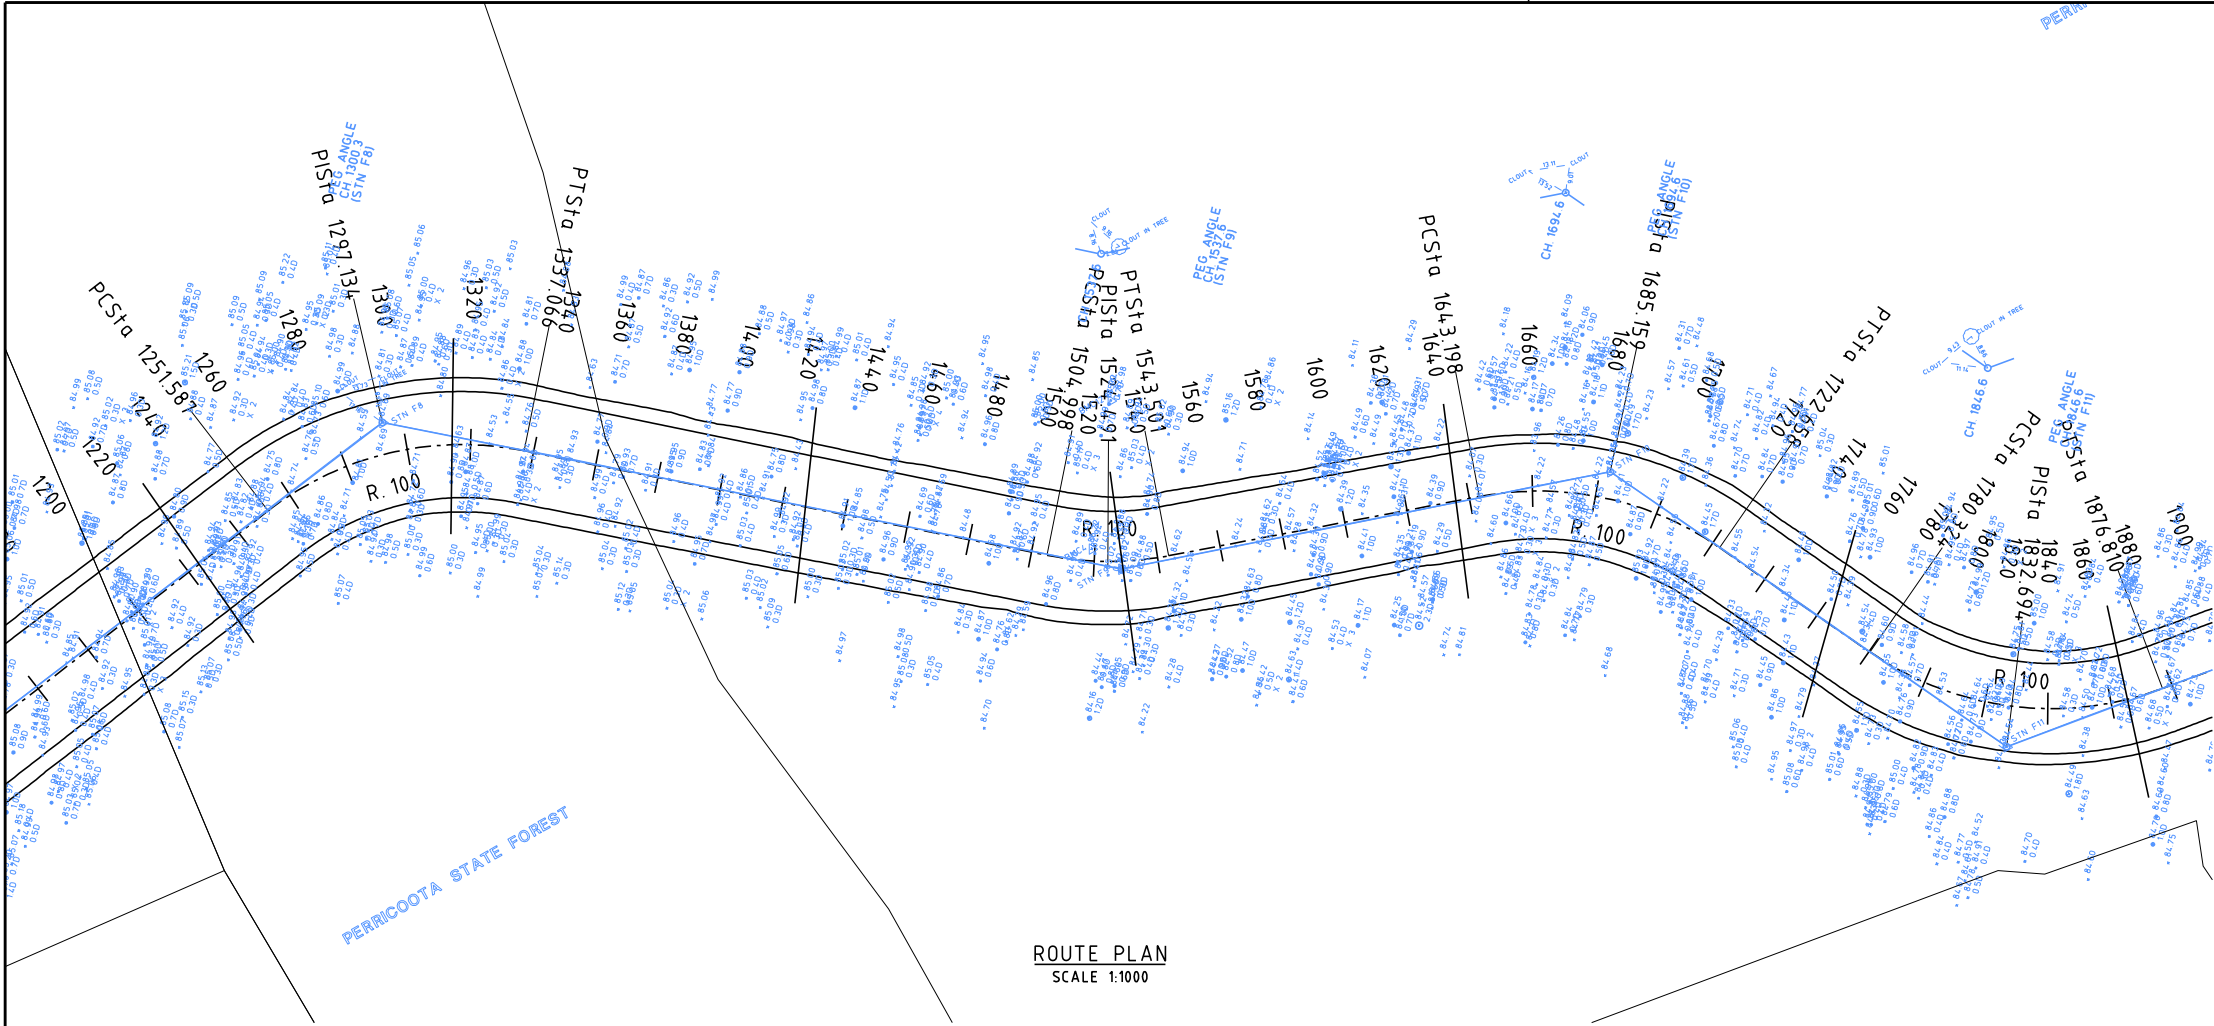

ISSUED FOR REVIEW.			
DETAILS OF AMENDMENTS	APPROVED	DATE	

DRAFT COPY



GRAEME HEAD - Director General
Department of Services, Technology and Administration
NSW WATER SOLUTIONS
DAMS AND CIVIL TECHNOLOGIES
LEVEL 13, MCKELL BUILDING
2-24 RAWSON PLACE
SYDNEY 2000
PHONE (02) 93727808 FAX (02) 93727822

DESIGNED	SP. ENGINEER
A. AGARWAL	G. SAMIOS
DRAFTED	G.M. DAMS AND CIVIL TECHNOLOGIES
D.T.	J.R. LENEHAN
CHECKED	
G. SAMIOS	



**KOONDROOK - PERRICOTA
FLOOD ENHANCEMENT**
UPSTREAM CHANNEL
ROUTE PLAN
CH. 1200.0 TO CH. 1800.0

NO IN SET	FILE NO.
	DCF 6815
DRAWING NO.	4078 - 55
REVISION	0

 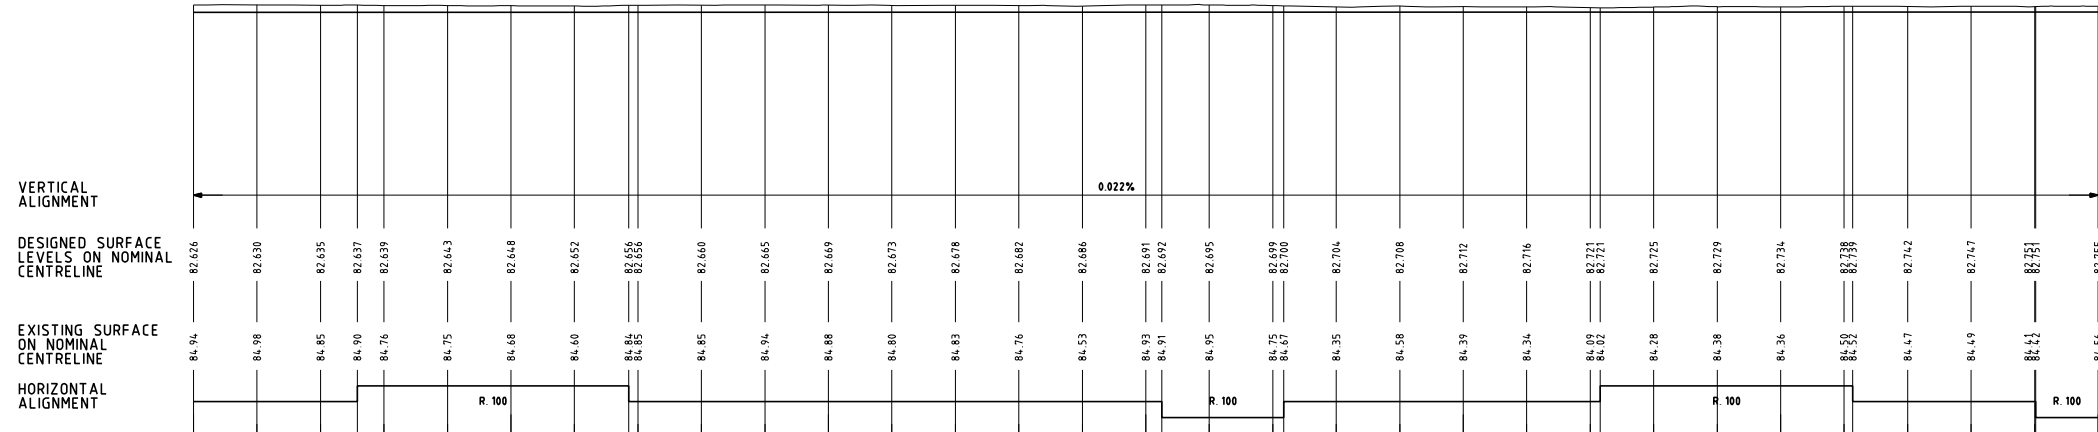

DRAFT COPY


GRAEME HEAD - Director General
Department of Services, Technology and Administration

NSW WATER SOLUTIONS
DAMS AND CIVIL TECHNOLOGIES
LEVEL 13, MCKELL BUILDING
2-24 RAWSON PLACE
SYDNEY 2000
PHONE (02) 93727808 FAX (02) 93727822



PLAN RM NO	
DESIGNED A. AGARWAL	S.P. ENGINEER G. SAMIOS
DRAFTED D.T.	G.M. DAMS AND CIVIL TECHNOLOGIES J.R. LENEHAN
CHECKED G. SAMIOS	




KOONDROOK – PERRICOTA FLOOD ENHANCEMENT	NO IN SET
	FILE NO. DCF 6815
UPSTREAM CHANNEL LONGITUDINAL SECTION CH. 1200.0 TO CH. 1800.0	DRAWING NO.
	4078 – 56 REVISION 0

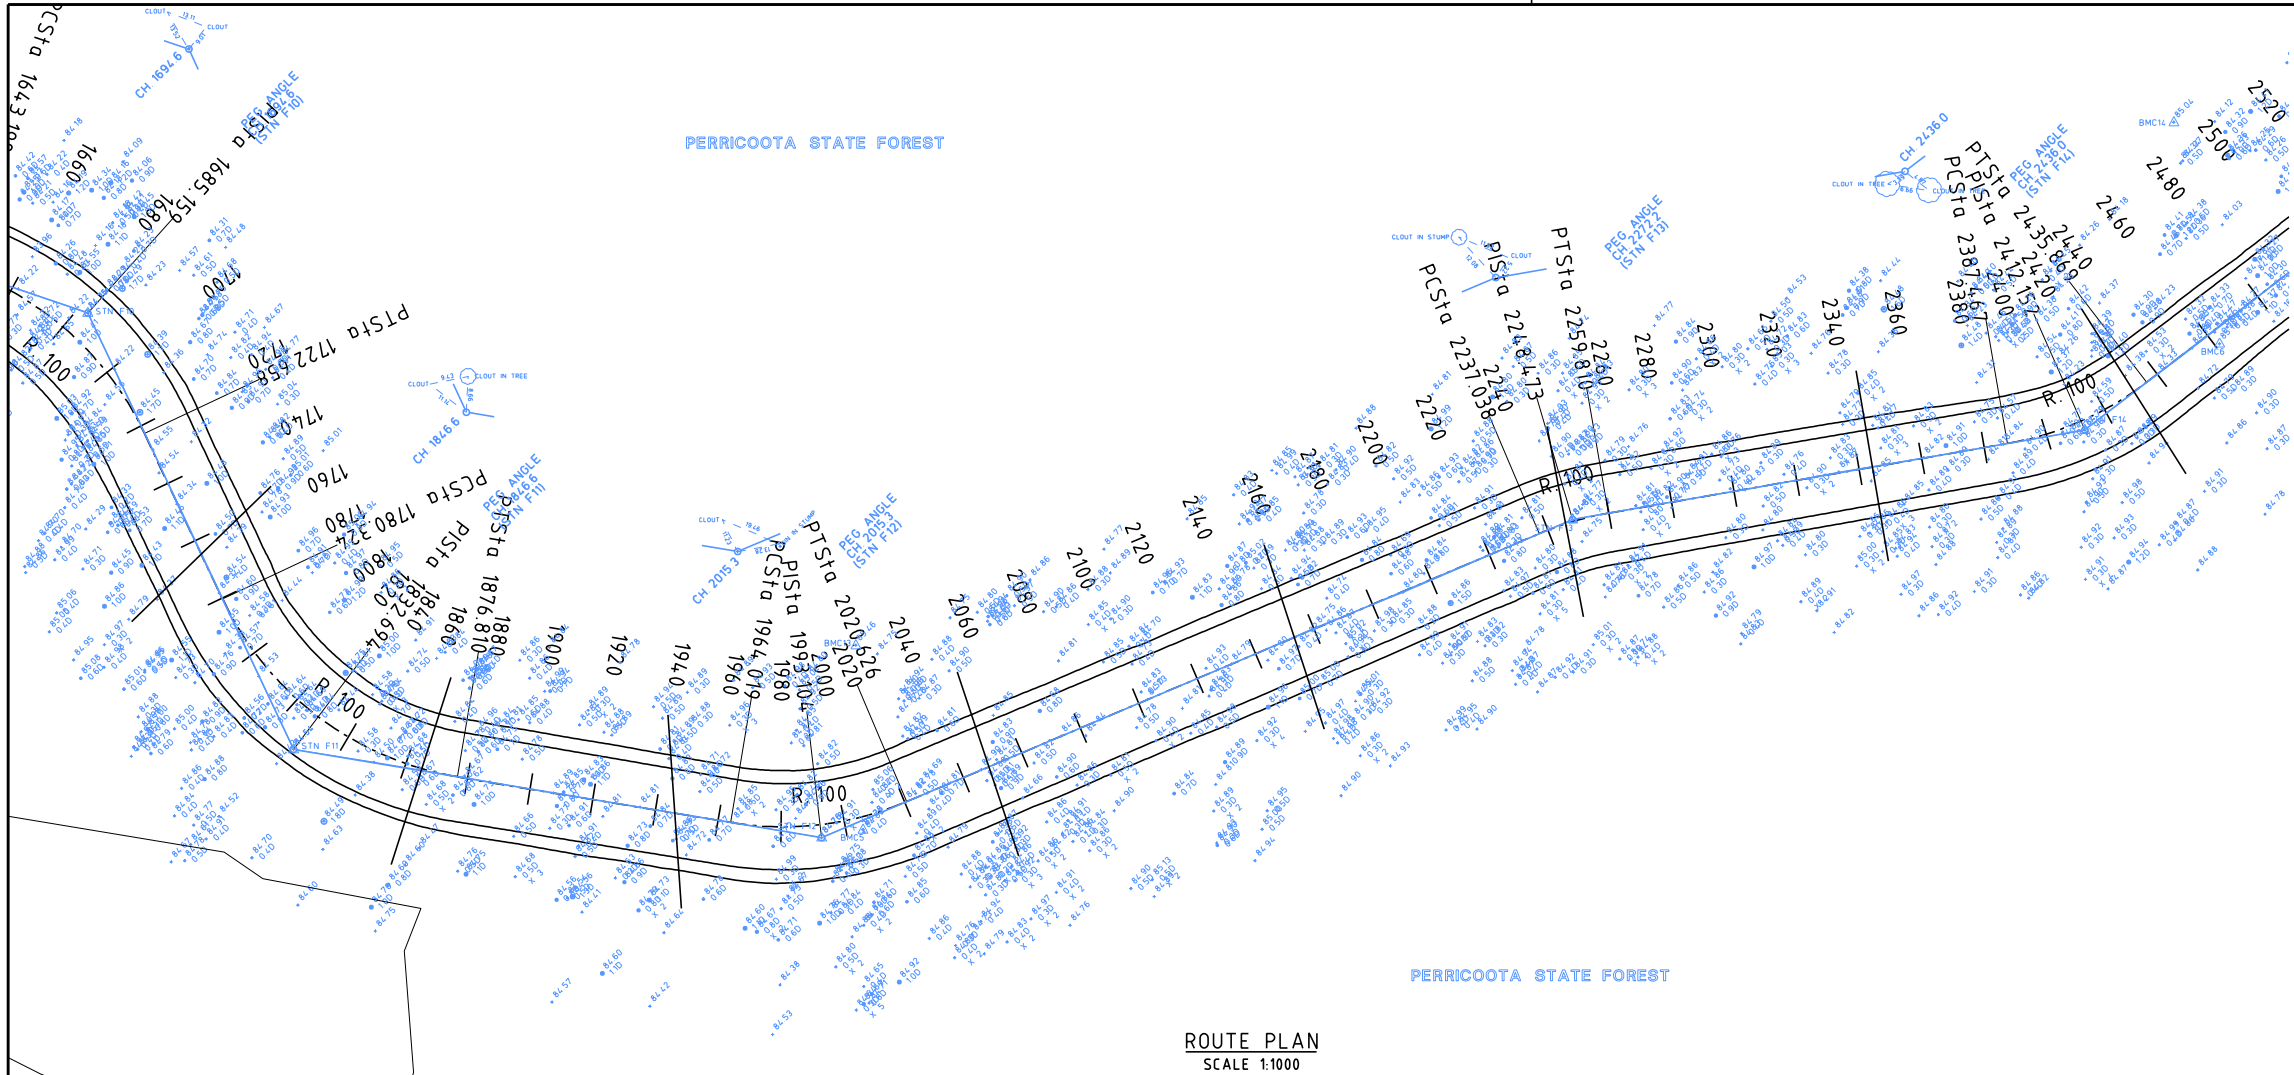

ROUTE PLAN
SCALE 1:1000

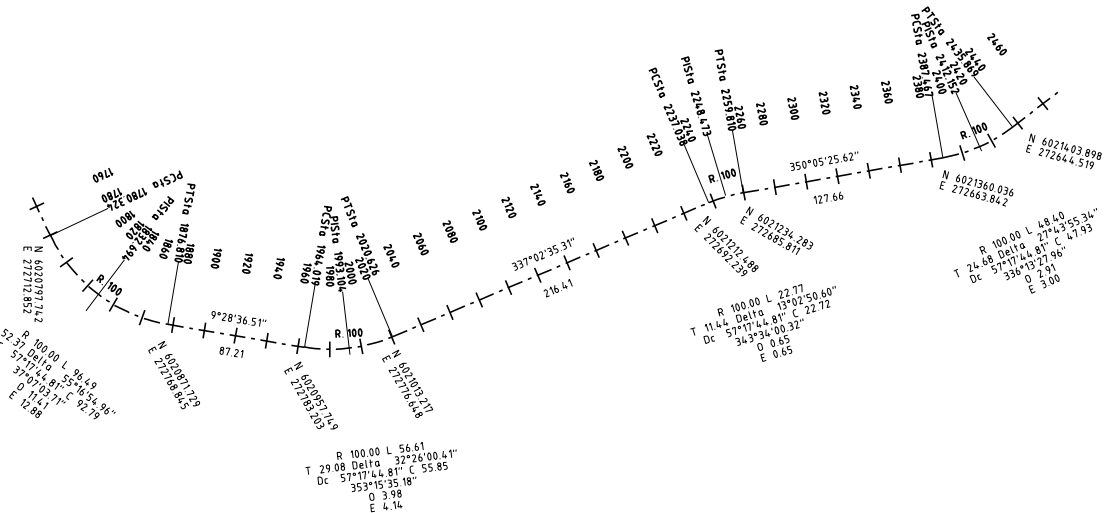 

SETTING OUT DIAGRAM
SCALE 1:2000

 

DRAFT COPY

GRAEME HEAD - Director General
Department of Services, Technology and Administration
NSW WATER SOLUTIONS
DAMS AND CIVIL TECHNOLOGIES
LEVEL 13, MCKELL BUILDING
2-24 RAWSON PLACE
SYDNEY 2000
PHONE (02) 93727808 FAX (02) 93727822



DESIGNED	SP ENGINEER
A. AGARWAL	G. SAMIOS
DRAFTED	G.M. DAMS AND CIVIL TECHNOLOGIES
D.T.	J.R. LENEHAN
CHECKED	
G. SAMIOS	



**KOONDROOK - PERRICOOTA
FLOOD ENHANCEMENT**
**UPSTREAM CHANNEL
ROUTE PLAN**
CH. 1800.0 TO CH. 2400.0

NO IN SET
FILE NO. DCF 6815
DRAWING NO. 4078 - 57
REVISION 0

ISSUED FOR REVIEW.			
DETAILS OF AMENDMENTS	APPROVED	DATE	
MK			

 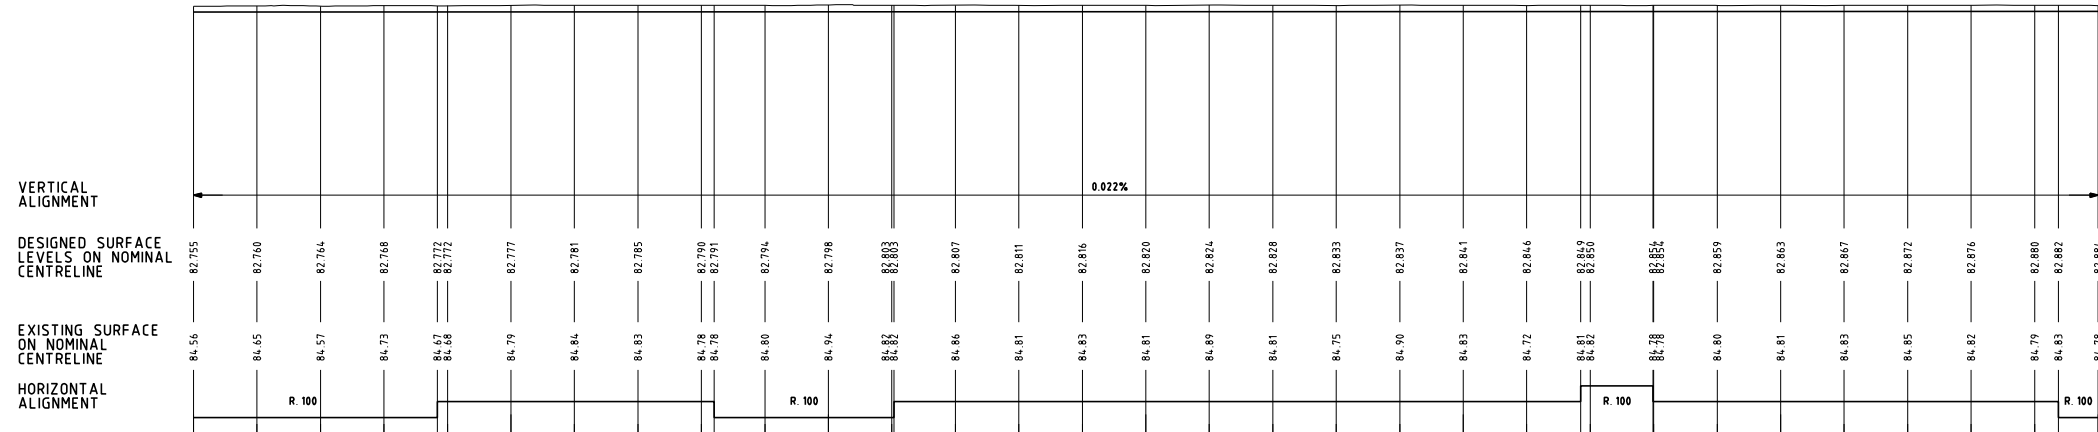

DRAFT COPY


GRAEME HEAD - Director General
Department of Services, Technology and Administration
NSW WATER SOLUTIONS
DAMS AND CIVIL TECHNOLOGIES
LEVEL 13, MCKELL BUILDING
2-24 RAWSON PLACE
SYDNEY 2000
PHONE (02) 93727808 FAX (02) 93727822

PLAN RM NO	
DESIGNED	S.P. ENGINEER
A. AGARWAL	G. SAMIOS
DRAFTED	G.M. DAMS AND CIVIL TECHNOLOGIES
D.T.	J.R. LENEHAN
CHECKED	
G. SAMIOS	




**KOONDROOK - PERRICOOTA
FLOOD ENHANCEMENT**

NO. IN SET
FILE NO. DCF 6815
DRAWING NO. 4078 - 58
REVISION 0

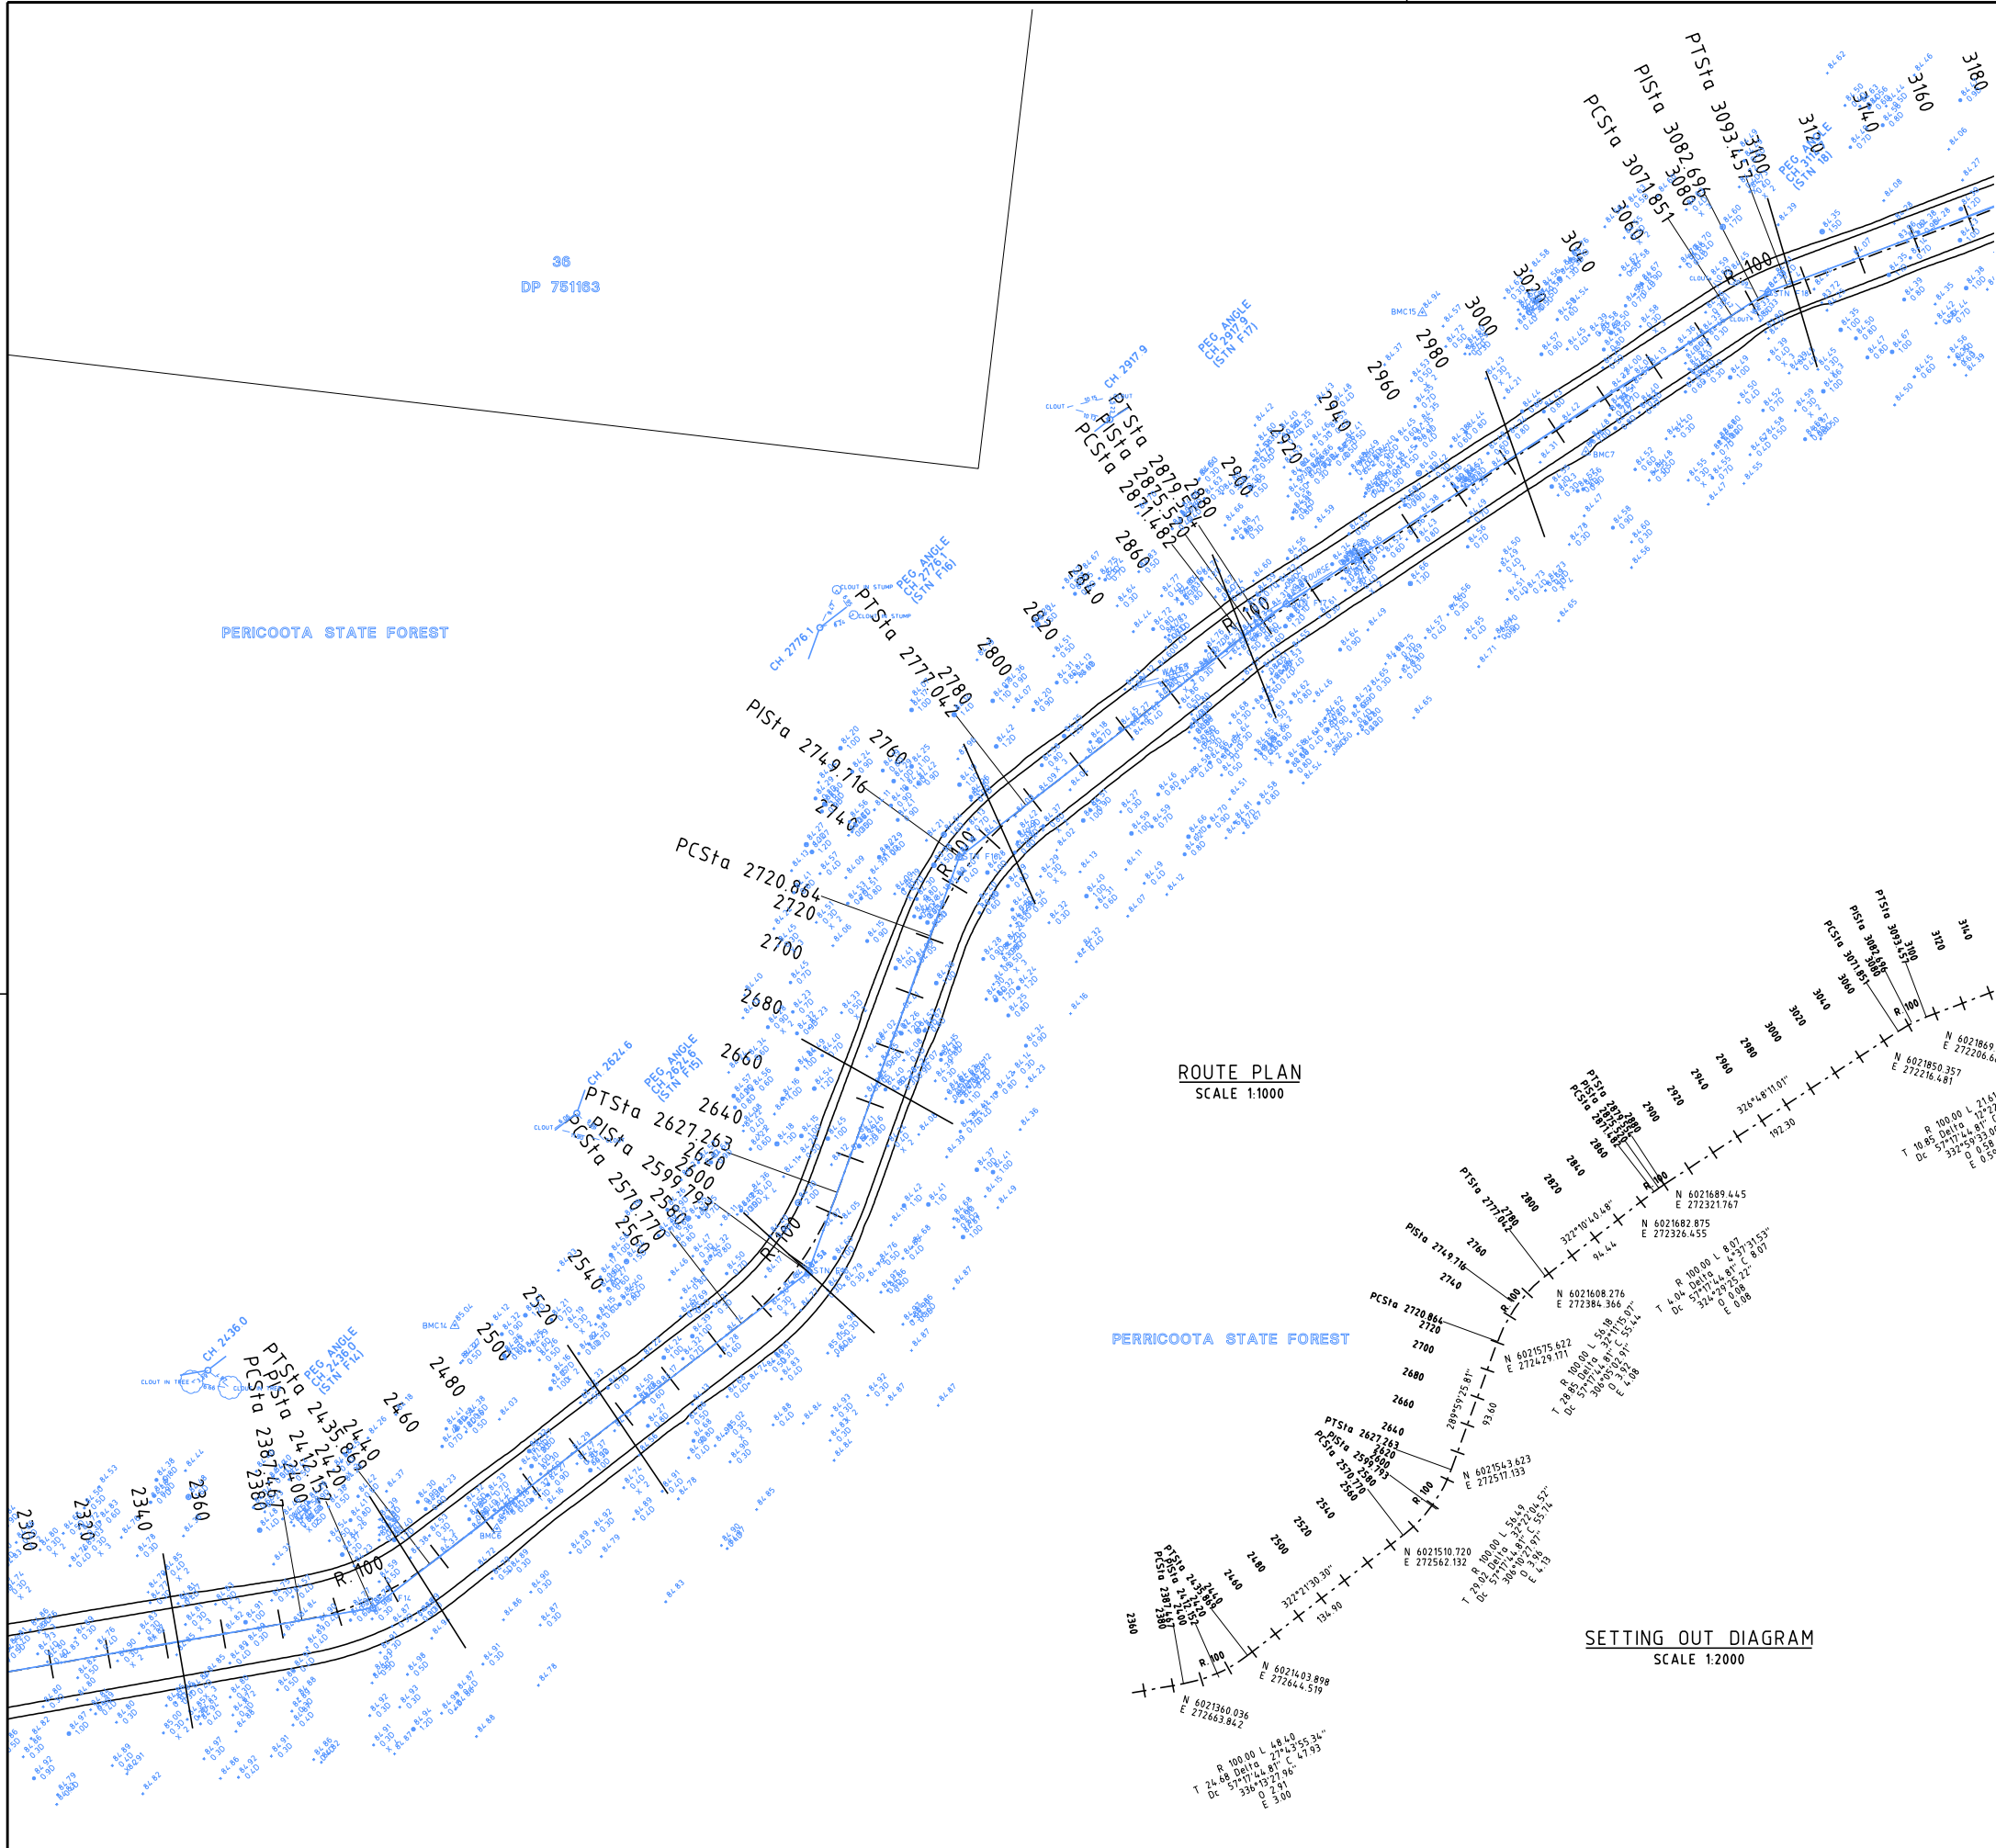

ROUTE PLAN
SCALE 1:1000

 SETTING OUT DIAGRAM
SCALE 1:2000



DRAFT COPY



GRAEME HEAD - Director General
Department of Services, Technology and Administration
NSW WATER SOLUTIONS
DAMS AND CIVIL TECHNOLOGIES
LEVEL 13, McKELL BUILDING
2-24 RAWSON PLACE
SYDNEY 2000
PHONE (02) 93727808 FAX (02) 93727822


PLAN RM NO	
DESIGNED	SP ENGINEER
A. AGARWAL	G. SAMIOS
DRAFTED	G.M. DAMS AND CIVIL TECHNOLOGIES
	J.R. LENEHAN
CHECKED	
G. SAMIOS	



**KOONDROOK - PERRICOOTA
FLOOD ENHANCEMENT**
UPSTREAM CHANNEL
ROUTE PLAN
CH. 2400.0 TO CH. 3000.0

 NO IN SET
FILE NO. DCF 6815
DRAWING NO. 4078 - 59
REVISION 0

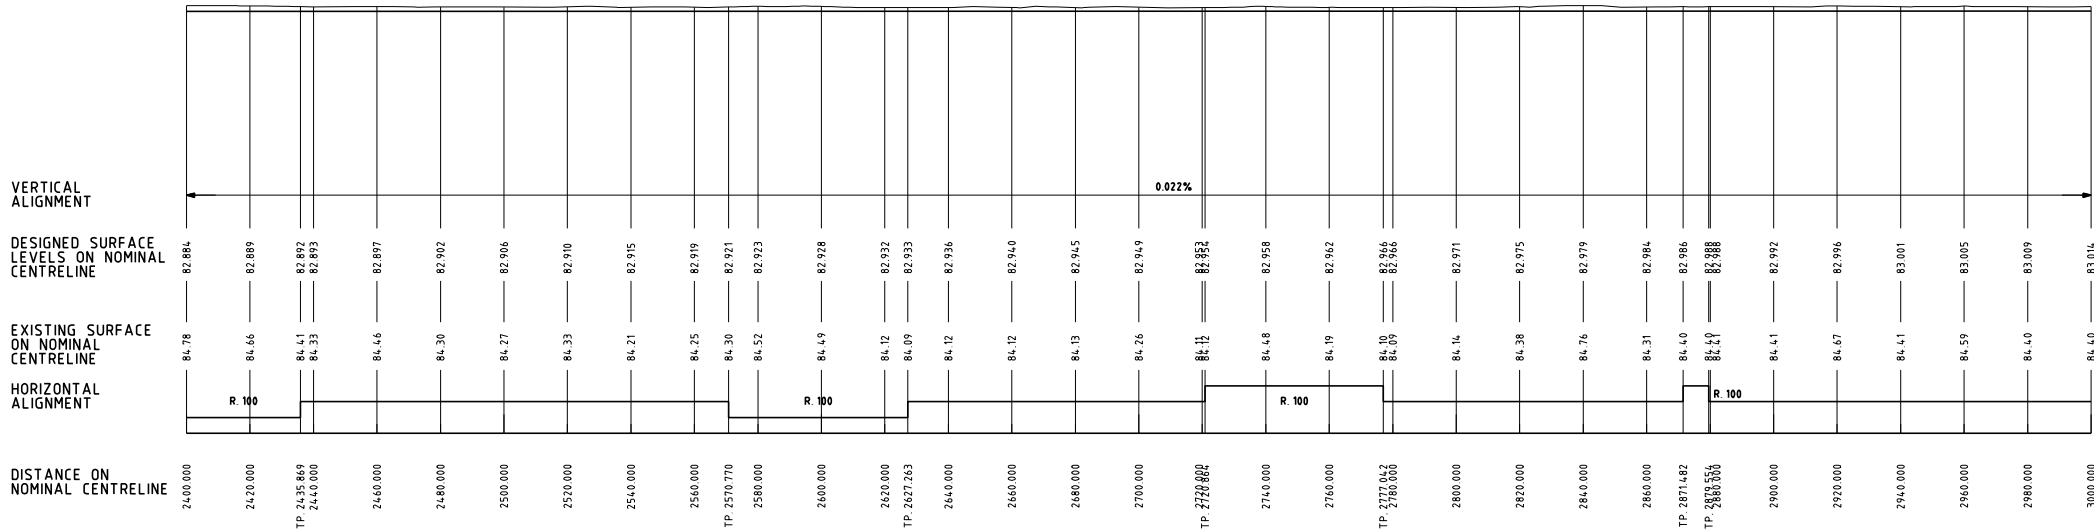

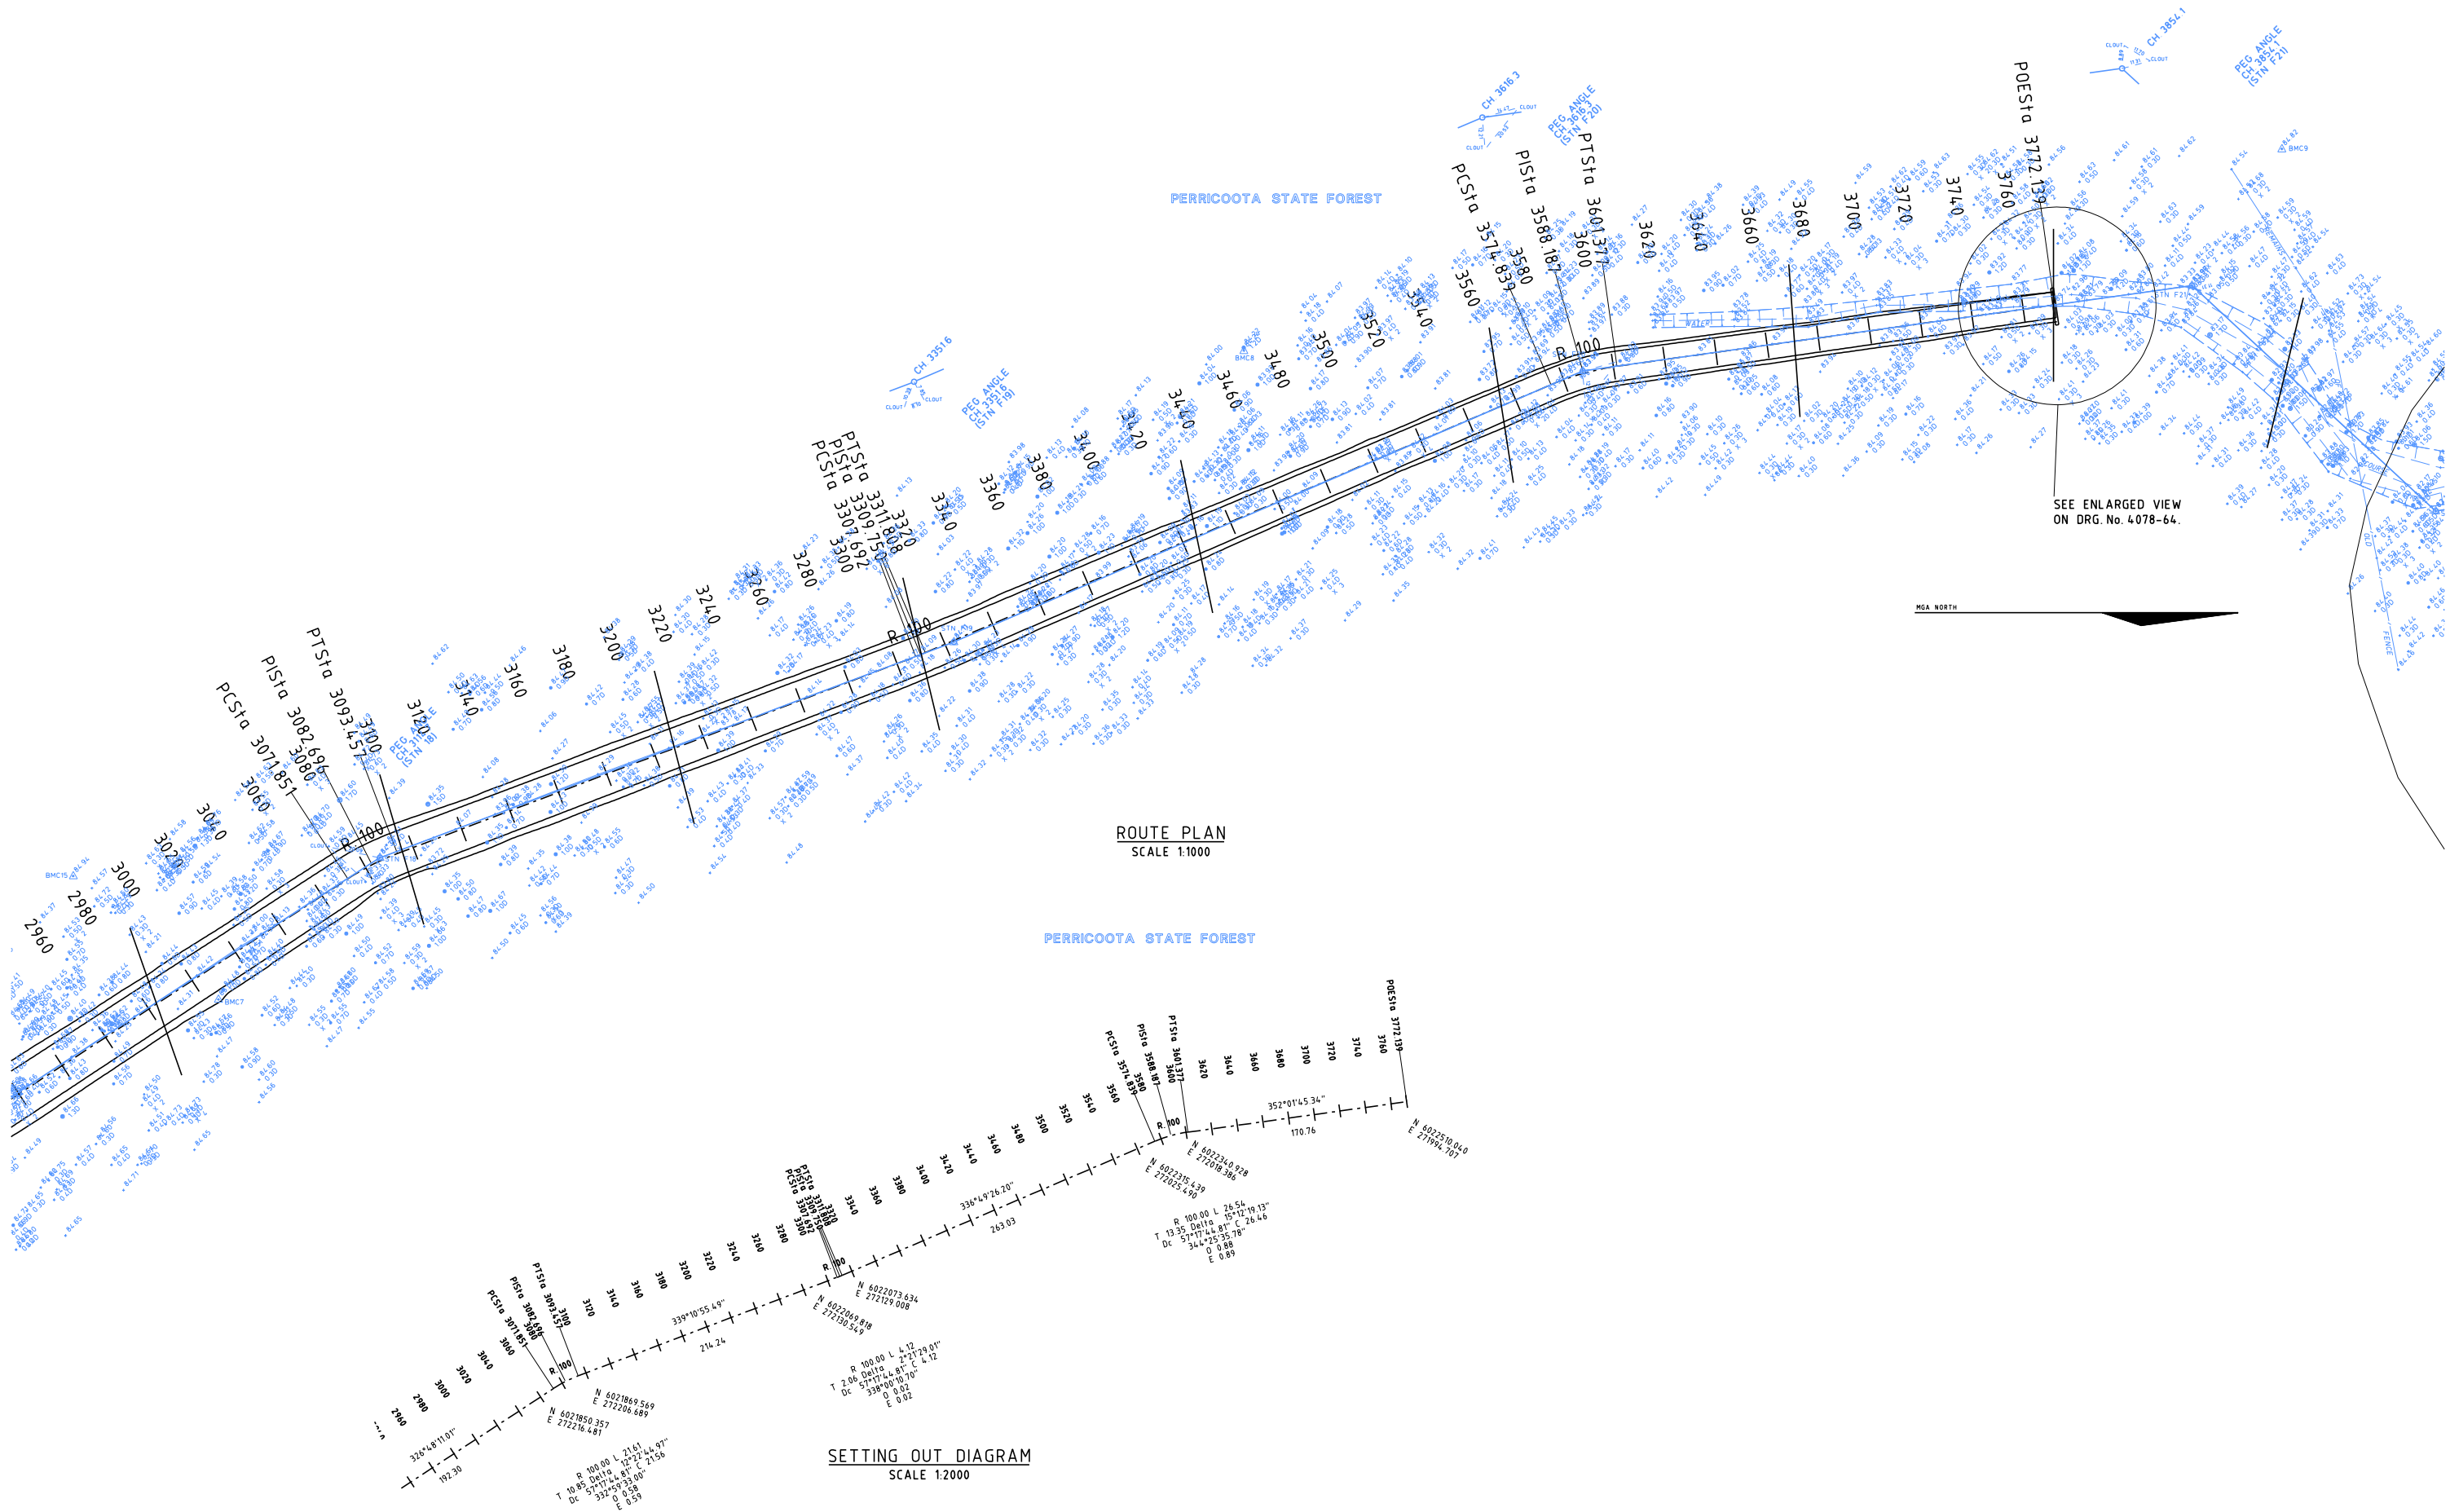


DRAFT COPY

GRAEME HEAD - Director General
Department of Services, Technology and Administration
NSW WATER SOLUTIONS
DAMS AND CIVIL TECHNOLOGIES
LEVEL 13, MCKELL BUILDING
2-24 RAWSON PLACE
SYDNEY 2000
PHONE (02) 93727808 FAX (02) 93727822

PLAN RM NO	
DESIGNED	SP ENGINEER
A. AGARWAL	G. SAMIOS
DRAFTED	G.M DAMS AND CIVIL TECHNOLOGIES
D.T.	J.R. LENEHAN
CHECKED	
G. SAMIOS	



KOONDROOK - PERRICOOTA FLOOD ENHANCEMENT	
UPSTREAM CHANNEL ROUTE PLAN CH. 3000.0 TO CH. 3772.139	
NO IN SET FILE NO. DCF 6815	DRAWING NO. 4078 - 61
REVISION 0	

 

GRAEME HEAD - Director General
Department of Services, Technology and Administration
NSW WATER SOLUTIONS
DAMS AND CIVIL TECHNOLOGIES
LEVEL 13, MCKELL BUILDING
2-24 RAWSON PLACE
SYDNEY 2000
PHONE (02) 93727808 FAX (02) 93727822


PLAN RM NO	
DESIGNED	S.P. ENGINEER
A. AGARWAL	G. SAMIOS
DRAFTED	G.M. DAMS AND CIVIL TECHNOLOGIES
D.T.	J.R. LENEHAN
CHECKED	
G. SAMIOS	




**KOONDROOK – PERRICOO
FLOOD ENHANCEMENT**

NO IN SET
FILE NO. DCF 6815
DRAWING NO. 4078 - 62
REVISION 0


MGA NORTH

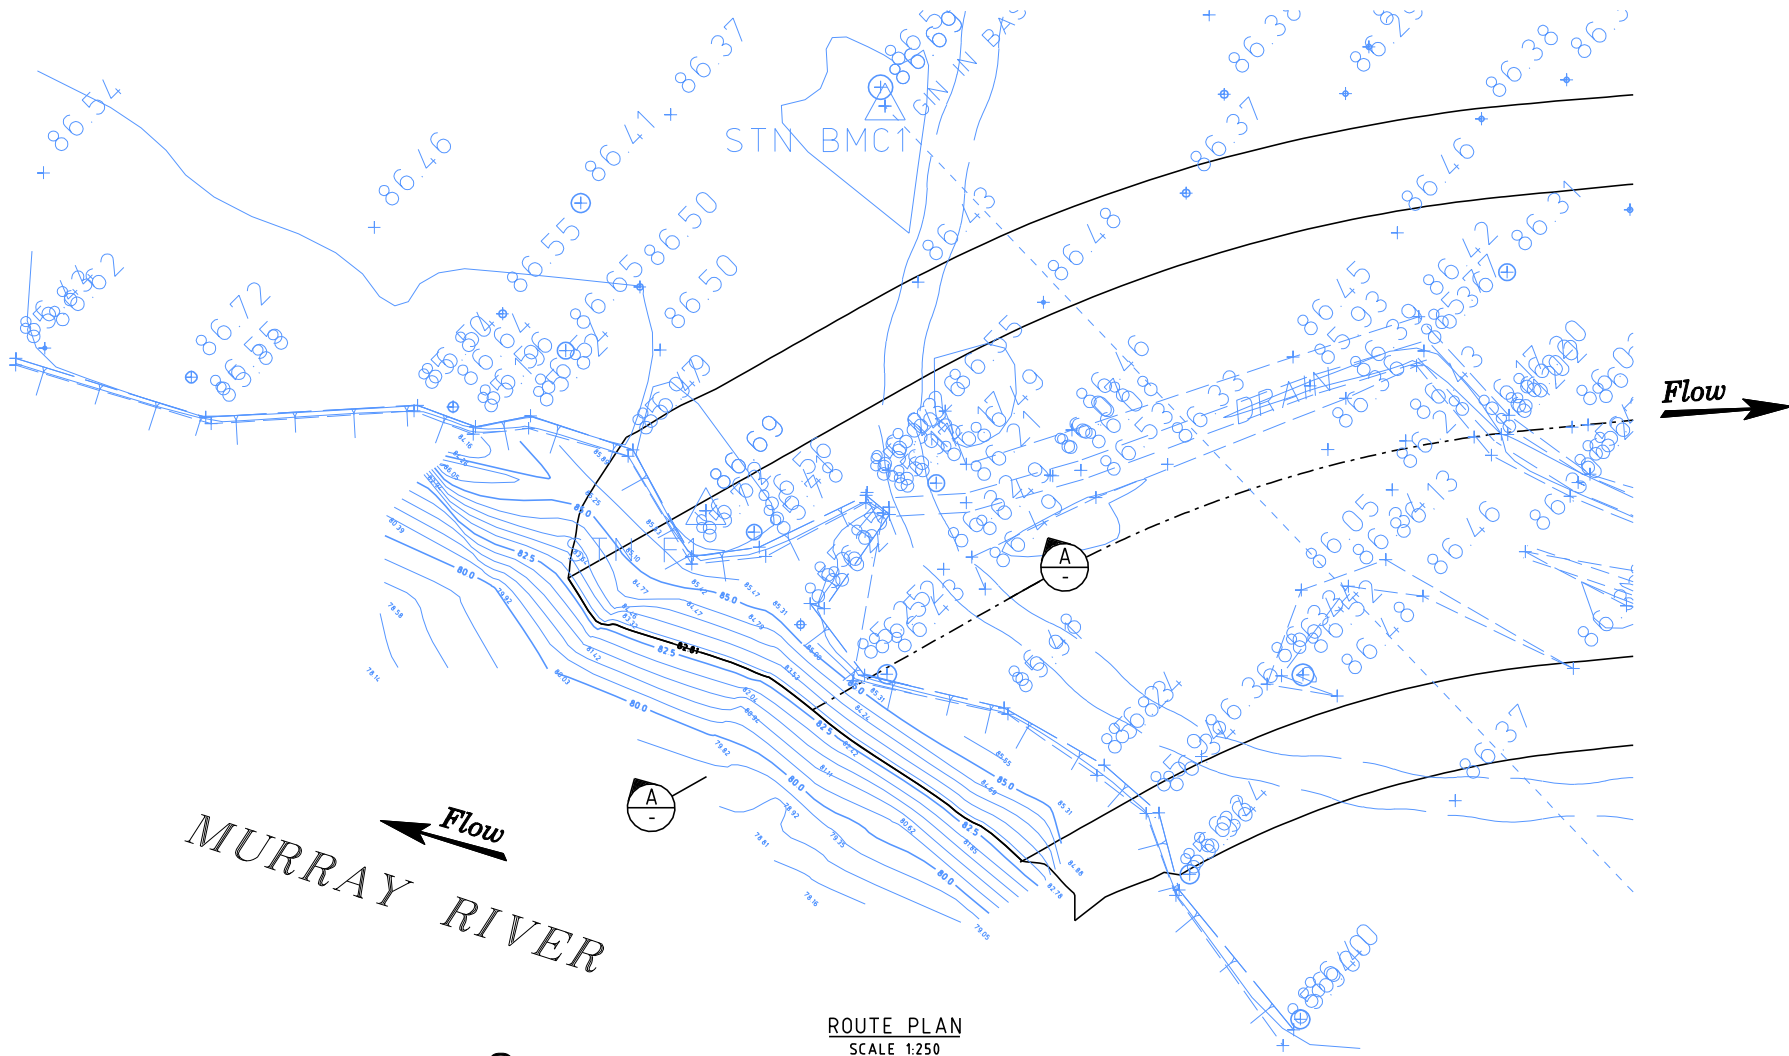

ROUTE PLAN
SCALE 1:250

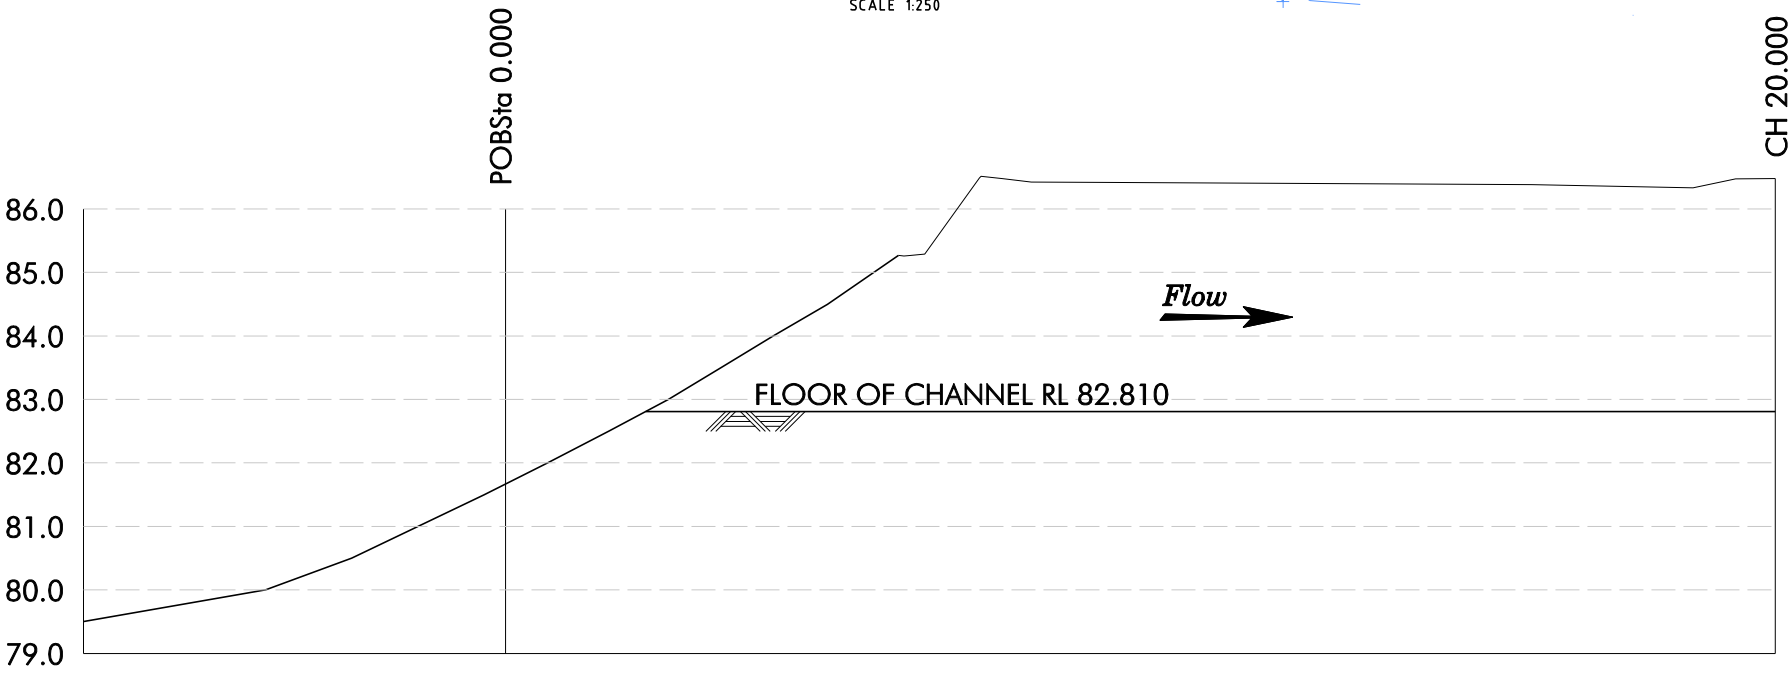

SECTION A-A
SCALE 1:50

 

9/02/2010 2:38:48 PM MaloneD2 G:\NSW\Water\tec\Pcod\KOONDROOK\DESIGN_09\UPSTREAM STRUCTURES\4078-063.dgn

479

B1

960

© CROWN COPYRIGHT NSW MINISTER FOR COMMENCE

1100

1200

1300


GRAEME HEAD - Director General
Department of Services, Technology and Administration
NSW WATER SOLUTIONS
DAMS AND CIVIL TECHNOLOGIES
LEVEL 13, MCKELL BUILDING
2-24 RAWSON PLACE
SYDNEY 2000
PHONE (02) 93727808 FAX (02) 93727822

DESIGNED	G. SAMIOS
DRAFTED	D.J. MALONE
CHECKED	G. SAMIOS


PLAN RM NO	G.M. DAMS AND CIVIL TECHNOLOGIES
DESIGNED	J.R. LENEHAN




KOONDROOK - PERRICOOTA FLOOD ENHANCEMENT	
UPSTREAM STRUCTURES RIVER INLET	
NO IN SET	FILE NO. DCF 6815
DRAWING NO. 4078 - 063	REVISION 0

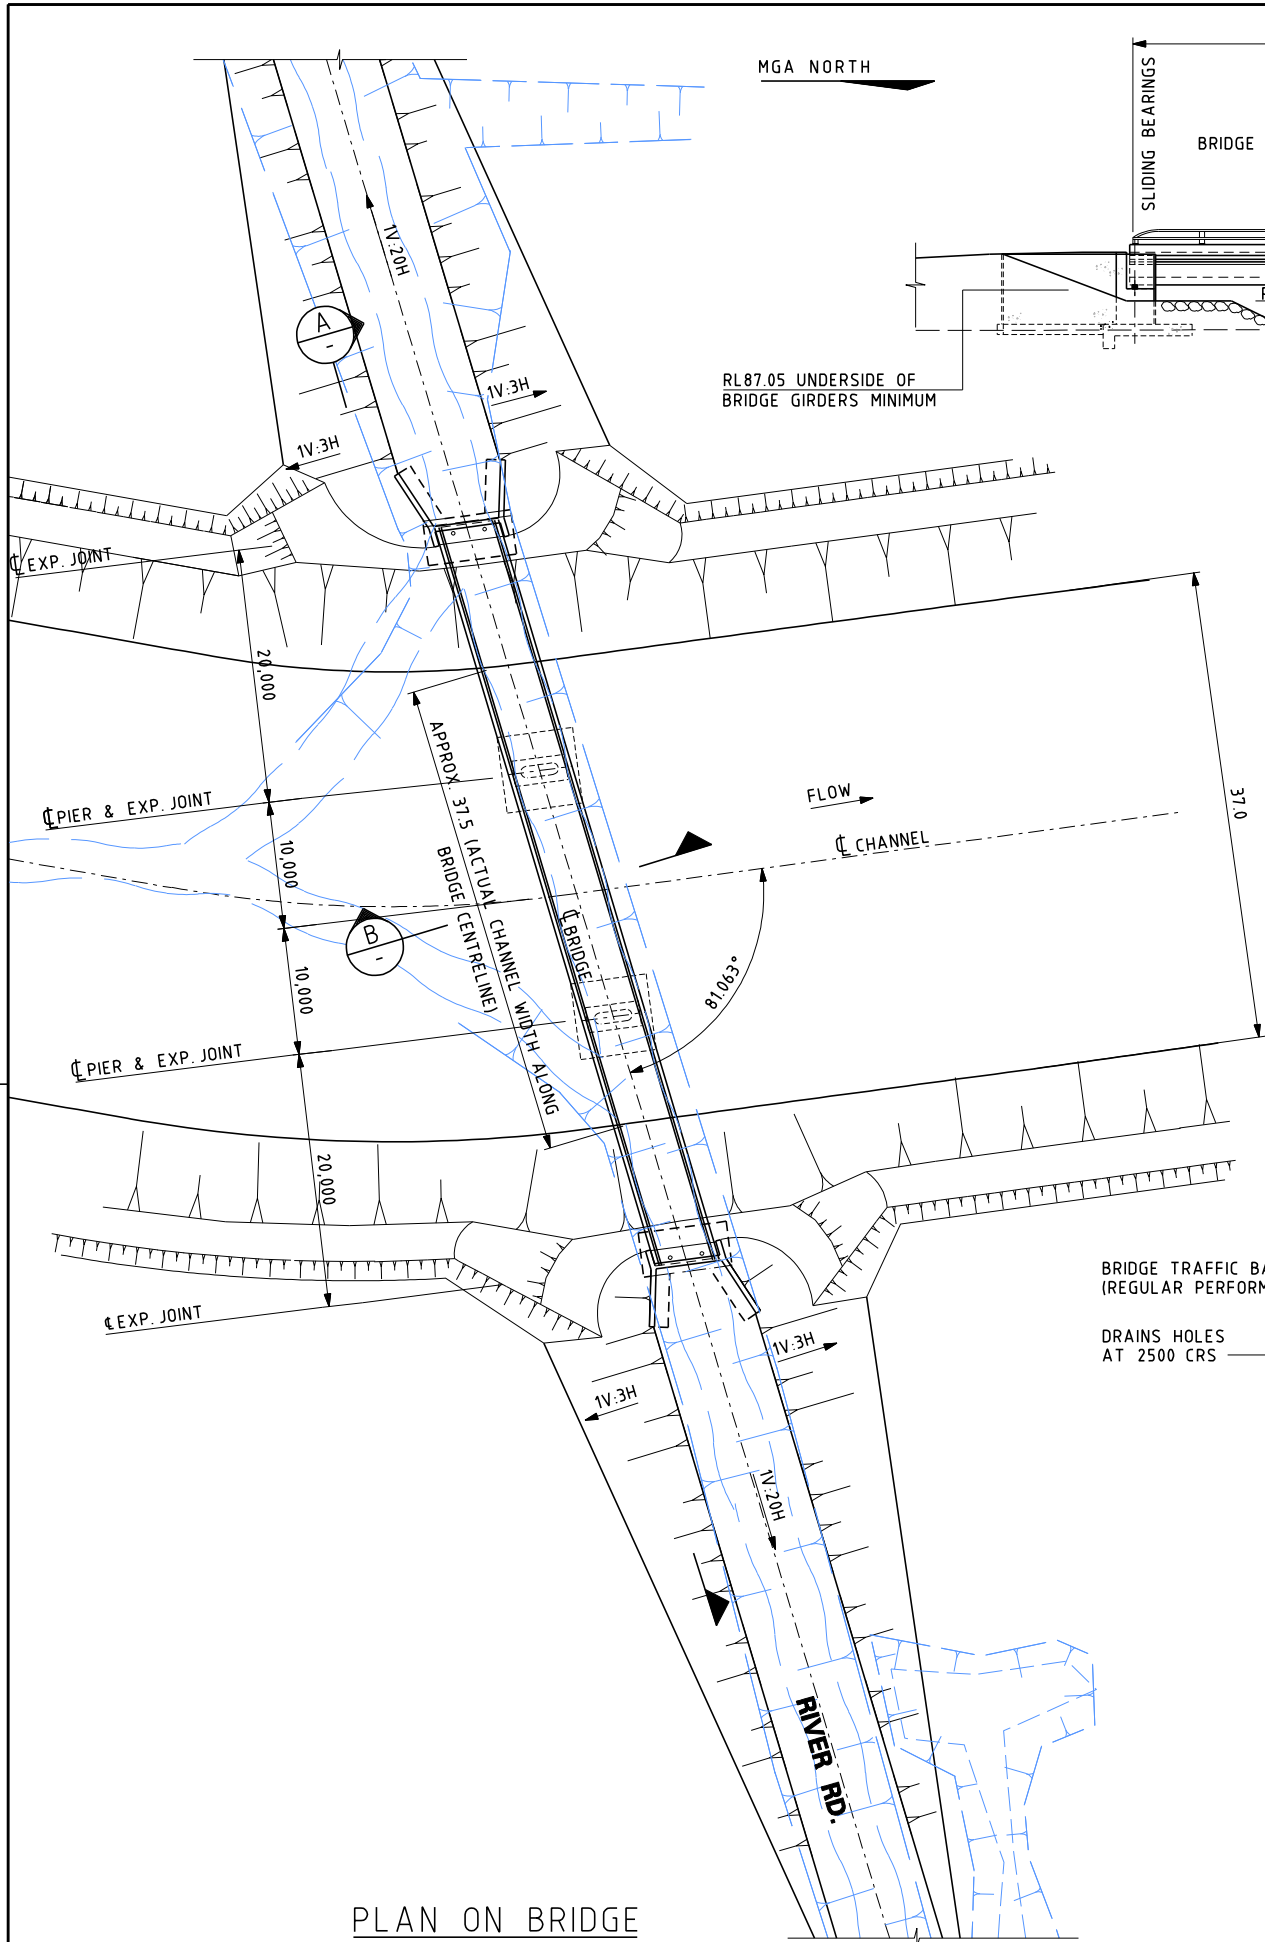


PLAN ON BRIDGE
SCALE 1:250

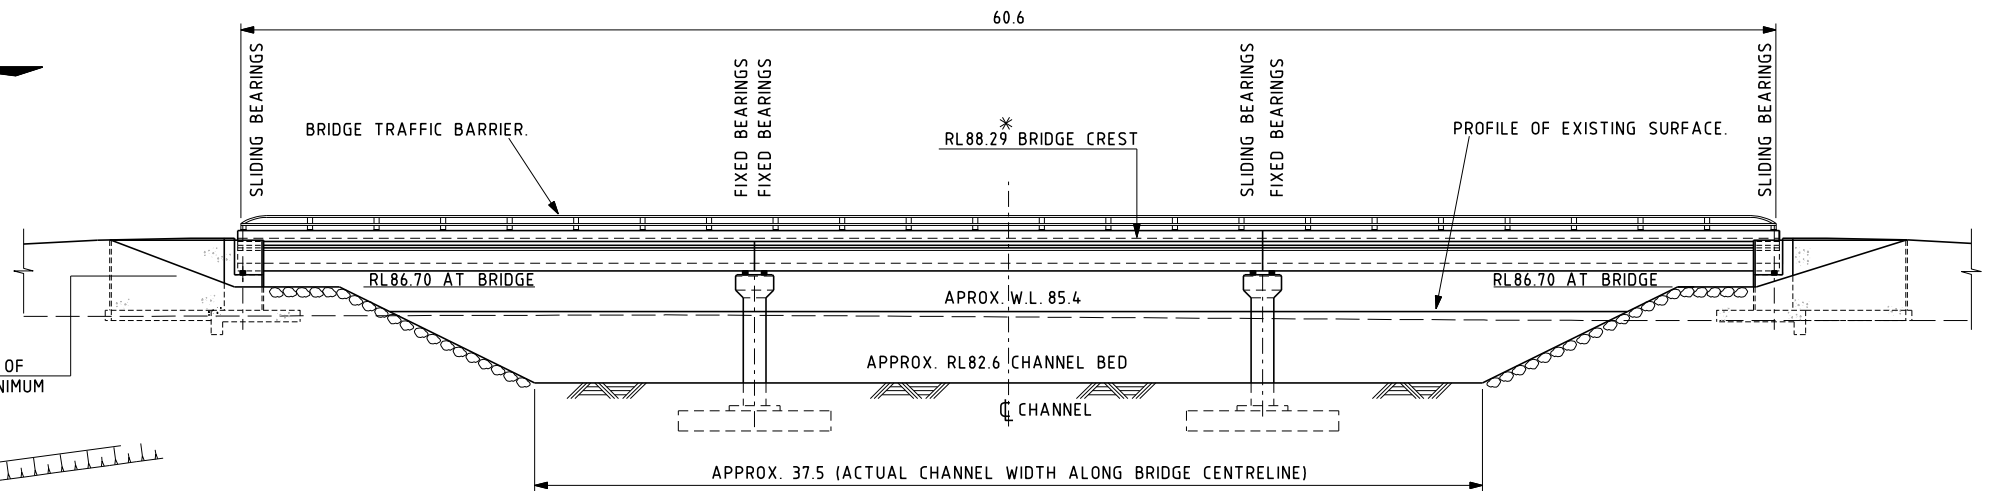

ELEVATION
SCALE 1:125

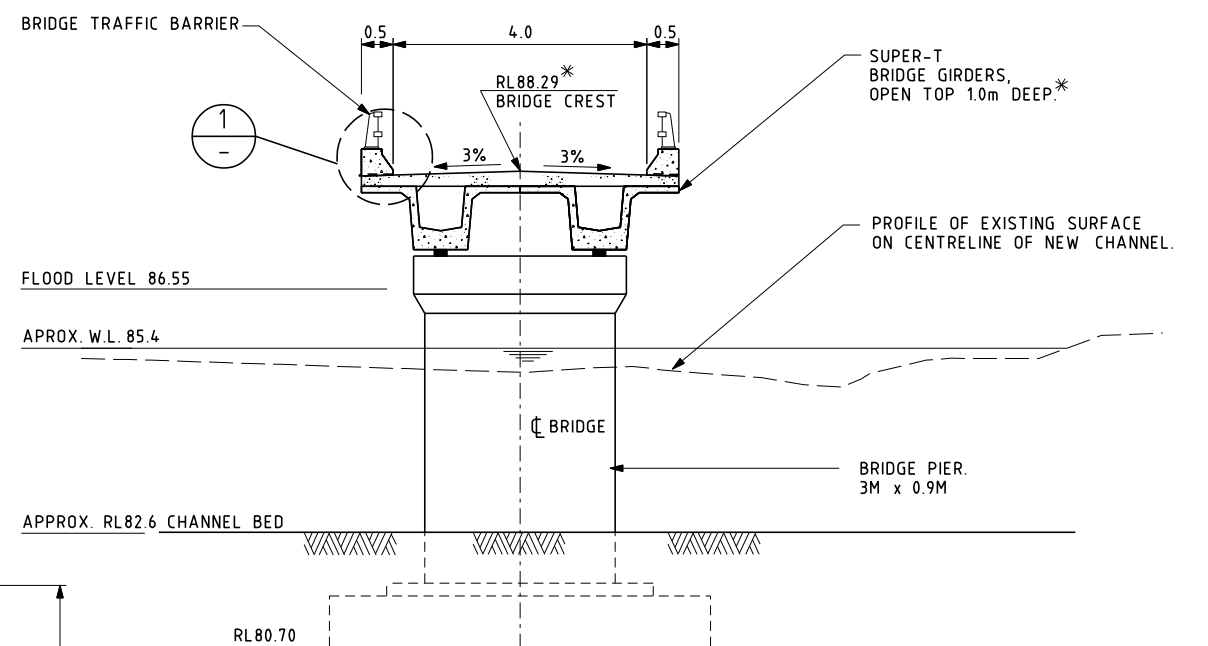


SECTION
SCALE 1:50

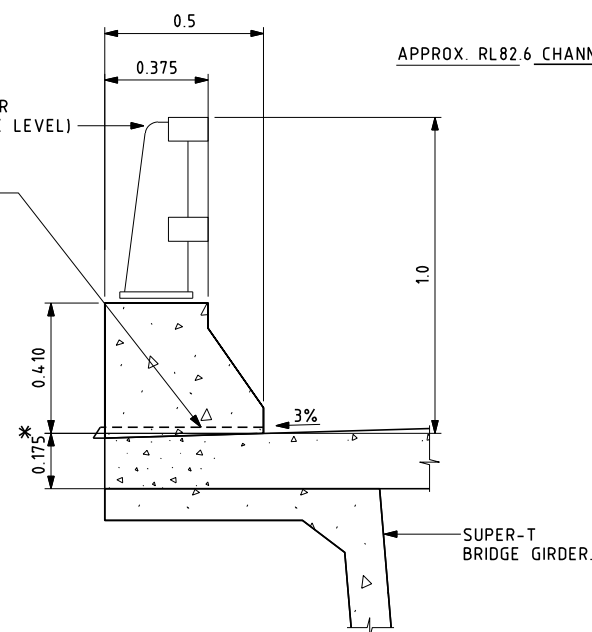

DETAIL
SCALE 1:10

- NOTES:
1. ALL DIMENSIONS ARE IN METRES, UNLESS NOTED OTHERWISE.
 2. DESIGN TO AS5100 BRIDGE DESIGN
 3. MAX DESIGN LOAD T44 TRUCK LOADING AS PER 92 AUSTRROADS BRIDGE DESIGN CODE SECTION 2 (96KN MAX AXLE LOAD)
 4. THE SUPERSTRUCTURE, INCLUDING BEARINGS, GIRDERS, DECK, DECK JOINTS, KERBS AND RAILINGS I.E. TRAFFIC BARRIERS TO BE DESIGNED BY THE CONTRACTOR.
 5. TRAFFIC BARRIER REQUIREMENTS INCLUDING GEOMETRY AND DESIGN LOADING SHALL BE IN ACCORDANCE WITH AS 5100. BARRIER PERFORMANCE SHALL BE 'REGULAR LEVEL'.
 6. SUBMIT BRIDGE DESIGN INCLUDING CALCULATIONS TO THE SUPERINTENDENT FOR APPROVAL. DO NOT COMMENCE CONSTRUCTION UNTIL APPROVALS HAVE BEEN OBTAINED.
 7. DIMENSIONS AND LEVELS MARKED THUS * ARE ASSUMED AND ARE TO BE DETERMINED BY CONTRACTOR PRIOR TO CONSTRUCTION.
 8. PIER FOOTINGS REQUIRE A SAFE BEARING CAPACITY OF 200kPa
 9. ABUTMENT FOOTINGS REQUIRE A SAFE BEARING CAPACITY OF 100kPa

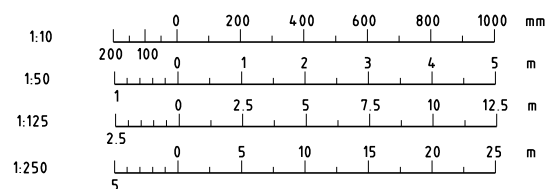

DRAFT COPY

GRAEME HEAD - Director General
Department of Services, Technology and Administration
NSW WATER SOLUTIONS
DAMS AND CIVIL TECHNOLOGIES
LEVEL 13, McKELL BUILDING
2-24 RAWSON PLACE
SYDNEY 2000
PHONE (02) 93727808 FAX (02) 93727822

PLAN RM NO
DESIGNED Y. BOSSON
DRAFTED G. SAMIOS
CHECKED J. R. LENEHAN
B. CLARK




**KOONDROOK - PERRICOOTA
FLOOD ENHANCEMENT**
UPSTREAM STRUCTURES
BRIDGE OVER CHANNEL AT RIVER ROAD
GENERAL ARRANGEMENT


NO IN SET
FILE NO. DCF 6815
DRAWING NO. 4078 - 151
REVISION 0

9/02/2010 2:04:26 PM MaloneD2 g:\is\water\tec\pcad\koondrook\ds_struct\regs ds\pcalf286.dgn


479
B1

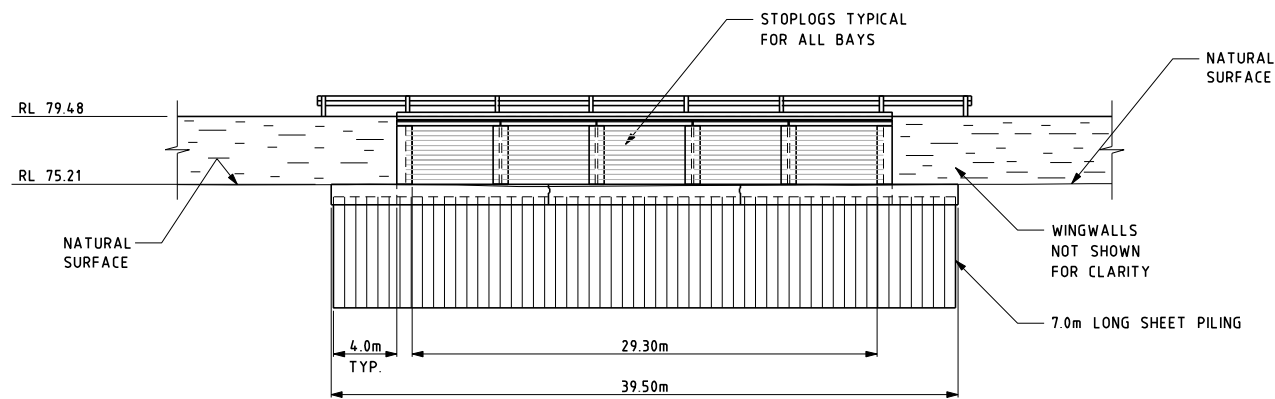


SECTION C
SCALE 1:200

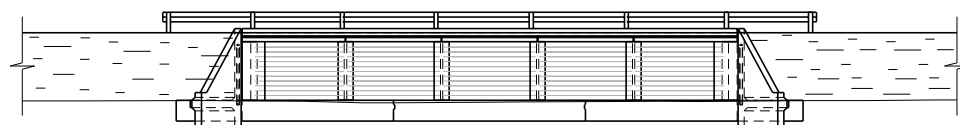


ELEVATION B
SCALE 1:200

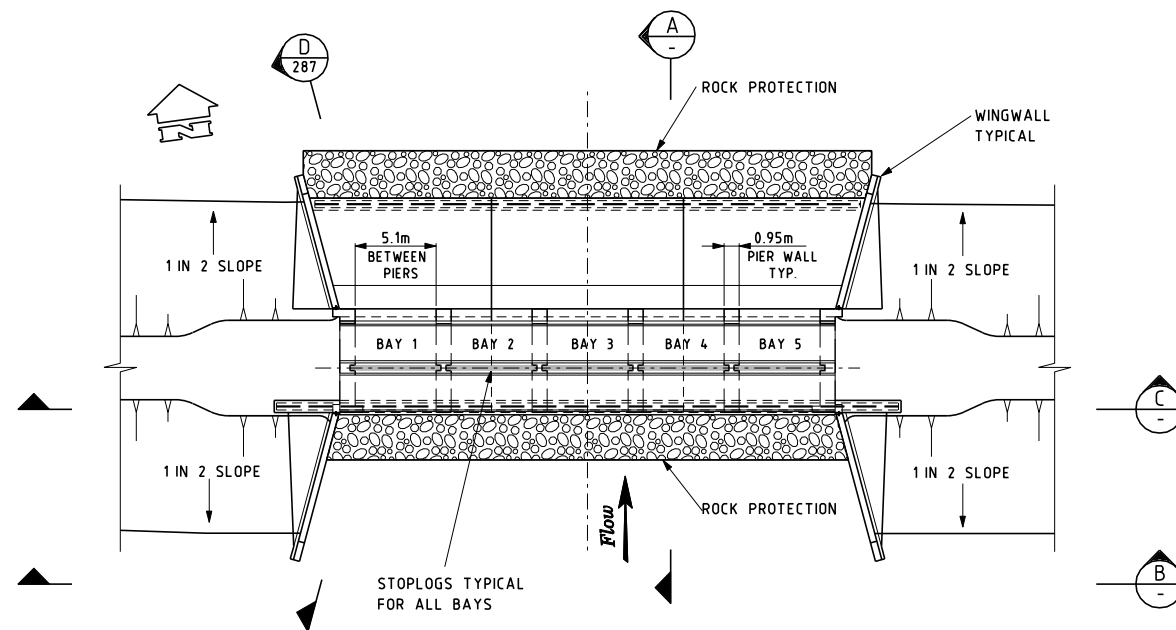

PLAN VIEW ON REGULATOR
SCALE 1:200

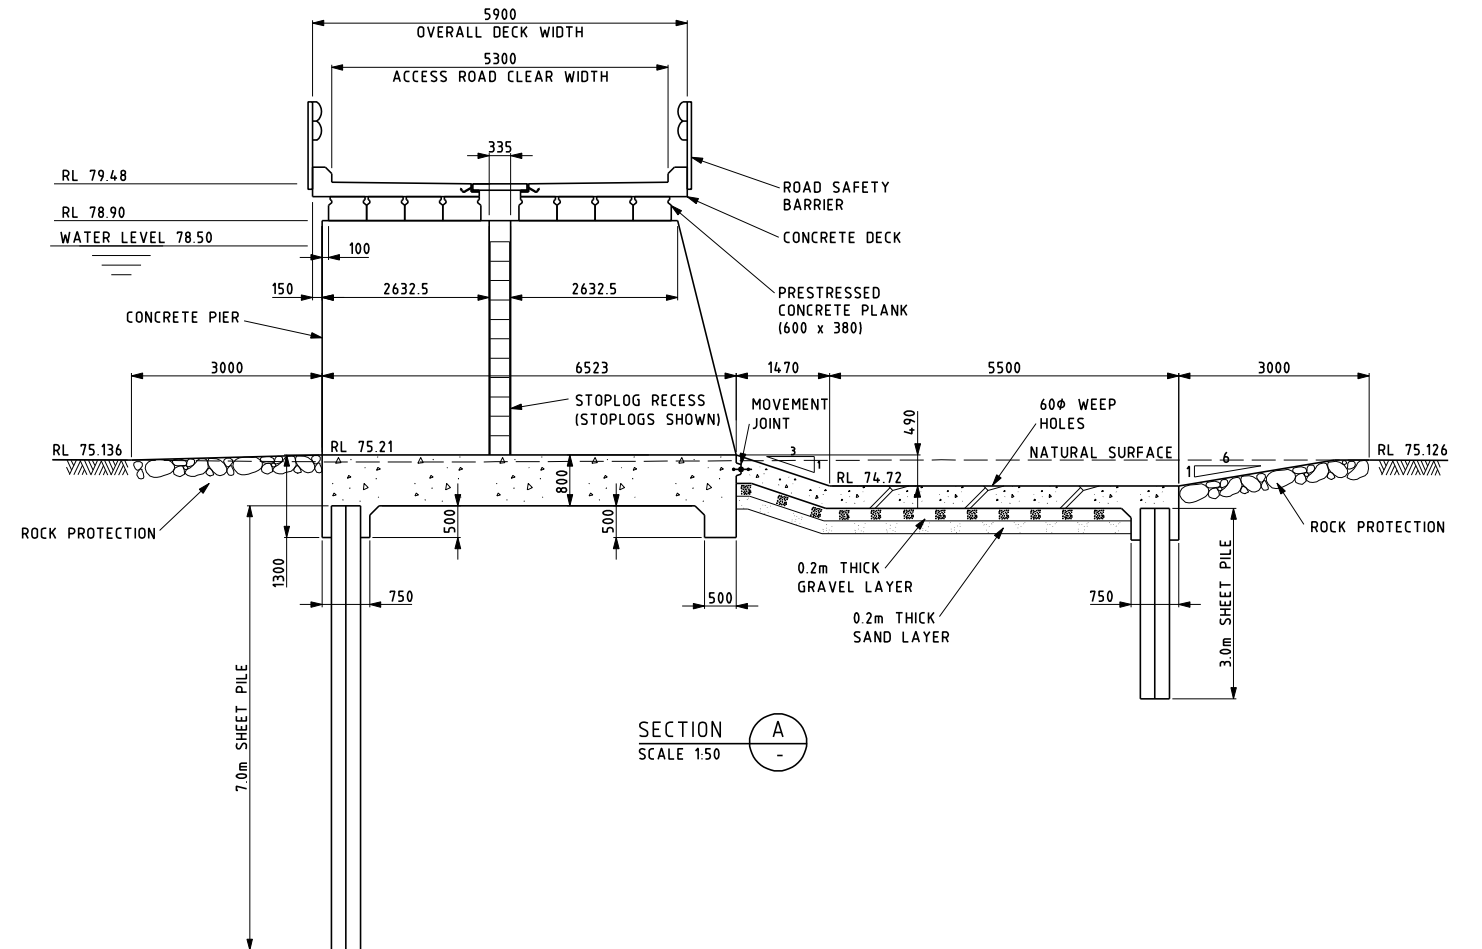

SECTION A
SCALE 1:50

 

DRAFT COPY


GRAEME HEAD - Director General
Department of Services, Technology and Administration
NSW WATER SOLUTIONS
DAMS AND CIVIL TECHNOLOGIES
LEVEL 13, McKELL BUILDING
2-24 RAWSON PLACE
SYDNEY 2000
PHONE (02) 93727808 FAX (02) 93727822

PLAN RM NO
DESIGNED A. UN-NABI
DRAFTED D.J. MALONE
CHECKED G. SAMIOS
S.P. ENGINEER G. SAMIOS
G.M. DAMS AND CIVIL TECHNOLOGIES
J.R. LENEHAN




**KOONDROOK - PERRICOOTA
FLOOD ENHANCEMENT**
DOWNSTREAM STRUCTURES
CALF CREEK REGULATOR
GENERAL ARRANGEMENT - Sheet 1 of 2


NO IN SET
FILE NO. DCF 6815
DRAWING NO. 4078 - 286
REVISION 0

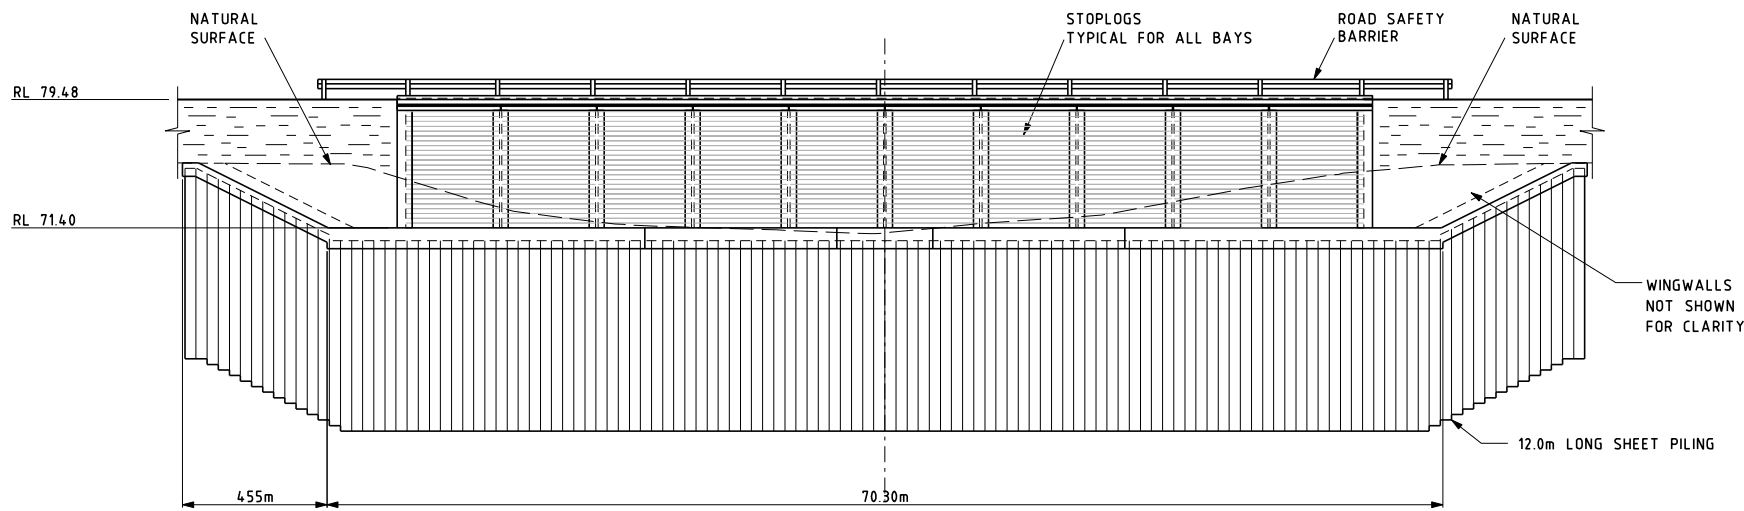


SECTION C
SCALE 1:200

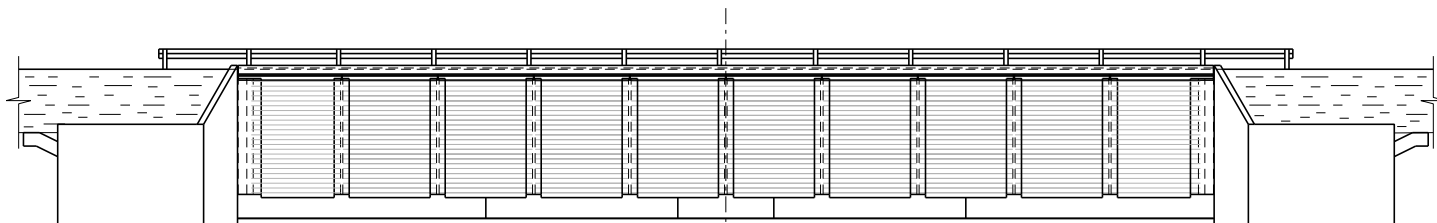

ELEVATION B
SCALE 1:200

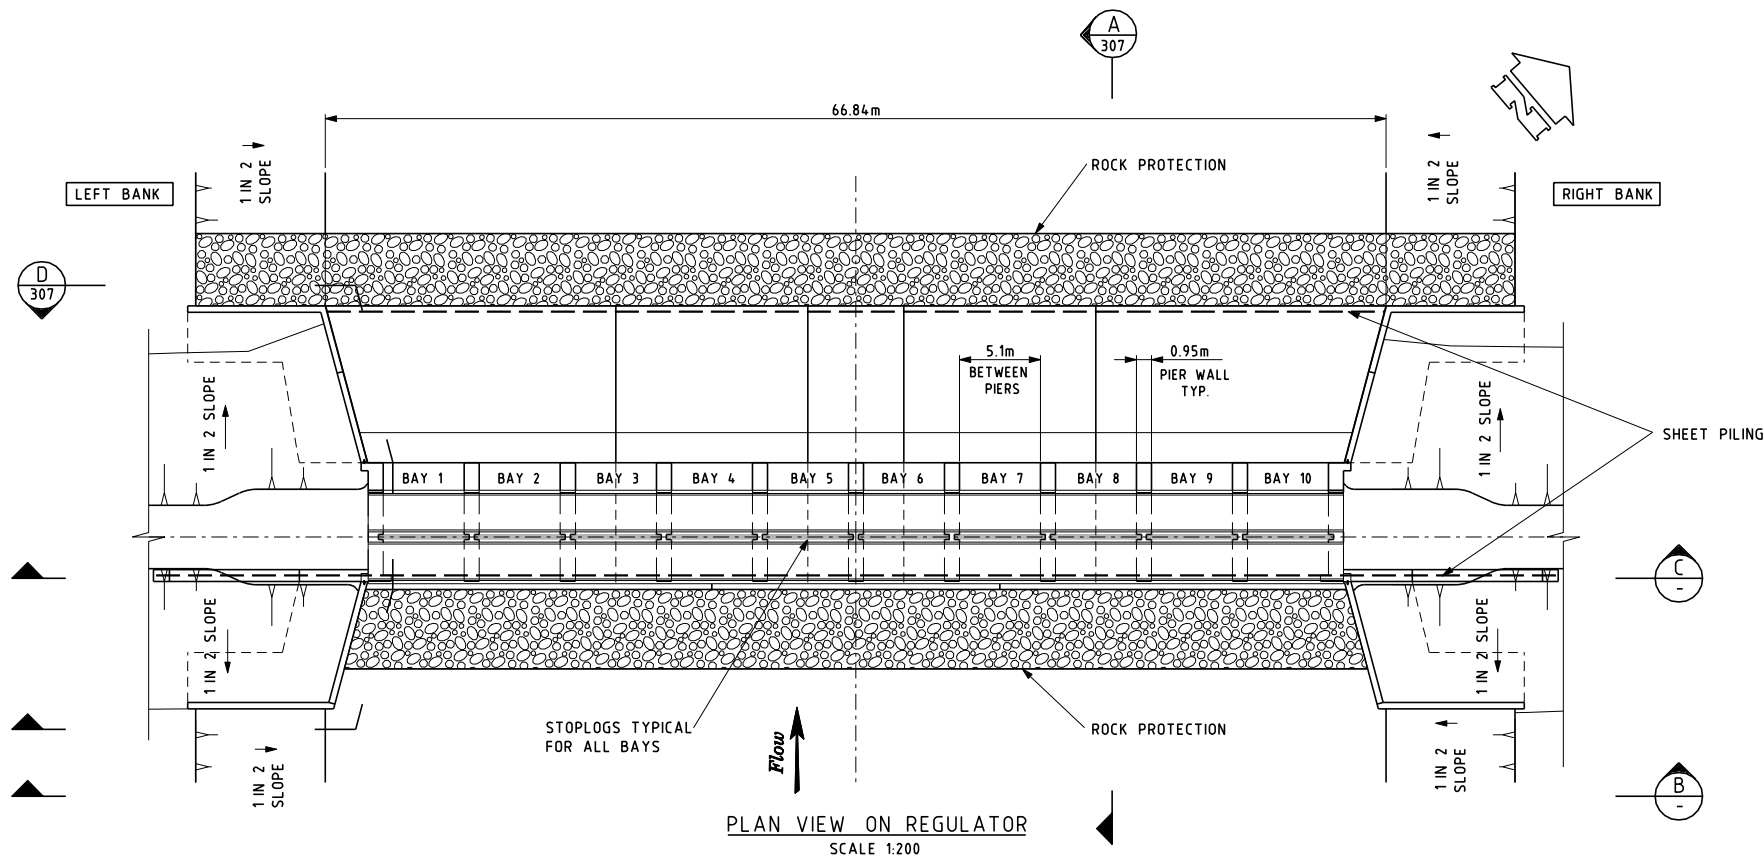

PLAN VIEW ON REGULATOR
SCALE 1:200

 

DRAFT COPY

GRAEME HEAD - Director General
Department of Services, Technology and Administration
NSW WATER SOLUTIONS
DAMS AND CIVIL TECHNOLOGIES
LEVEL 13, McKELL BUILDING
2-24 RAWSON PLACE
SYDNEY 2000
PHONE (02) 93727808 FAX (02) 93727822

DESIGNED	S.P. ENGINEER
A. UN-NABI	G. SAMIOS
DRAFTED	G.M. DAMS AND CIVIL TECHNOLOGIES
D.J. MALONE	J.R. LENEHAN
CHECKED	
G. SAMIOS	



**KOONDROOK - PERRICOOTA
FLOOD ENHANCEMENT**
DOWNSTREAM STRUCTURES
COW CREEK REGULATOR
GENERAL ARRANGEMENT - Sheet 1 of 3

FILE NO.	DCF 6815
DRAWING NO.	4078 - 306
REVISION	0

g:\is\water\tec\pcad\koondrook\ds_struct\regs ds\pcow307.dgn



MaloneD2

2:04:28 PM

9/02/2010

479

 B1

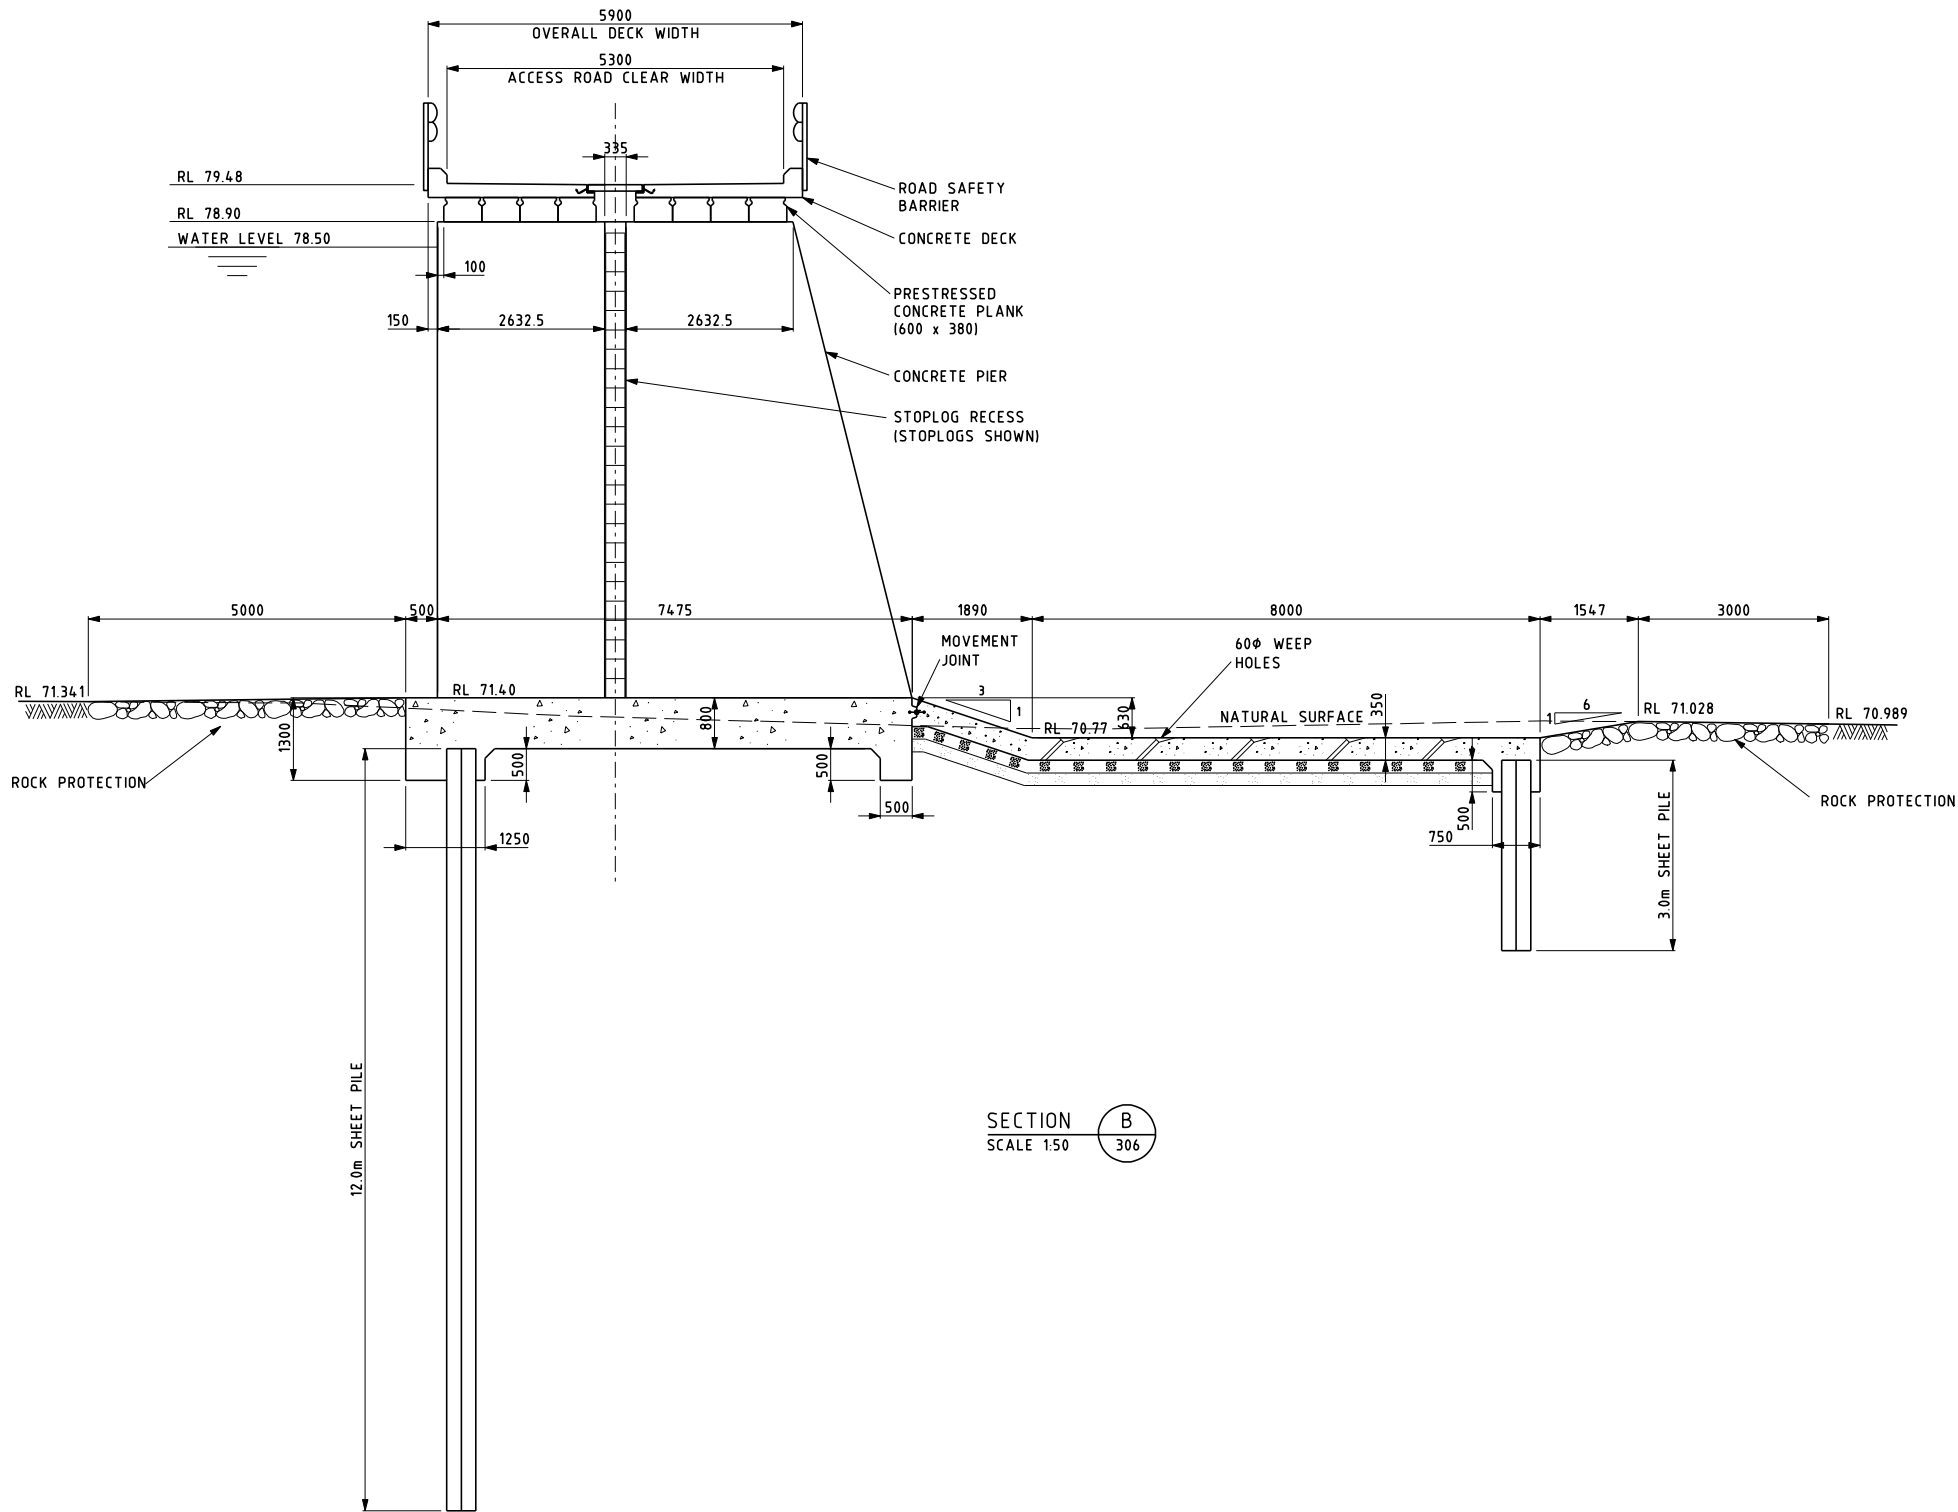

DRAFT COPY


GRAEME HEAD - Director General
Department of Services, Technology and Administration
NSW WATER SOLUTIONS
DAMS AND CIVIL TECHNOLOGIES
LEVEL 13, McKELL BUILDING
2-24 RAWSON PLACE
SYDNEY 2000
PHONE (02) 93727808 FAX (02) 93727822

PLAN RM NO	
DESIGNED	S.P. ENGINEER
A. UN-NABI	G. SAMIOS
DRAFTED	G.M. DAMS AND CIVIL TECHNOLOGIES
D.J. MALONE	J.R. LENEHAN
CHECKED	
G. SAMIOS	




**KOONDROOK - PERRICOOTA
FLOOD ENHANCEMENT**
DOWNSTREAM STRUCTURES
COW CREEK REGULATOR
GENERAL ARRANGEMENT - Sheet 2 of 3

NO IN SET
FILE NO. DCF 6815
DRAWING NO. 4078 - 307
REVISION 0

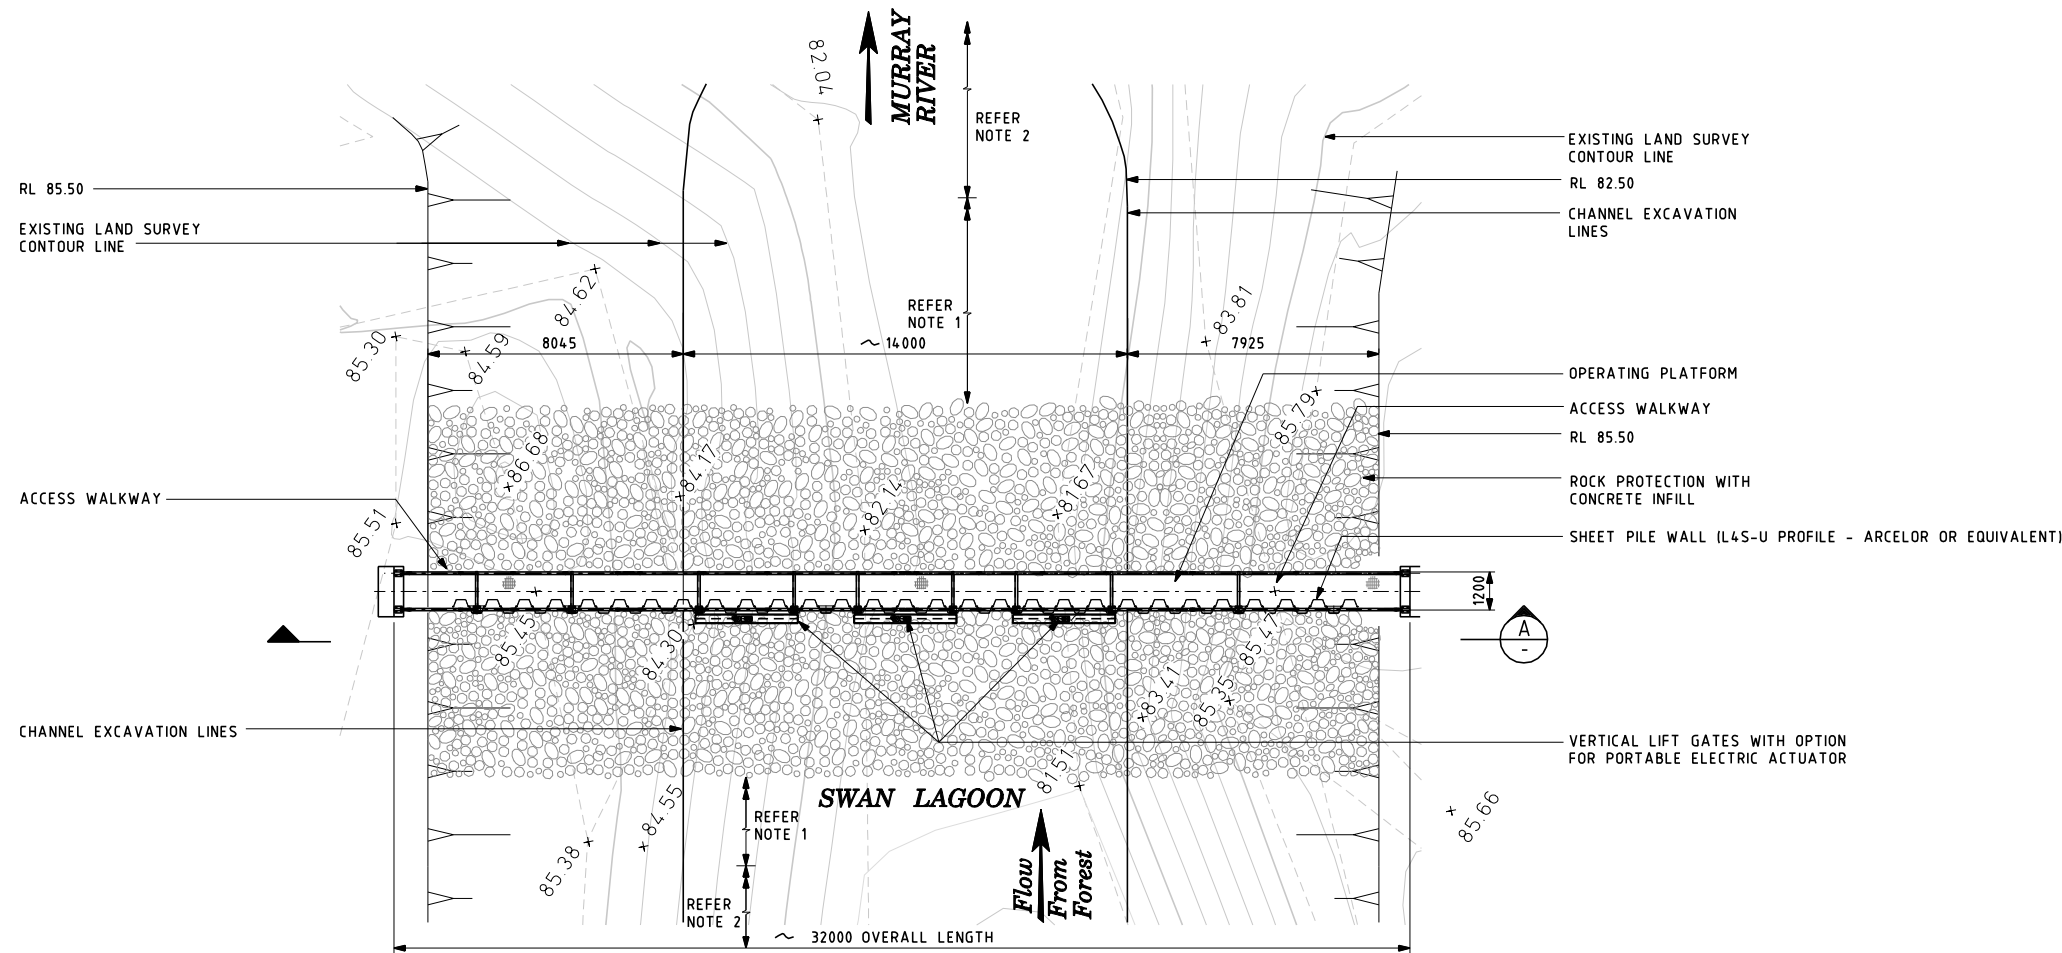


PLAN VIEW
SCALE 1:100

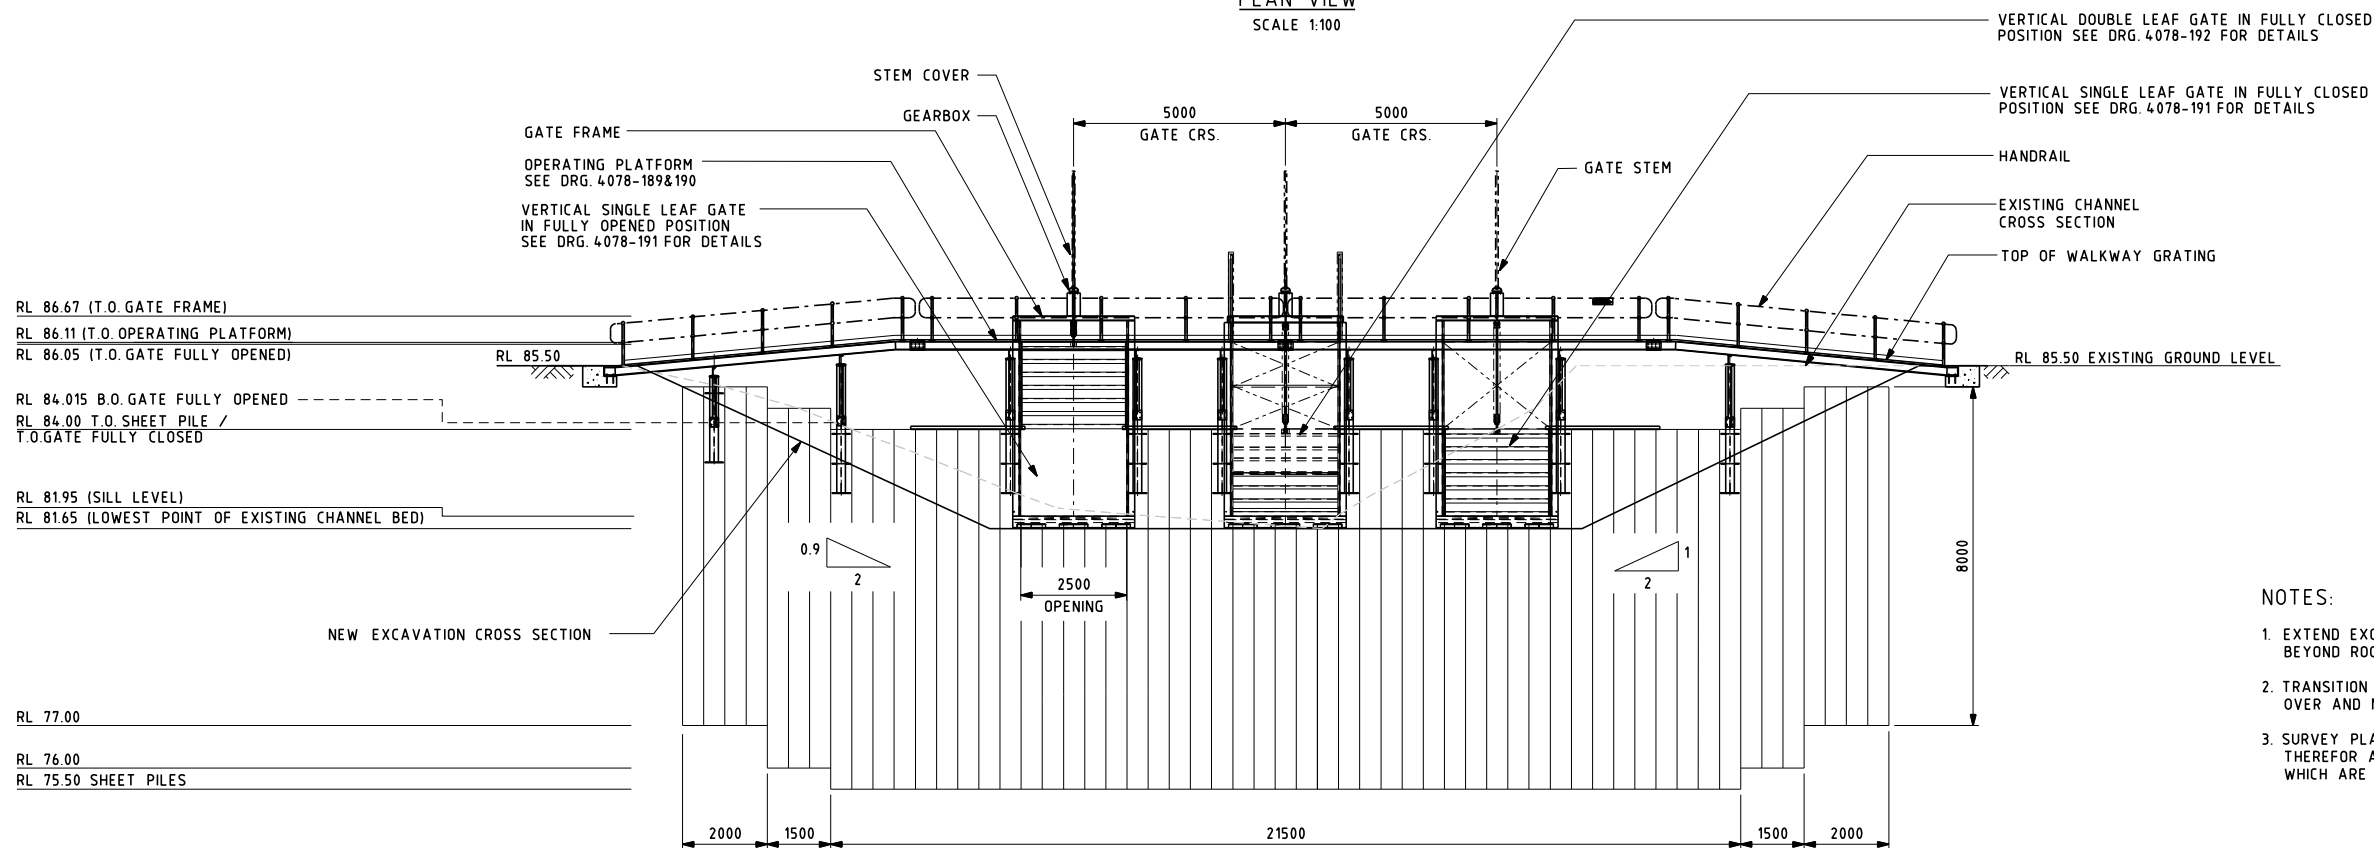

SECTION A-A
SCALE 1:75

NOTES:

 1. EXTEND EXCAVATED CHANNEL FOR 10M BEYOND ROCK PROTECTION
2. TRANSITION BACK TO NATURAL CONTOURS OVER AND MINIMUM DISTANCE OF 20M.
3. SURVEY PLAN FOR THIS AREA IS NOT AVAILABLE, THEREFOR APPROXIMATE CONTOURS ARE DRAWN WHICH ARE TO BE CONFIRMED ON SITE.



DRAFT COPY

GRAEME HEAD - Director General
Department of Services, Technology and Administration
NSW WATER SOLUTIONS
DAMS AND CIVIL TECHNOLOGIES
LEVEL 13, MCKELL BUILDING
2-24 RAWSON PLACE
SYDNEY 2000
PHONE (02) 93727808 FAX (02) 93727822

PLAN RM NO
DESIGNED A. AGARWAL G.M. DAMS AND CIVIL TECHNOLOGIES
DRAFTED J.R. LENEHAN
CHECKED D. REYKHTMAN
G. SAMIOS




**KOONDROOK - PERRICOOTA
FLOOD ENHANCEMENT
SWAN LAGOON
REGULATOR ARRANGEMENT
DOWNSTREAM**

NO IN SET
FILE NO. **DCF 6815**
DRAWING NO. **4078**
REVISION **0**

9/02/2010 2:25:10 PM G:\NSW\Water\tec\p\cod\K\KOONDROOK\DS LEVEE\PKDL4078_401.DGN

B1

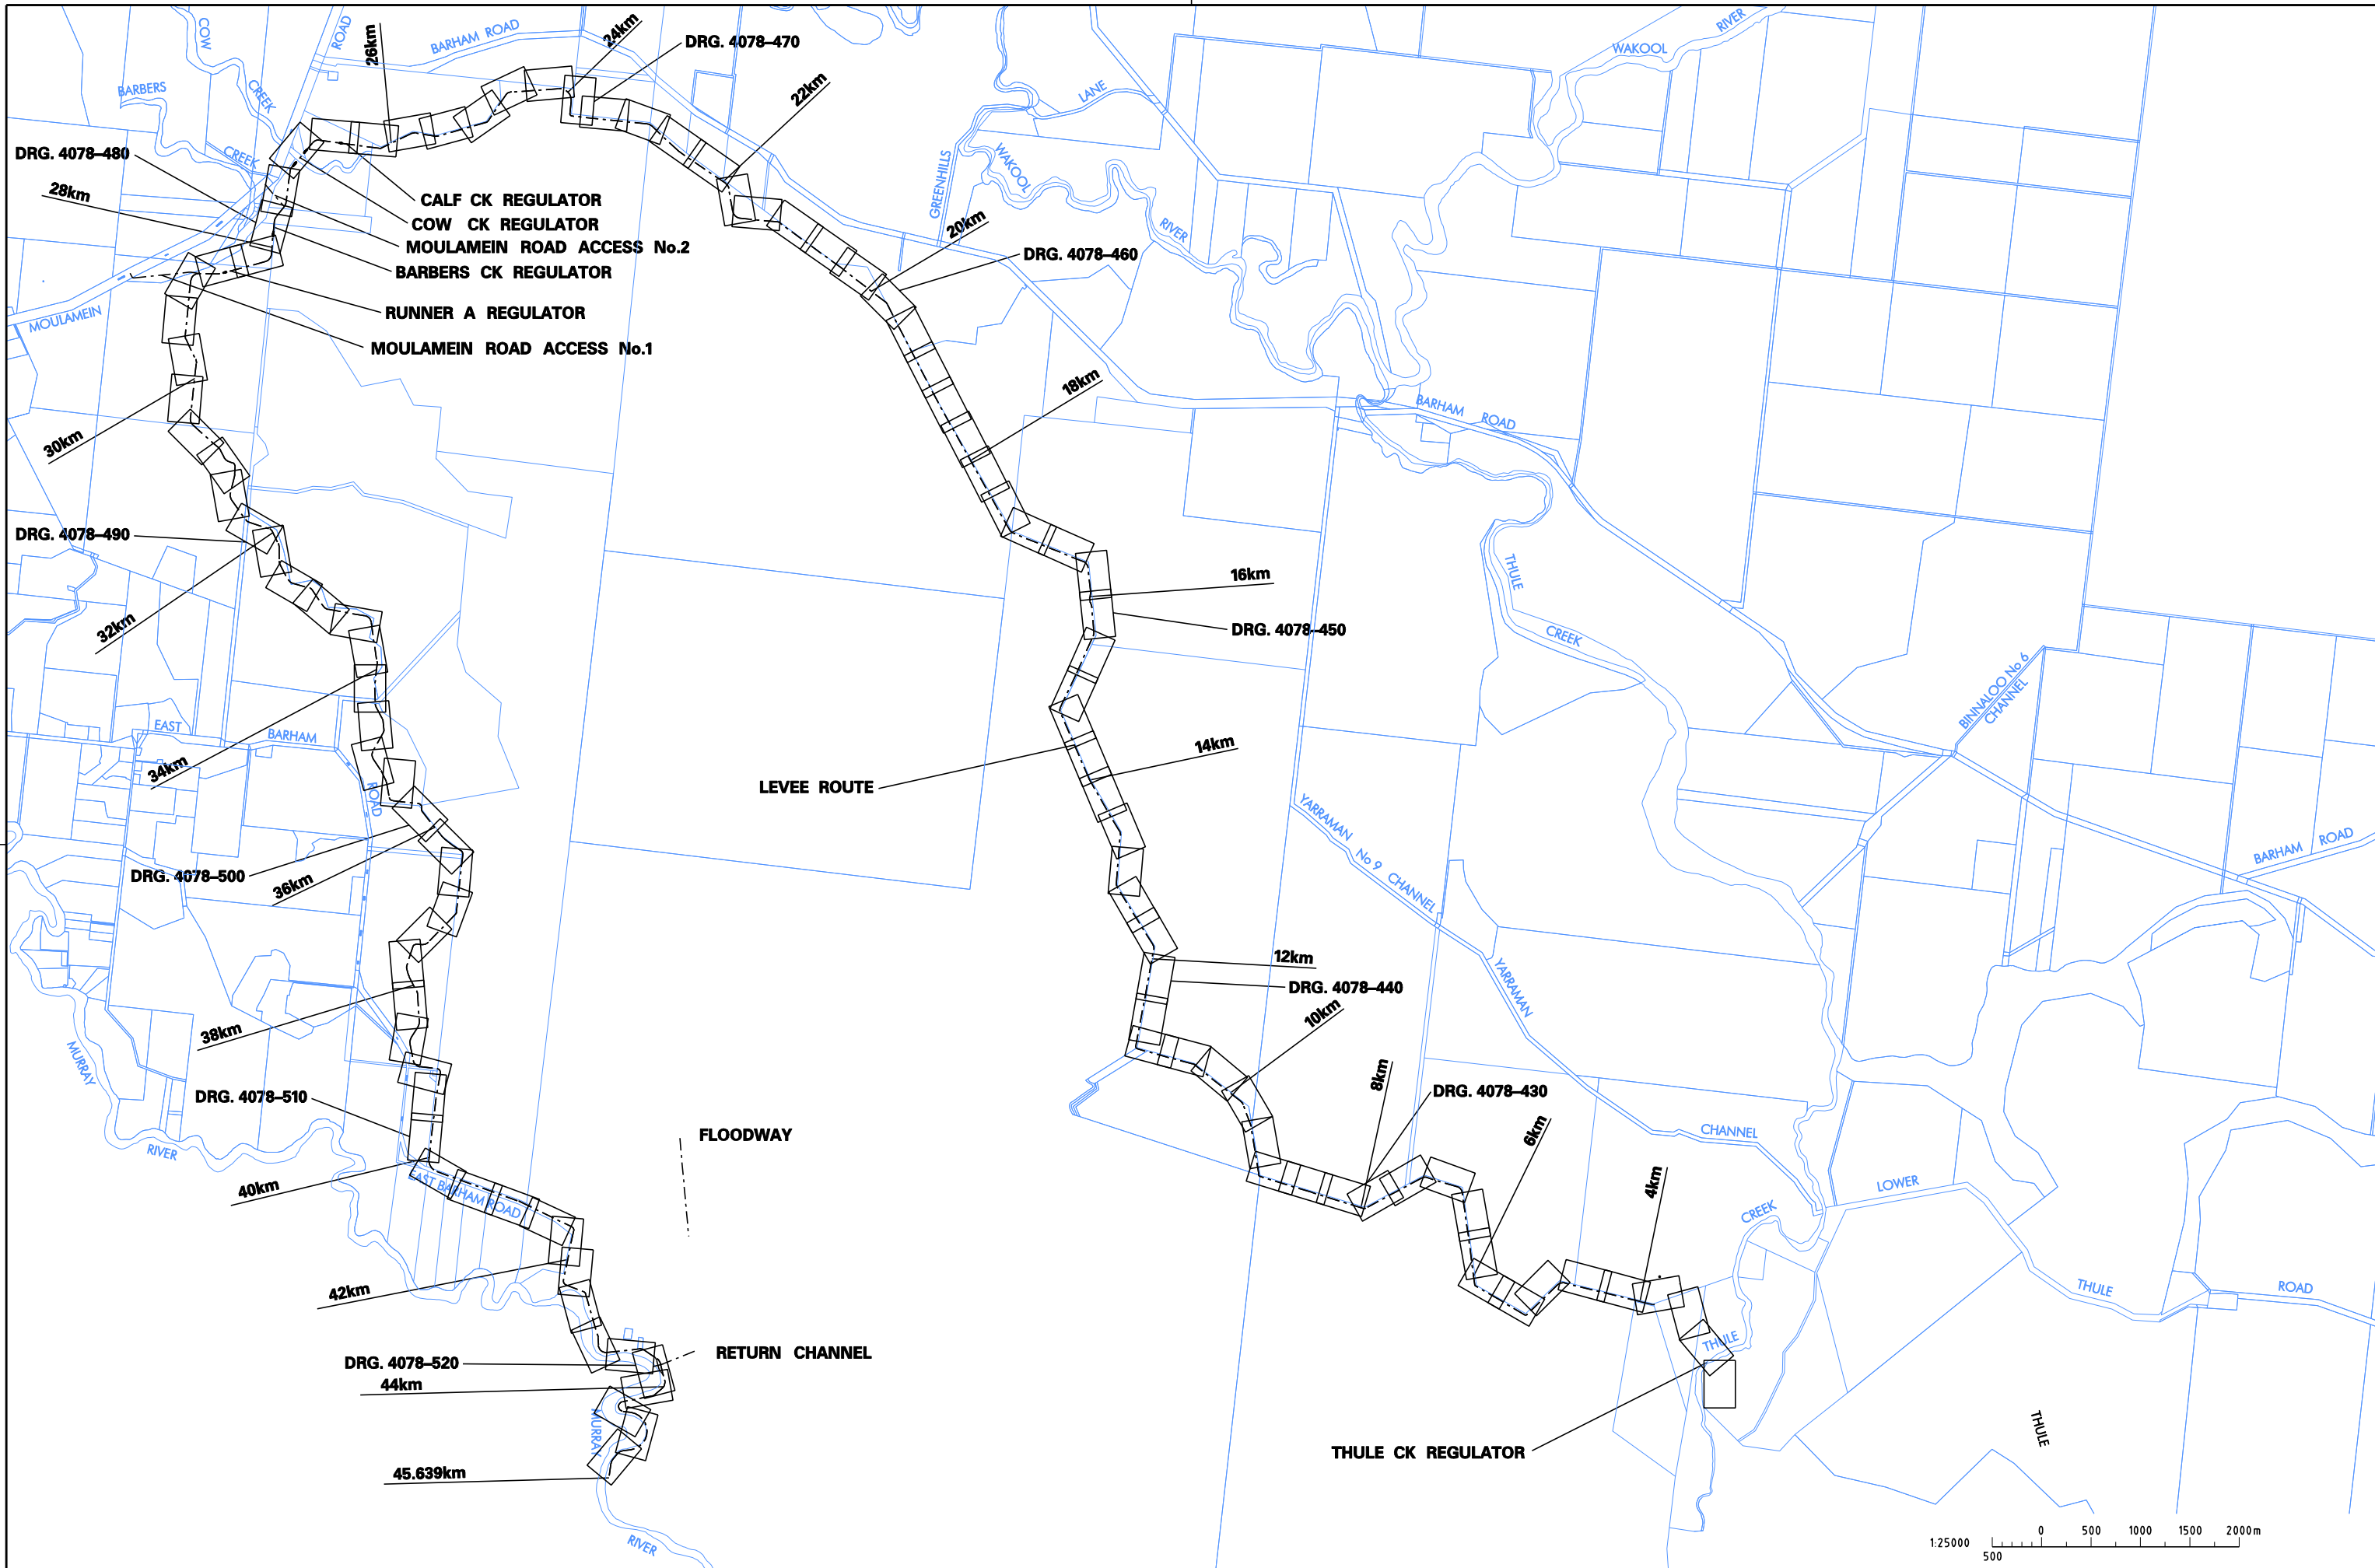

DRAFT COPY

1				
A	ISSUED FOR REVIEW.			
MK	DETAILS OF AMENDMENTS	APPROVED	DATE	

GRAEME HEAD - Director General
Department of Services, Technology and Administration
NSW WATER SOLUTIONS
DAMS AND CIVIL TECHNOLOGIES
LEVEL 13, MCKELL BUILDING
2-24 RAWSON PLACE
SYDNEY 2000
PHONE (02) 93727808 FAX (02) 93727822










DESIGNED	SP. ENGINEER
A. AGARWAL	G. SAMIOS
DRAFTED	G.M. DAMS AND CIVIL TECHNOLOGIES
	J.R. LENEHAN
CHECKED	
G. SAMIOS	



**KOONDROOK - PERRICOOTA
FLOOD ENHANCEMENT**
**DOWNSTREAM LEVEE
KEY PLAN**

NO IN SET
FILE NO. DCF 6815
DRAWING NO. 4078 - 401
REVISION A

 
G:\NSW\Water\tec\p\cod\K\KOONDROOK\DS LEVEE\PKDL4078_401.DGN

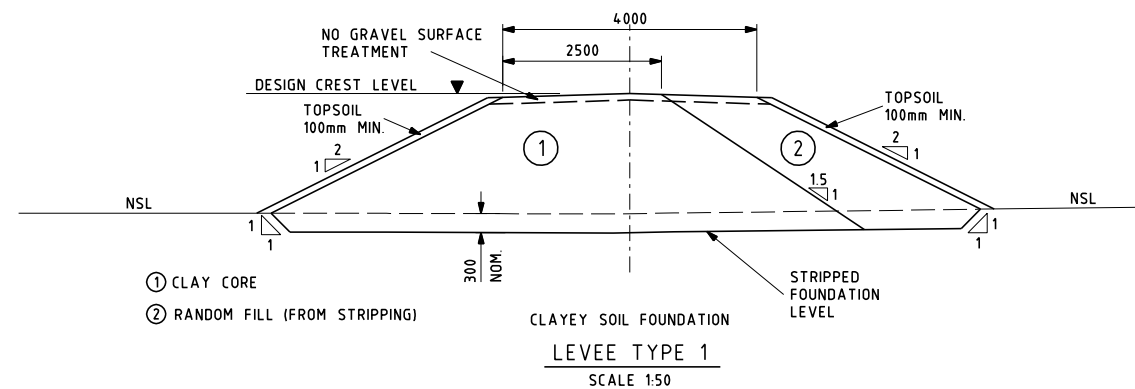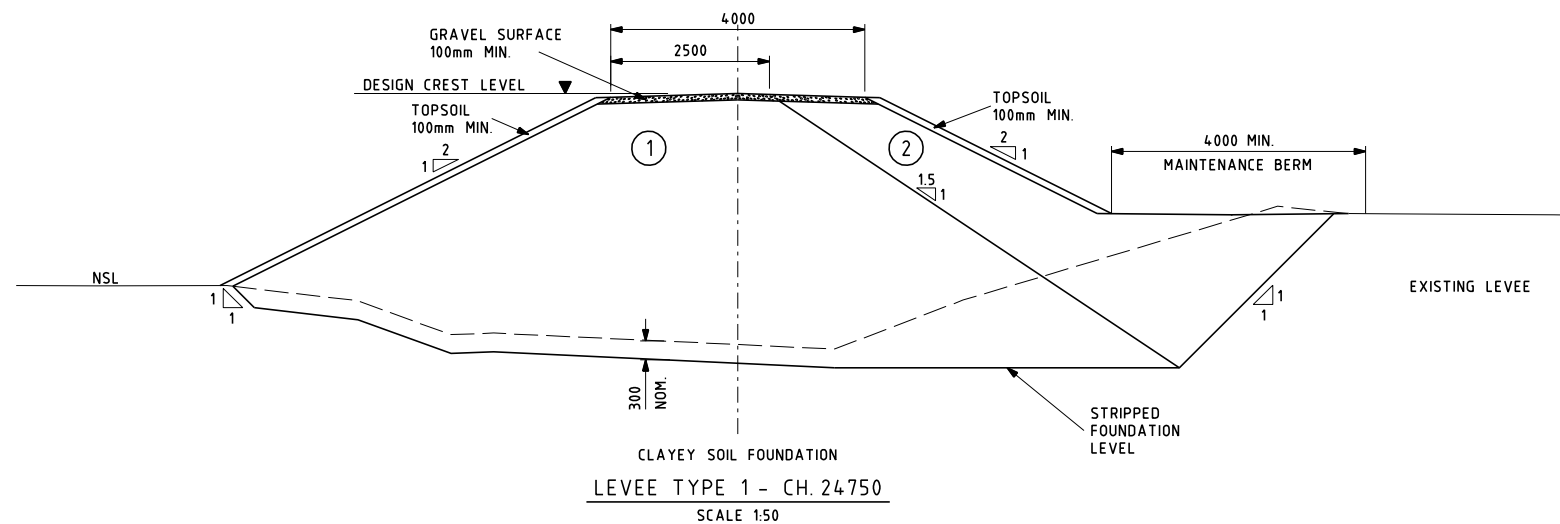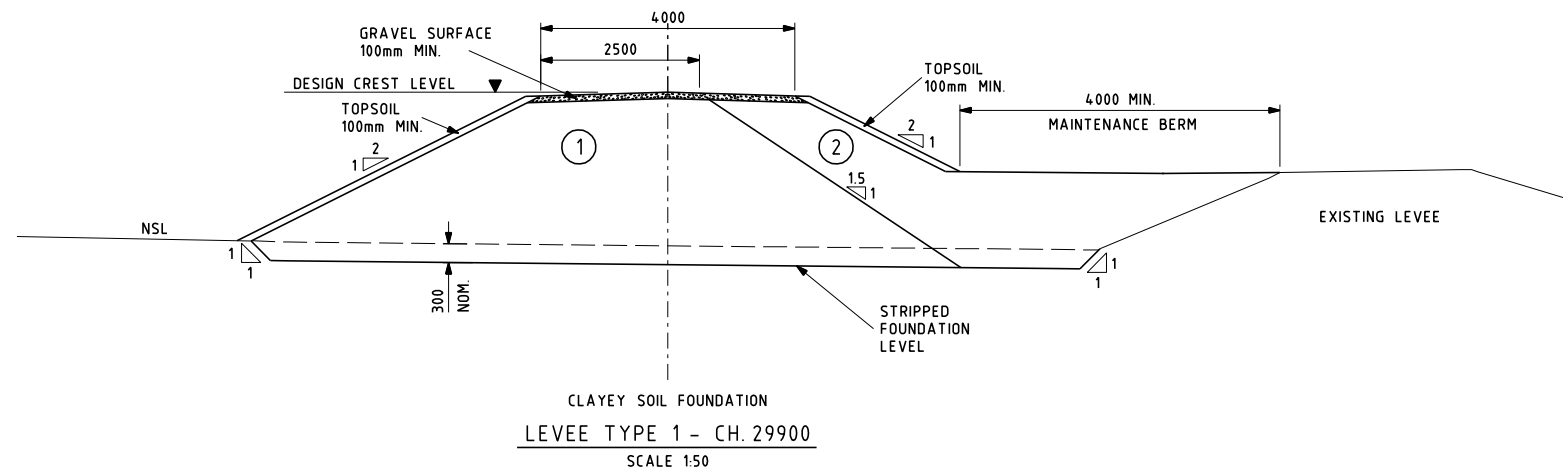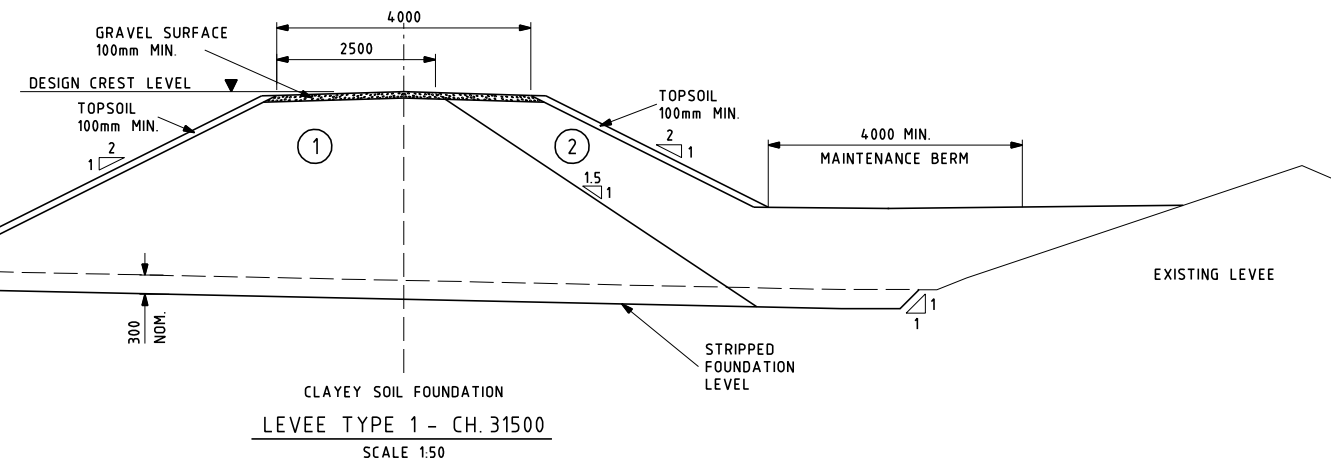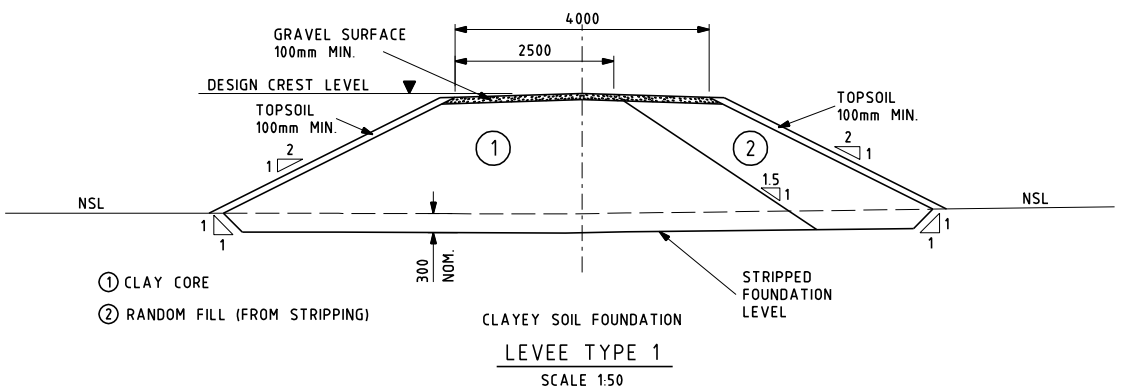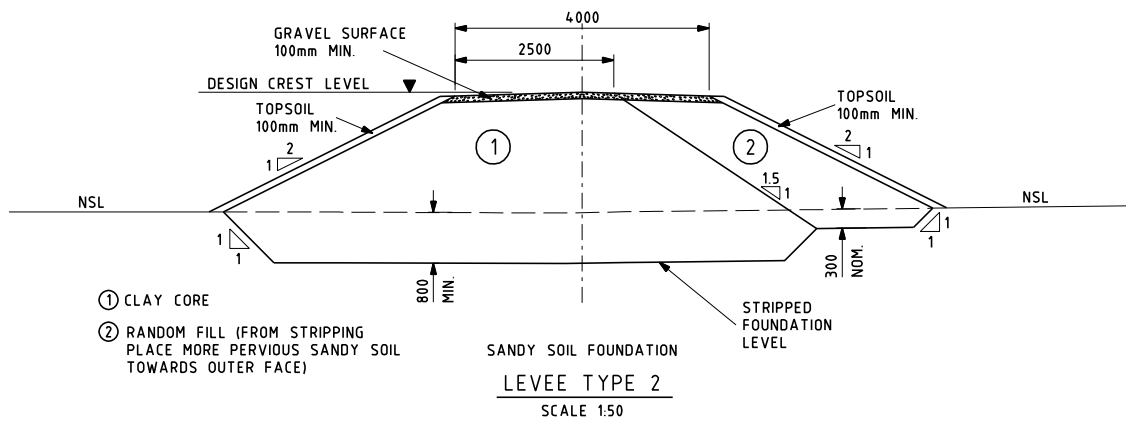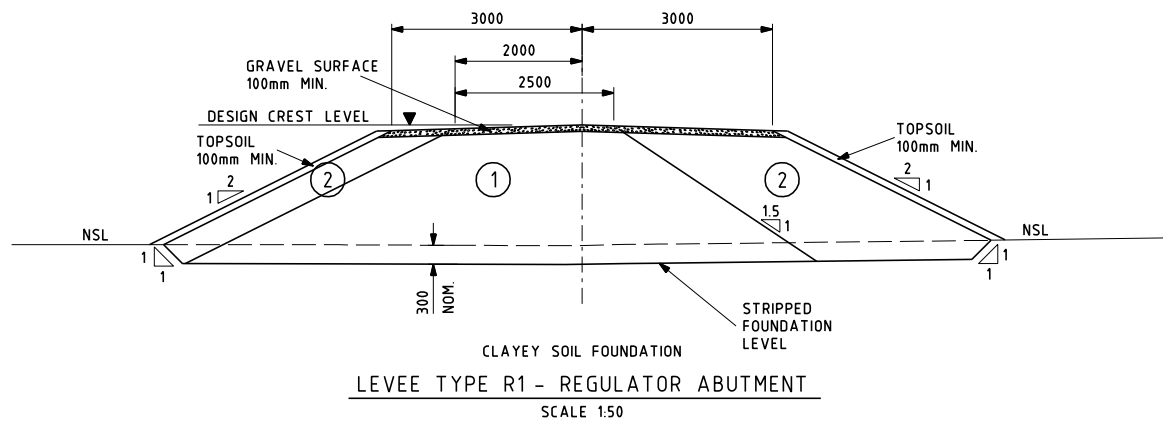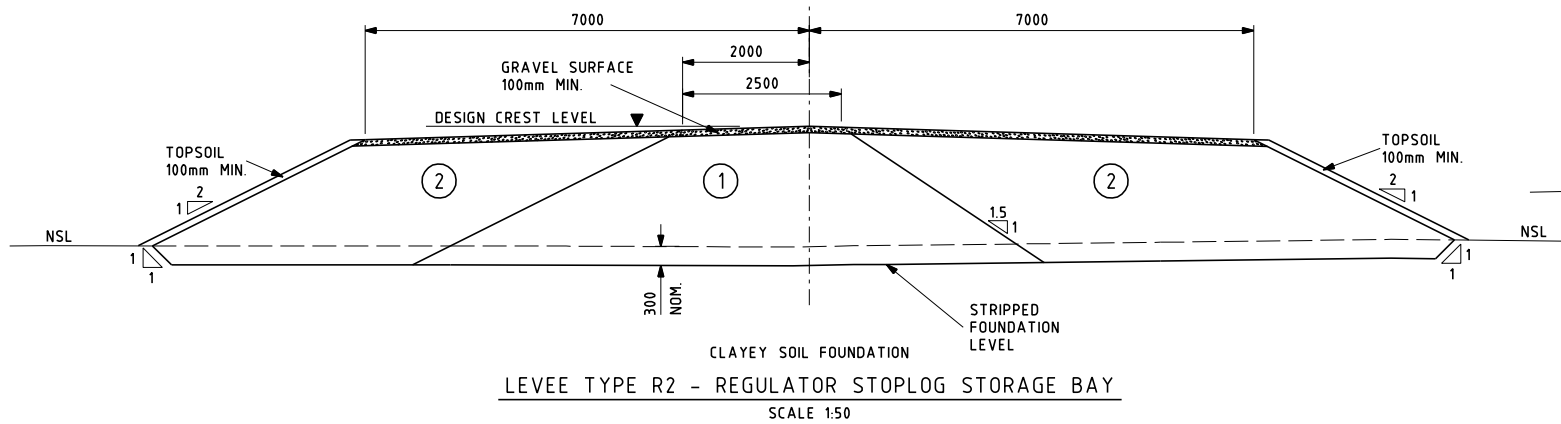

DRAFT COPY


GRAEME HEAD - Director General
Department of Services, Technology and Administration
NSW WATER SOLUTIONS
DAMS AND CIVIL TECHNOLOGIES
LEVEL 13, McKELL BUILDING
2-24 RAWSON PLACE
SYDNEY 2000
PHONE (02) 93727808 FAX (02) 93727822

PLAN RM NO
DESIGNED Y. BOSSON
DRAFTED Y. BOSSON
CHECKED B. CLARK
SP. ENGINEER G. SAMIOS
G.M. DAMS AND CIVIL TECHNOLOGIES
J. R. LENEHAN

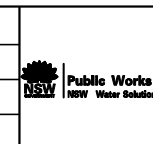

**KOONDROOK - PERRICOOTA
FLOOD ENHANCEMENT**
STANDARD LEVEE
SECTIONS

NO IN SET
FILE NO. DCF 6815
DRAWING NO. 4078 - 402
REVISION 0

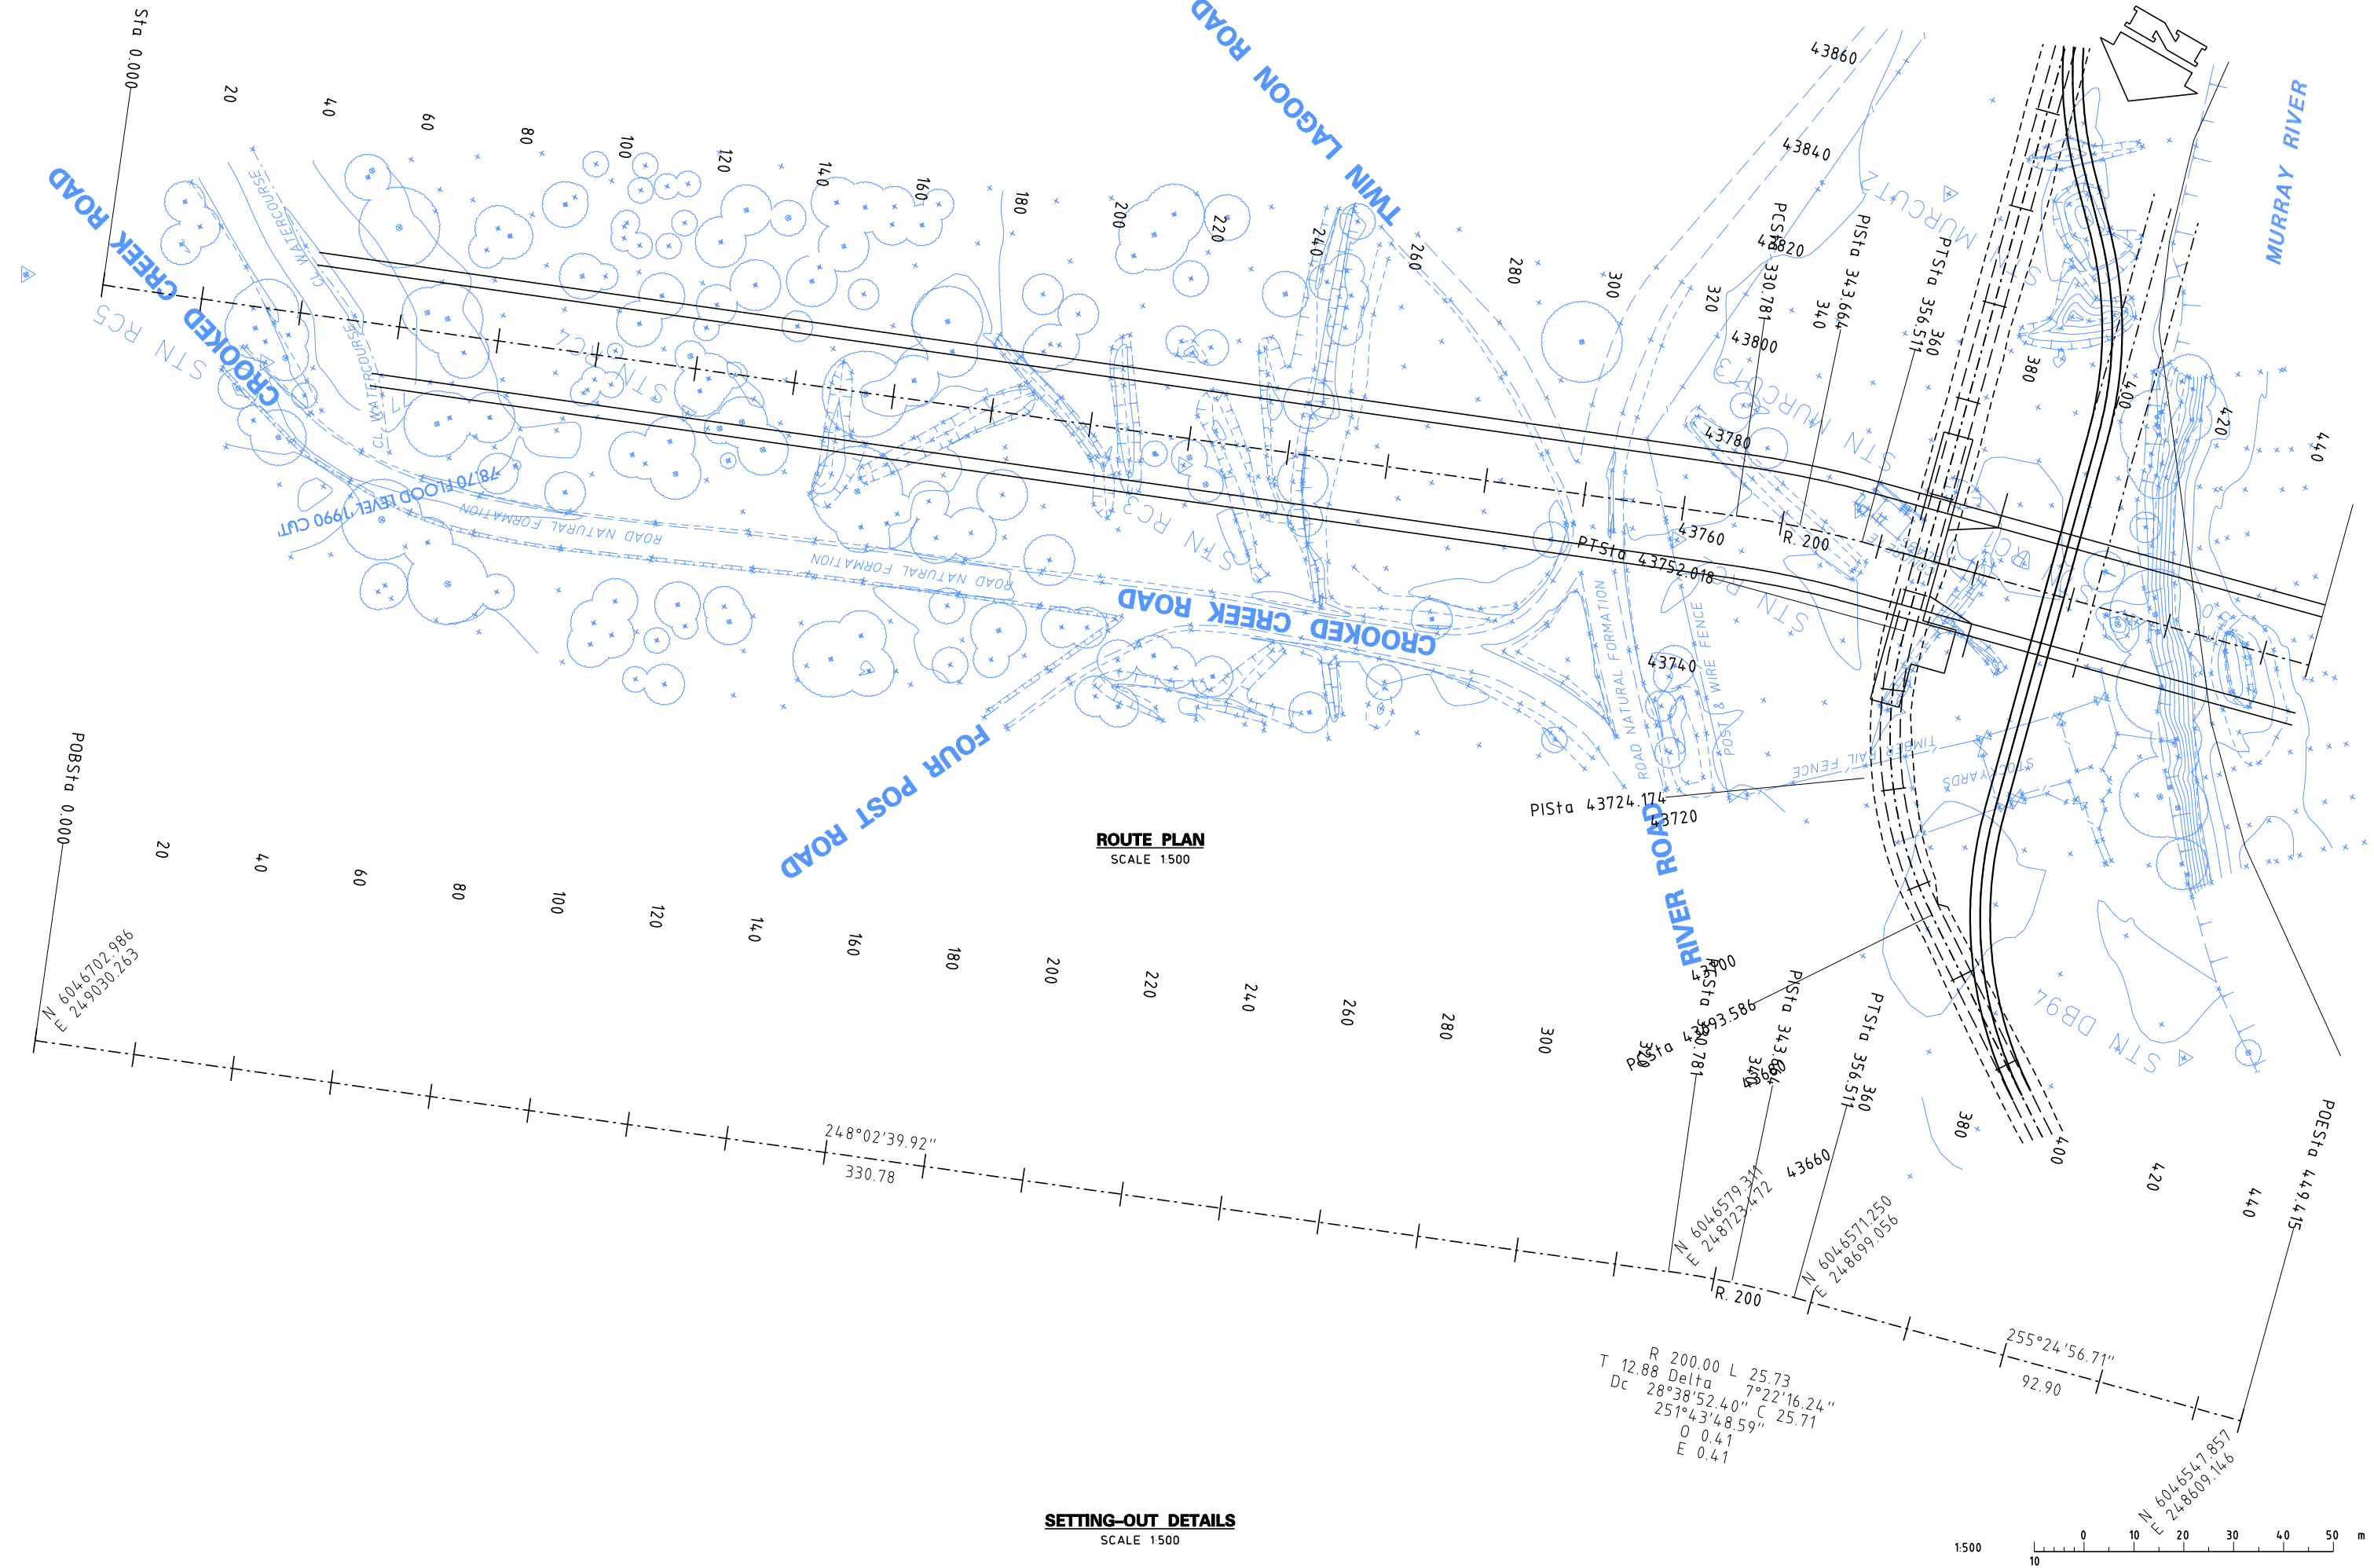

8/02/20										DRAFT COPY	
0		ISSUED FOR REVIEW									
MK		DETAILS OF AMENDMENTS				APPROVED		DATE			
0		(C) Crown in right of NSW through the Department of Services, Technology & Administration 200		100						200	

DRAFT COPY

GRAEME HEAD - Director General
Department of Services, Technology and Administration

NSW WATER SOLUTIONS
DAMS AND CIVIL TECHNOLOGIES
LEVEL 13, MCKELL BUILDING
2-24 RAWSON PLACE
SYDNEY 2000
PHONE (02) 93727808 FAX (02) 93727822






PLAN RM NO	
DESIGNED	SP ENGINEER
Y. BOSSON	G. SAMIOS
DRAFTED	G.M. DAMS AND CIVIL TECHNOLOGIES
Y. BOSSON	J.R. LENEHAN
CHECKED	
B. CLARK	



**KOONDROOK - PERRICOOTA
FLOOD ENHANCEMENT**

**RETURN CHANNEL
ROUTE PLAN AND SETTING-OUT DETAILS
CH. TO CH.**

 
NO IN SET
FILE NO. DCF 6815
DRAWING NO. 4078 - 702
REVISION 0

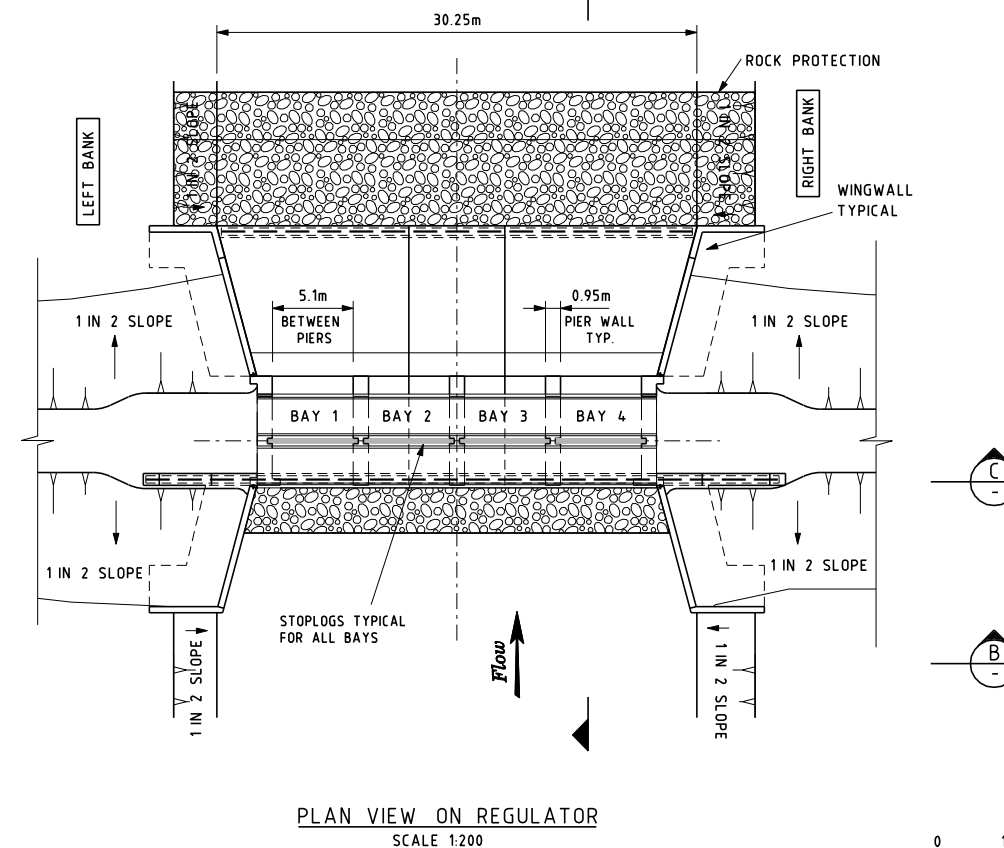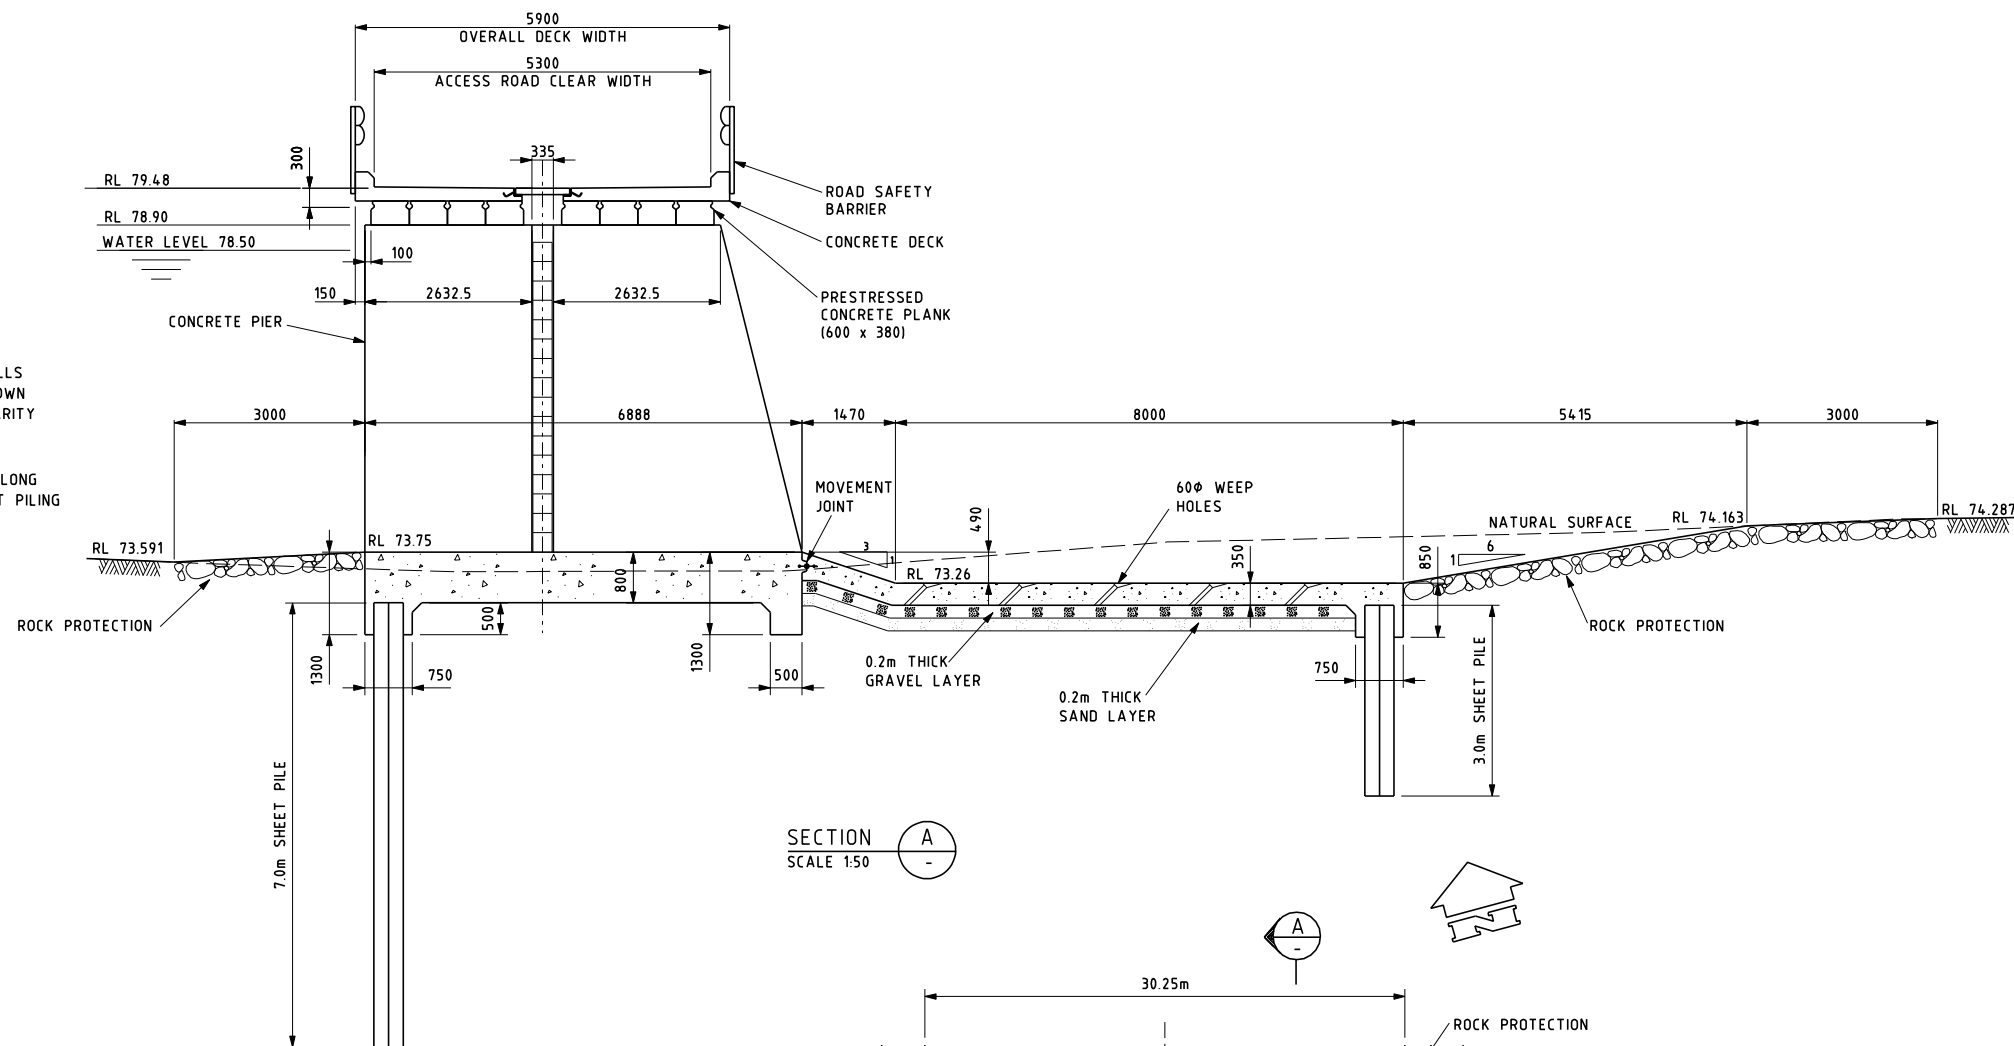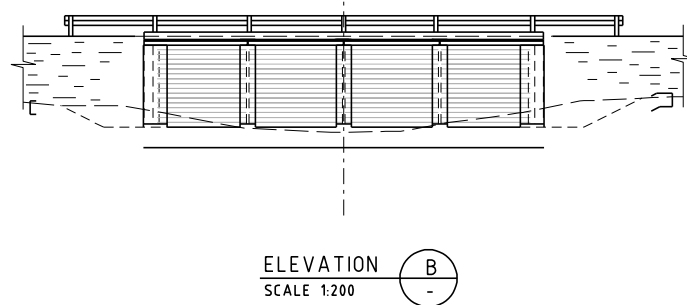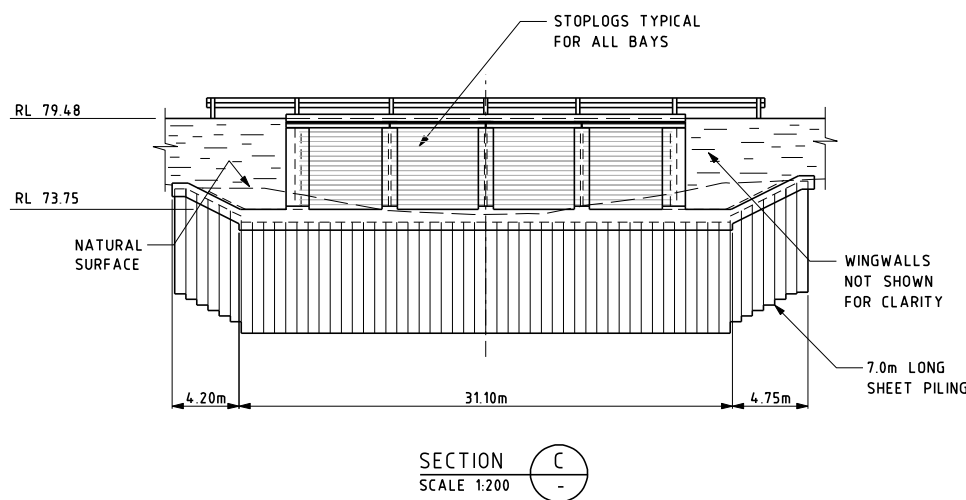

0	ISSUED FOR REVIEW		
MK	DETAILS OF AMENDMENTS	APPROVED	DATE



GRAEME HEAD - Director General
Department of Services, Technology and Administration
NSW WATER SOLUTIONS
DAMS AND CIVIL TECHNOLOGIES
LEVEL 13, MCKELL BUILDING
2-24 RAWSON PLACE
SYDNEY 2000
PHONE (02) 93727808 FAX (02) 93727822

DESIGNED	SP. ENGINEER
A. UN-NABI	G. SAMIOS
DRAFTED	G.M. DAMS AND CIVIL TECHNOLOGIES
D.J. MALONE	J.R. LENEHAN
CHECKED	
G. SAMIOS	

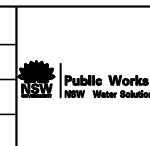


**KOONDROOK - PERRICOOTA
FLOOD ENHANCEMENT**
DOWNSTREAM STRUCTURES
RUNNER A REGULATOR
GENERAL ARRANGEMENT - Sheet 1 of 2

 
NO IN SET
FILE NO. DCF 6815
DRAWING NO. 4078 - 366
REVISION 0

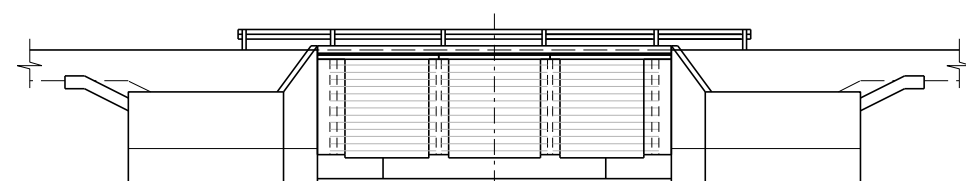


ELEVATION B
SCALE 1:200 -

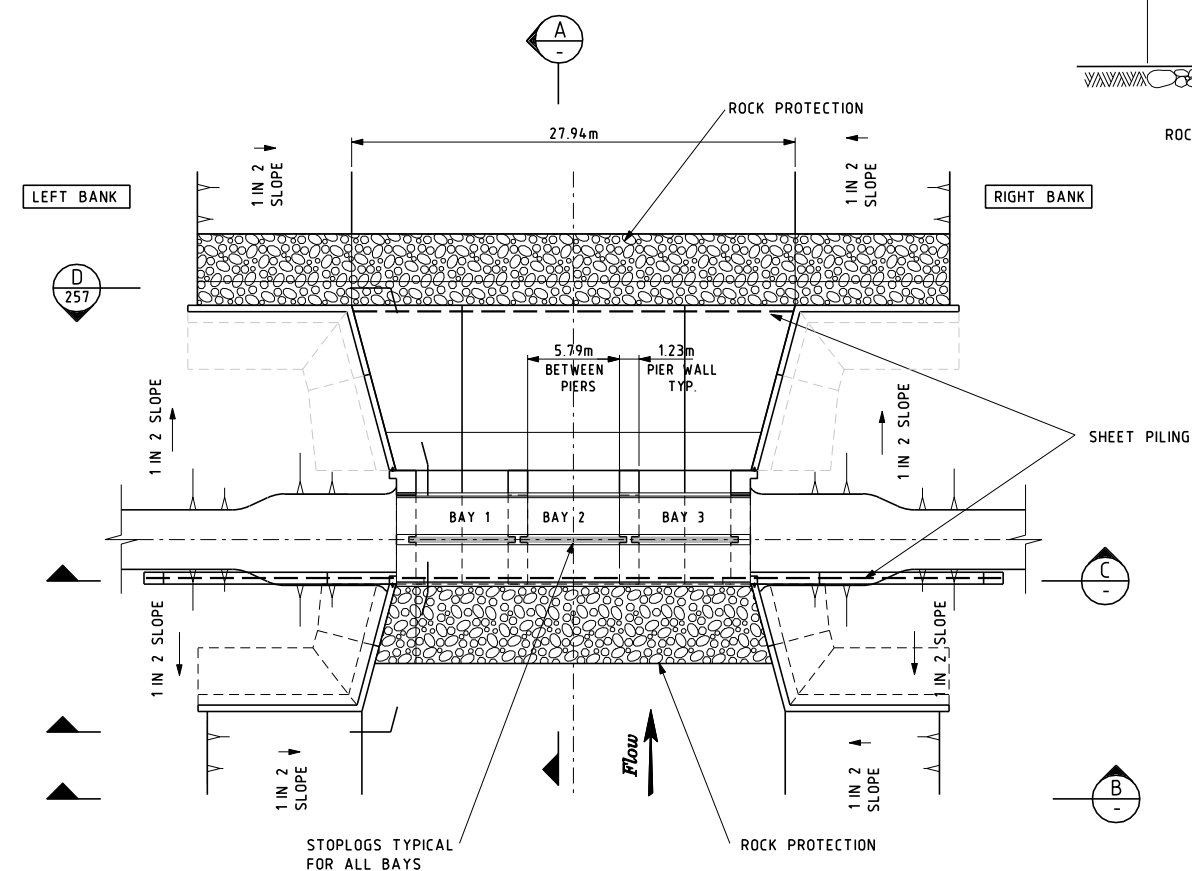

PLAN VIEW ON REGULATOR
SCALE 1:200

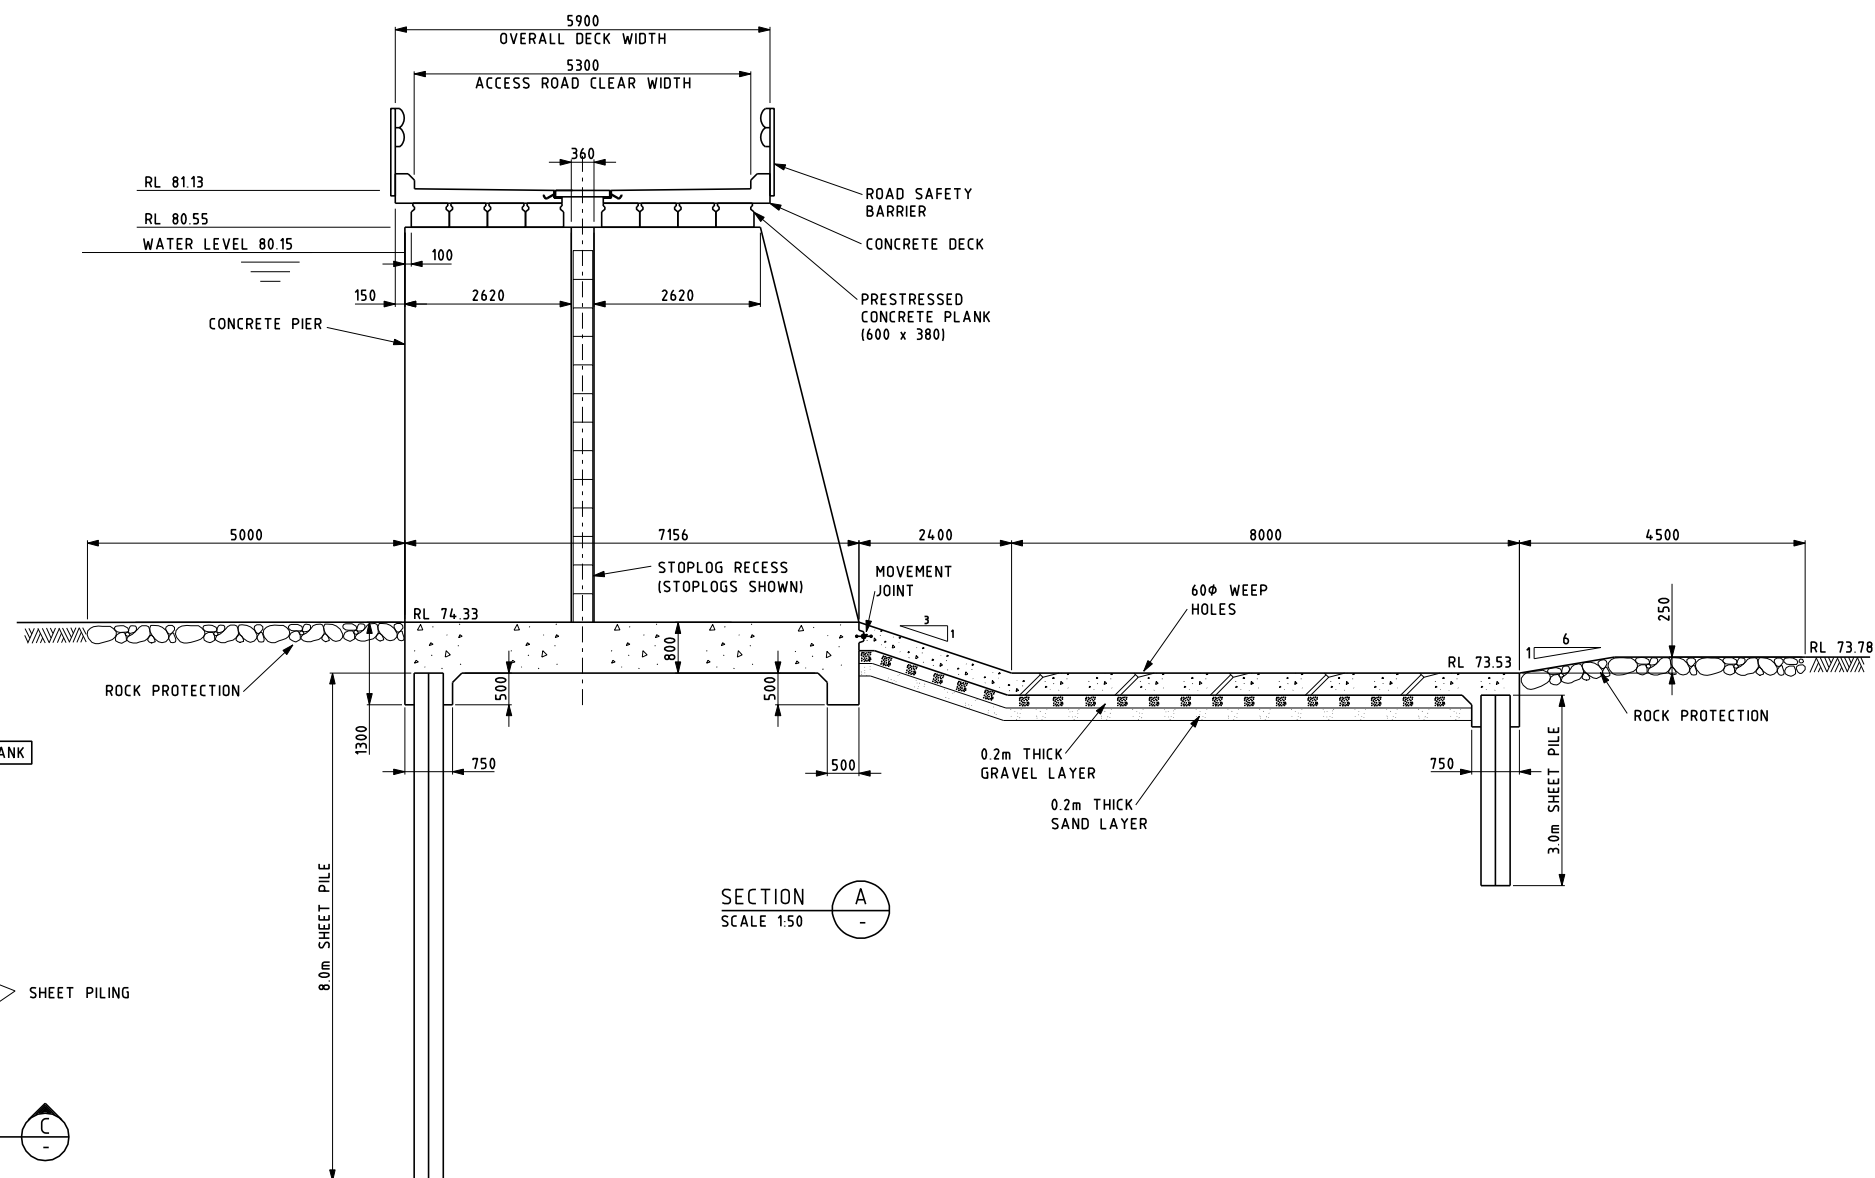

SECTION A
SCALE 1:50

 

DRAFT COPY

GRAEME HEAD - Director General
Department of Services, Technology and Administration

NSW WATER SOLUTIONS
DAMS AND CIVIL TECHNOLOGIES
LEVEL 13, McKELL BUILDING
2-24 RAWSON PLACE
SYDNEY 2000
PHONE (02) 93727808 FAX (02) 93727822

PLAN RM NO	
DESIGNED A.UN-NABI	S.P. ENGINEER G. SAMIOS
DRAFTED D.J. MALONE	G.M. DAMS AND CIVIL TECHNOLOGIES
CHECKED G. SAMIOS	J.R. LENEHAN





KOONDROOK – PERRICOOTA FLOOD ENHANCEMENT


NO IN SET
FILE NO. DCF 6815
DRAWING NO. 4078 - 256
REVISION 0

G:\NSW\Water\tec\Kood\Koodrook\DESIGN_09\Swan Lagoon\DETAIL_UP\STRIPUPSTRIB181.dgn
No 1 on 02
5:02:31 PM
8/02/2010

679
B1

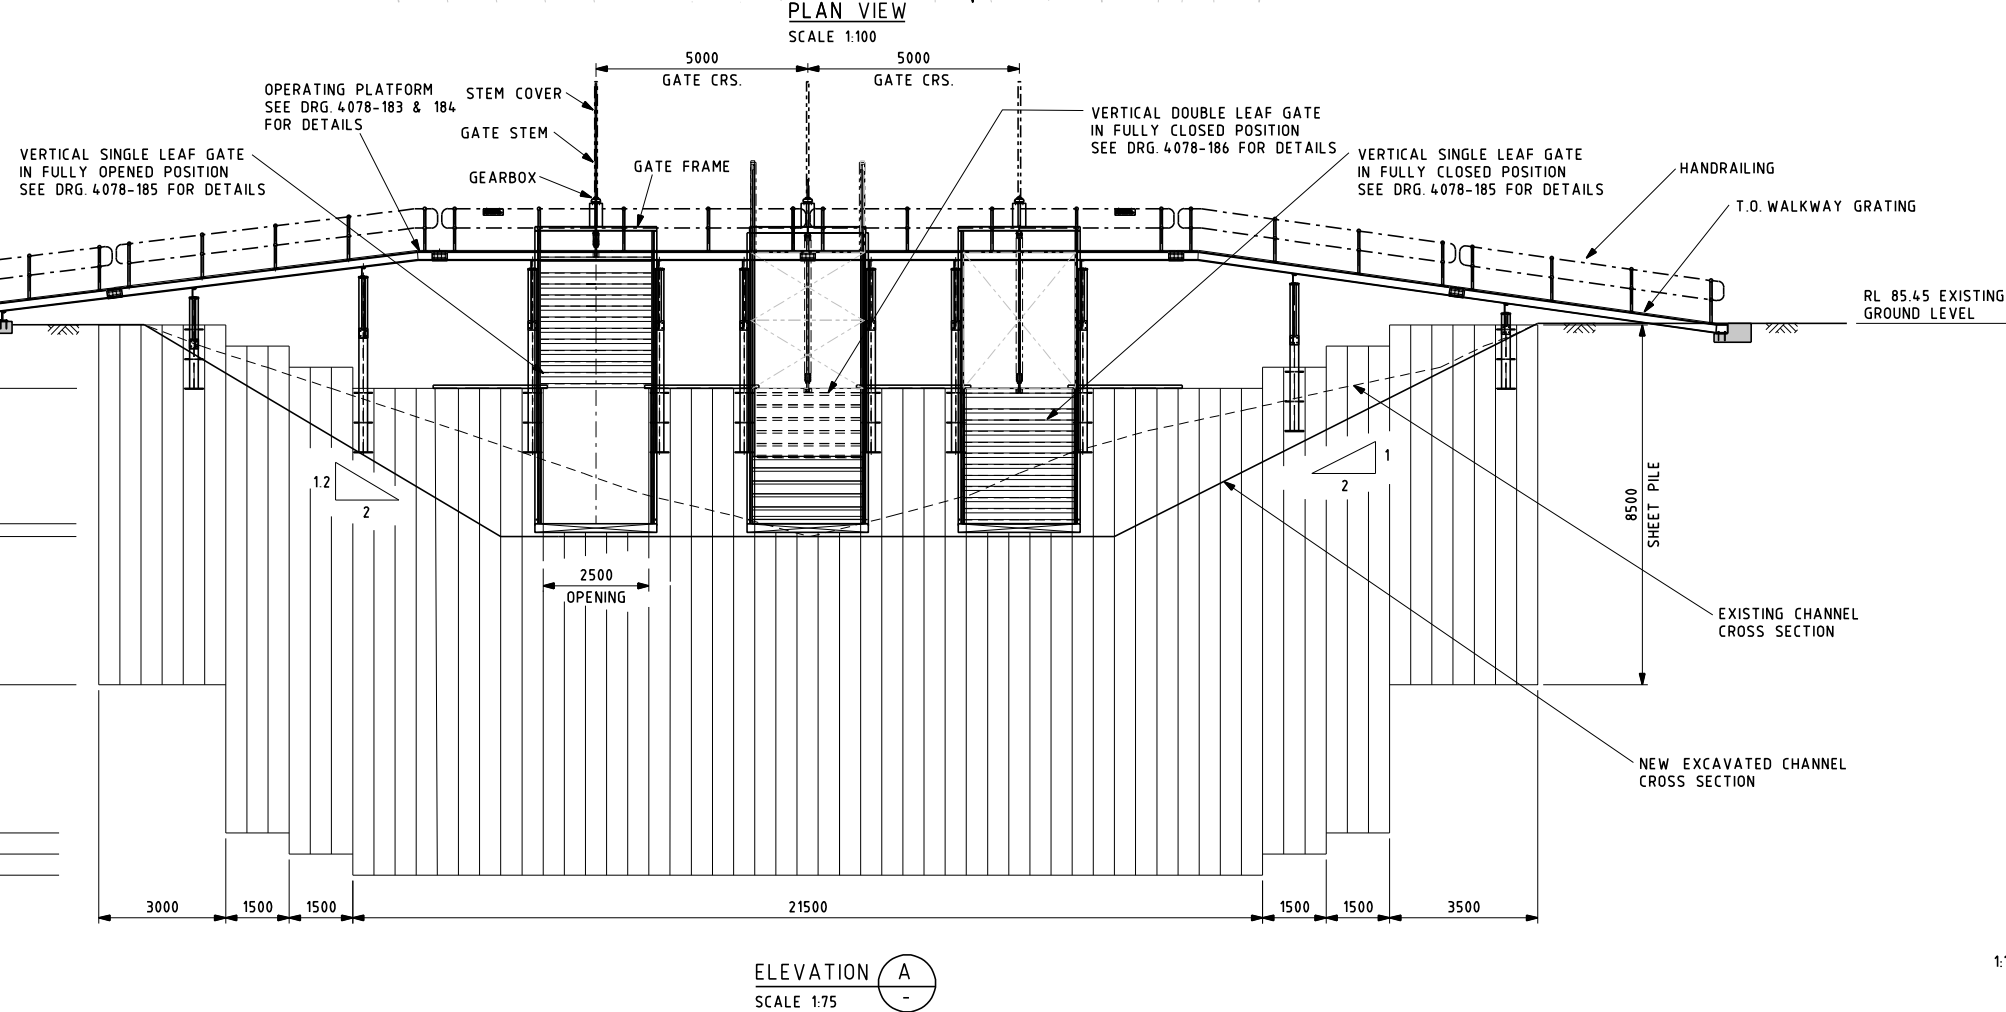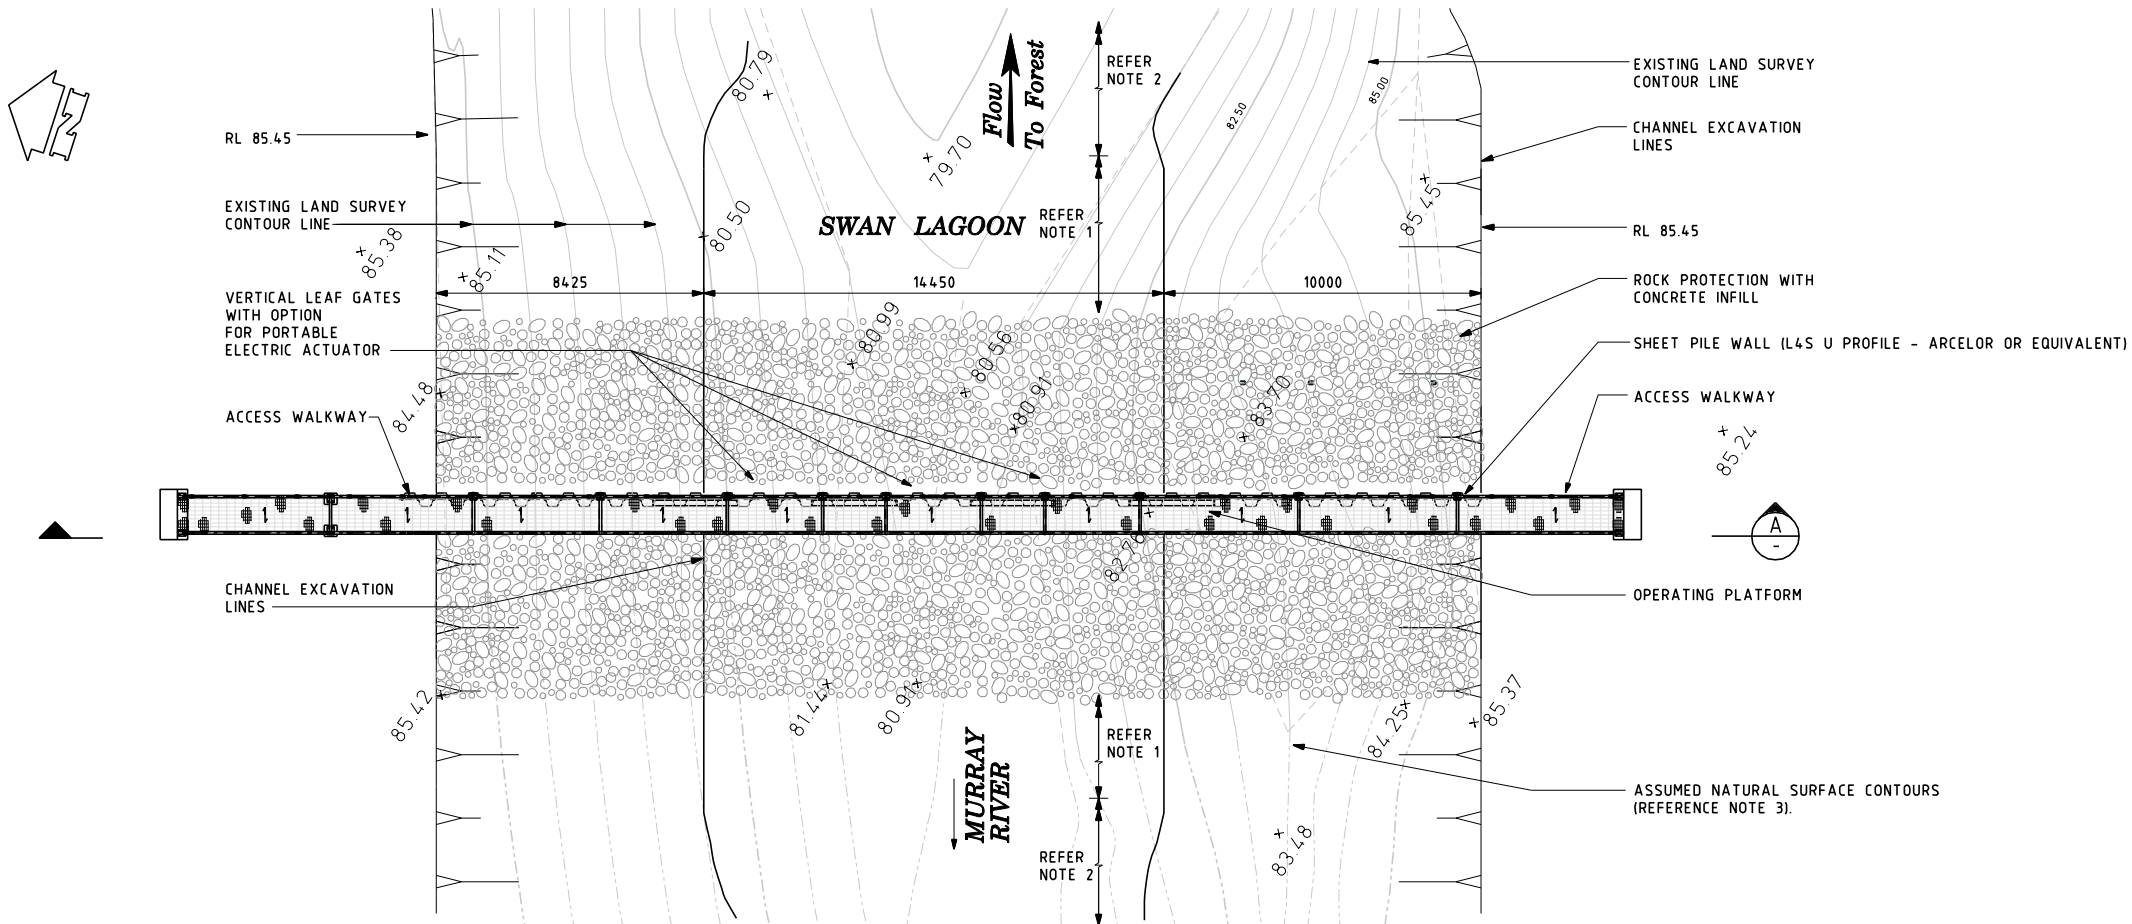

- NOTES:
1. EXTEND EXCAVATED CHANNEL FOR 10M BEYOND ROCK PROTECTION
 2. TRANSITION BACK TO NATURAL CONTOURS OVER A MINIMUM DISTANCE OF 20M.
 3. SURVEY PLAN FOR THIS AREA IS NOT AVAILABLE, APPROXIMATE CONTOURS ARE DRAWN WHICH ARE TO BE CONFIRMED ON SITE.

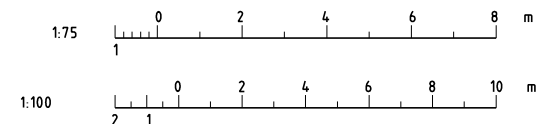

DRAFT COPY

GRAEME HEAD - Director General
Department of Services, Technology and Administration
NSW WATER SOLUTIONS
DAMS AND CIVIL TECHNOLOGIES
LEVEL 13, MCKELL BUILDING
2-24 RAWSON PLACE
SYDNEY 2000
PHONE (02) 93727808 FAX (02) 93727822

PLAN RM NO
DESIGNED A. AGARWAL G.M. DAMS AND CIVIL TECHNOLOGIES
DRAFTED J.R. LENEHAN
CHECKED D. REYKHTMAN
G. SAMIOS



**KOONDROOK - PERRICOOTA
FLOOD ENHANCEMENT**
SWAN LAGOON
REGULATOR ARRANGEMENT
UPSTREAM

NO IN SET
FILE NO. **DCF 6815**
DRAWING NO. **4078** -181
REVISION 0



GHD

133 Castlereagh St Sydney NSW 2000

-

T: 2 9239 7100 F: 2 9239 7199 E: sydmail@ghd.com.au

© GHD 2010

This document is and shall remain the property of GHD. The document may only be used for the purpose for which it was commissioned and in accordance with the Terms of Engagement for the commission. Unauthorised use of this document in any form whatsoever is prohibited.

Document Status

Rev No.	Author	Reviewer		Approved for Issue		
		Name	Signature	Name	Signature	Date
0	Katrina Smallwood	Peter Carson		David Chubb		18 February 2010