

EAST LEPPINGTON PRIMARY SCHOOL



LOCATION PLAN N.T.S



EAST LEPPINGTON SSSA DRAWING LIST		
Sheet Number	Sheet Name	Rev
00_001	COVER SHEET	A
00_002	OVERALL SITE PLAN	A
00_011	COMPOSITE FLOOR PLAN - LEVEL 00 BLOCK A&B	A
00_012	COMPOSITE FLOOR PLAN - LEVEL 00 BLOCK E	A
00_013	COMPOSITE FLOOR PLAN - LEVEL 01 BLK A&B, LEVEL 00 BLK C&D	A
00_014	COMPOSITE FLOOR PLAN - LEVEL 02 BLK A&B, LEVEL 01 BLK C&D	A
00_015	COMPOSITE FLOOR PLAN - LEVEL 02 BLOCK C	A
00_021	COMPOSITE ROOF PLAN - PART 1	A
00_022	COMPOSITE ROOF PLAN - PART 2	A
00_101	OVERALL ELEVATIONS - SHEET 01	A
00_102	OVERALL ELEVATIONS - SHEET 02	A
00_201	OVERALL SECTIONS - SHEET 1	A
00_202	OVERALL SECTIONS - SHEET 2	A
00_301	SHADOW EXISTING & PROPOSED - 21 JUNE 9 AM	A
00_302	SHADOW EXISTING & PROPOSED - 21 JUNE 12 PM	A
00_303	SHADOW EXISTING & PROPOSED - 21 JUNE 3 PM	A
00_801	WALL SECTIONS - SHEET 01	A

2/09/2019 6:24:59 PM

DRAFT ISSUE

AMMENDMENTS			
REV	BY	DATE	DESCRIPTION
A	VL	13.08.19	PRELIMINARY ISSUE FOR REVIEW
	VL	02.09.19	ISSUE FOR SSSA TOA

LEGEND

HANSENYUNCKEN

STRUC. CIVIL
NORTHROP ENGINEERS
(02) 9241 4188
 MECH. ELEC
STENSHEN WARMING
(02) 9967 2200
 HYD
WOOLACOTTS
(02) 8241 9900
 FIRE
MCD FIRE ENGINEERING
(04) 2392 2745

PERUMAL PEDAVOLI ARCHITECTS
 T: 02 9291 0000
 WEB: www.pp-a.com.au
 Nominated Architect
 Since Pedavoli NSW reg No.5045

PERUMAL PEDAVOLI
 ARCHITECTS


EAST LEPPINGTON PS
 NEW HIGH QUALITY CLASSROOMS
 DRAWING NAME
COVER SHEET

PROJECT NORTH

DRAWN	CHECKED	VERIFIED	DATE
Author	Checker	Approver	2 September 2019
DRAWING NUMBER			REVISION
NHQC2 - LP - AR -SSDA-00_001			A

SCALE: 1:200 @ A1

SITE SERVICES SCHEDULE	
Number	Description
1	WASTE PAD
2	MAIN SWITCHBOARD ROOM
3	SUBSTATION
4	PUMPS
5	SHADE STRUCTURE
6	PLANT WITH SCREEN
7	ASSEMBLY
8	BICYCLE PARKING
9	SPORTS FIELD
10	MAIN SCHOOL SIGN
11	FUTURE ELECTRONIC SCHOOL SIGN

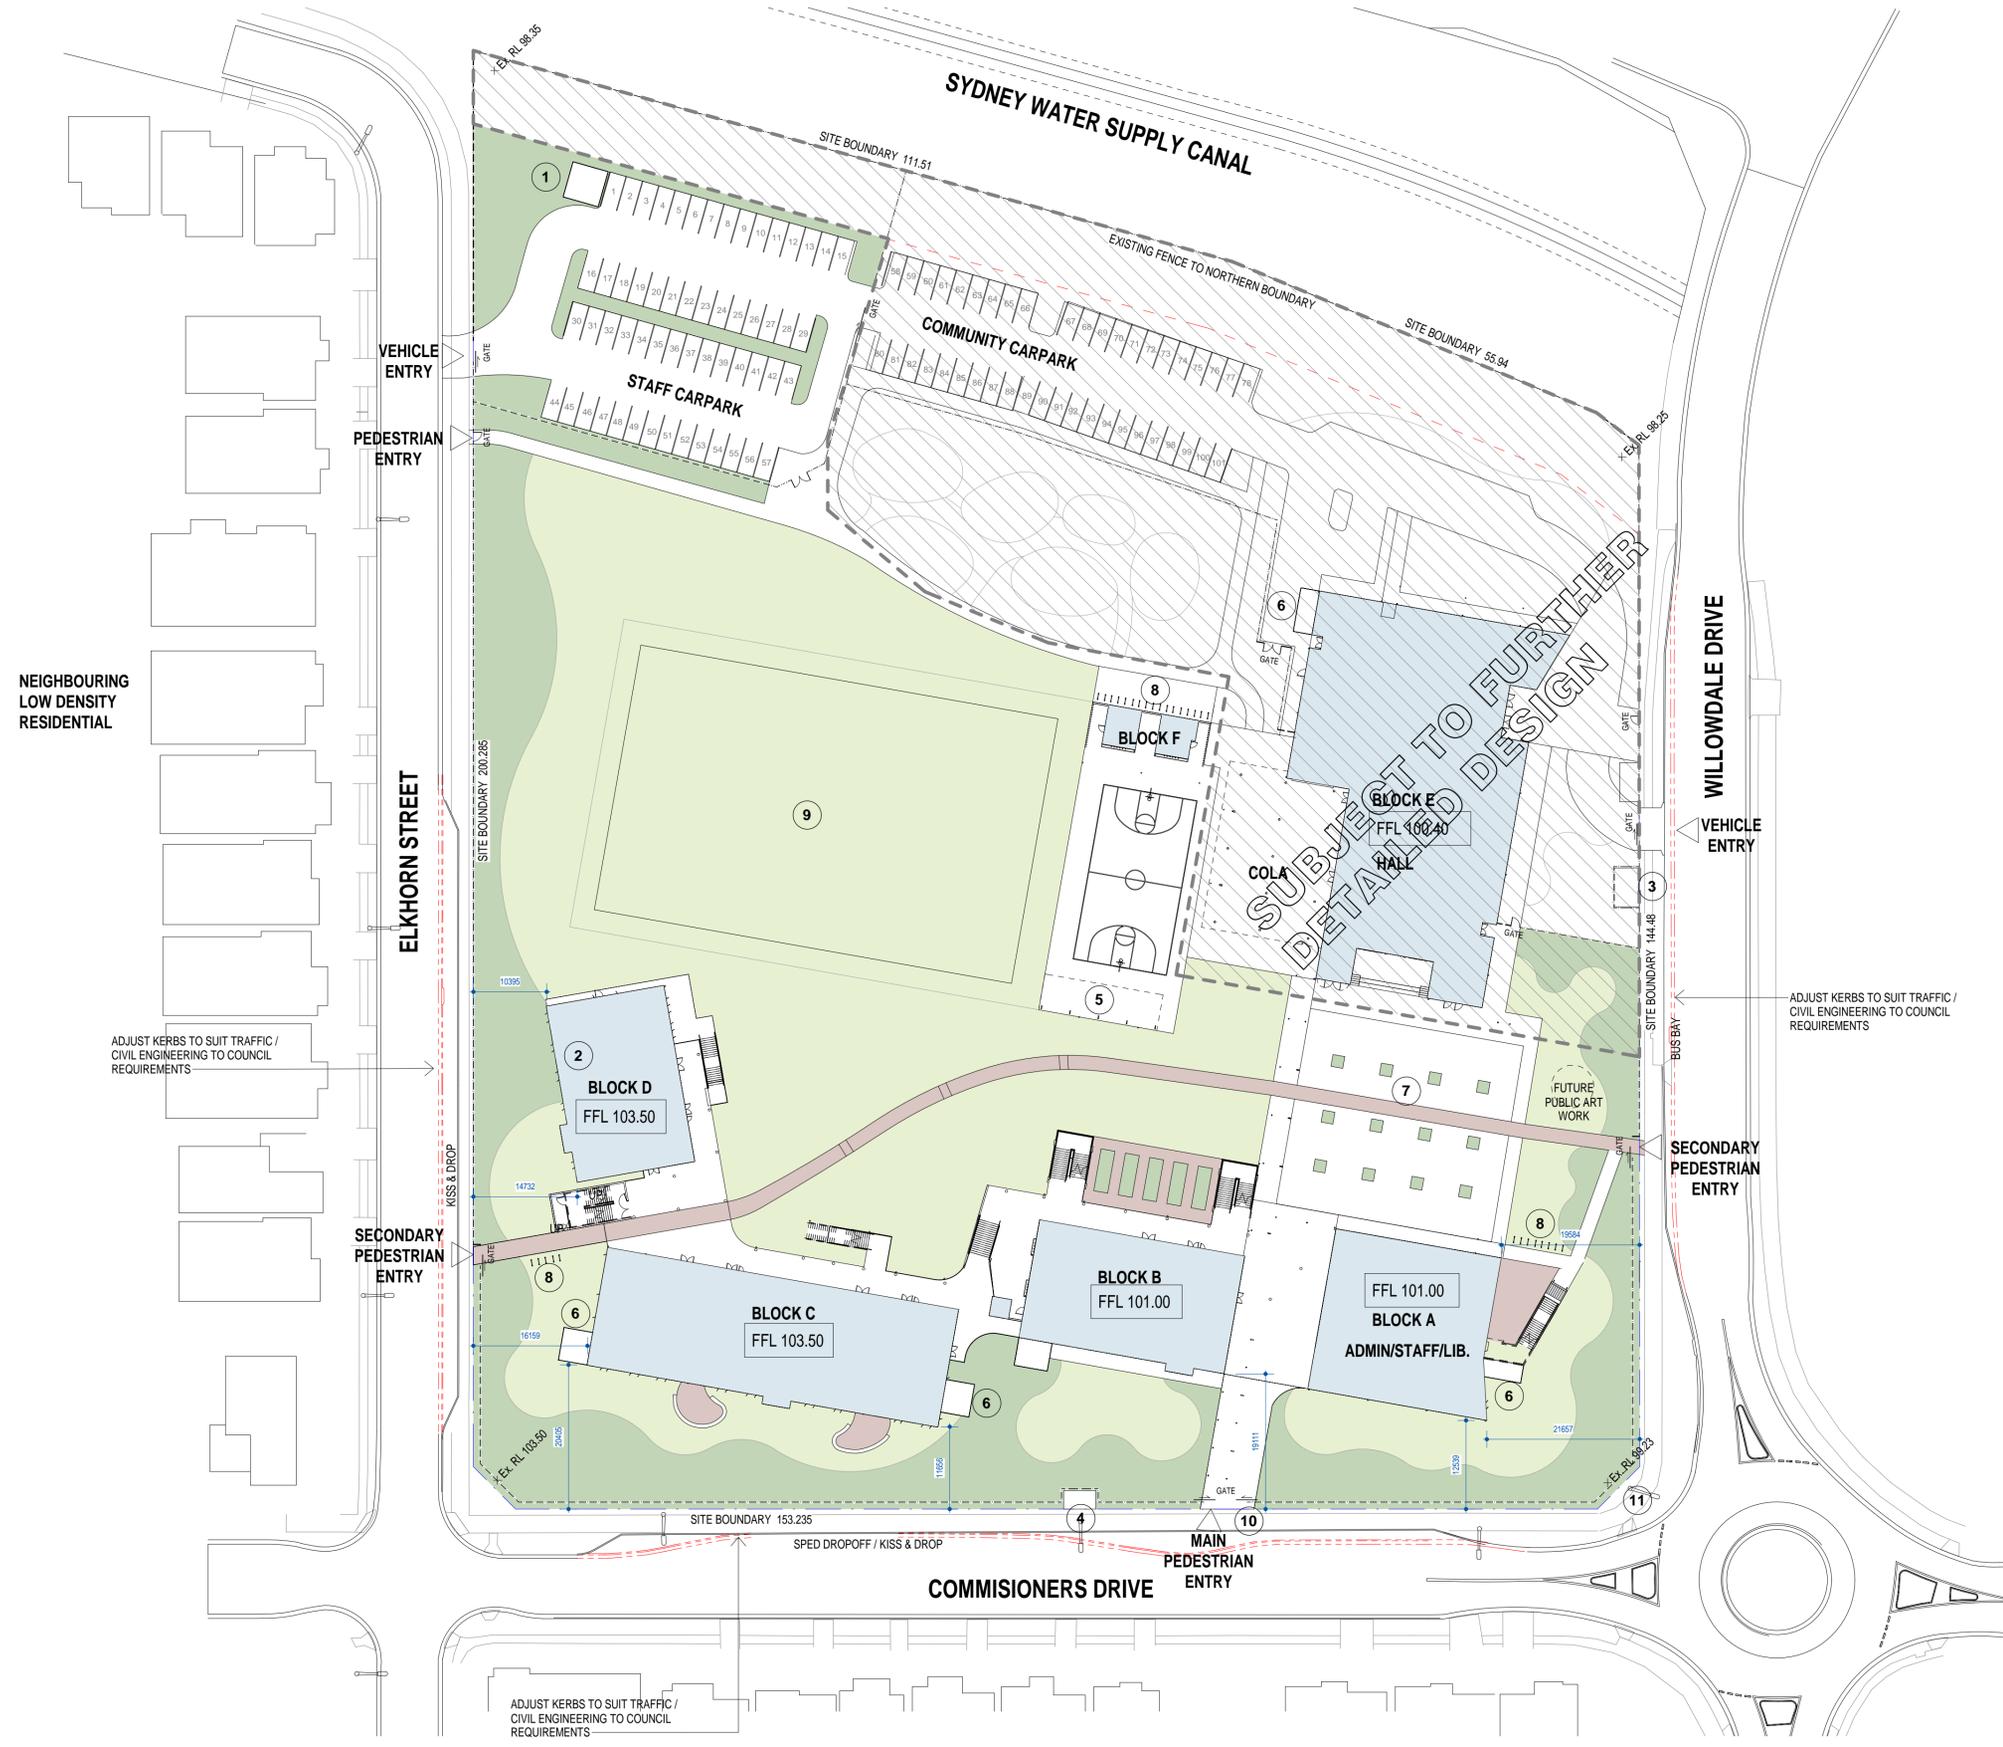

2/09/2019 6:25:33 PM

AMMENDMENTS			
REV	BY	DATE	DESCRIPTION
VL		13.08.19	PRELIMINARY ISSUE FOR REVIEW
VL		02.09.19	ISSUE FOR SDA TOA

LEGEND	

HANSEN YUNCKEN
 STRUC. CIVIL
 NORTHROP ENGINEERS
 (02) 9241 4188
 MECH. ELEC
 STEVEN WARMING
 (02) 9967 2200
 HYD
 WOOLACOTTS
 (02) 8241 9900
 FIRE
 MCD FIRE ENGINEERING
 (04) 2332 2245

NSW GOVERNMENT Education

PERUMAL PEDAVOLI ARCHITECTS
 T: 02 9291 0009
 WEB: www.pp-a.com.au
 Nominated Architect
 Licence Pedavoli NSW reg No. 5045

LANDSCAPING
 TAYLOR BRAMMER LANDS. ARCH.
 (02) 9387 8855

PERUMAL PEDAVOLI ARCHITECTS

**EAST LEPPINGTON PS
 NEW HIGH QUALITY CLASSROOMS**

DRAWING NAME
OVERALL SITE PLAN

PROJECT NORTH

0 5000 10000 15000 20000 25000 30000
 SCALE 1:500 @ A1

DRAWN	CHECKED	VERIFIED	DATE
Author	Checker	Approver	2 September 2019

DRAWING NUMBER
 PROJECT CODE SCH. REF. DISC. TYPE SERIES# REVISION

NHQ2 - LP - AR - SSDA - 00_002 **A**

DRAFT ISSUE

SUBJECT TO FURTHER
DETAILED DESIGN

COLA

BLOCK E

BLOCK D

FFL 100.50

SHADE STRUCTURE

BLOCK C

BLOCK B

FFL 101.00

BLOCK A

00_S012
JOIN LINE

2/09/2019 6:27:00 PM

DRAFT ISSUE

REV	BY	DATE	DESCRIPTION
VL		13.08.19	PRELIMINARY ISSUE FOR REVIEW
VL		02.09.19	ISSUE FOR SSDA TOA

LEGEND	OUTDOOR PLANT	TEACHING SPACE
ADMIN/STAFF	OUTDOOR PLANT	TEACHING SPACE
AMENITIES	SERVICES	
HALL	SPECIAL EDUCATION	
LIBRARY	SPECIAL PROGRAMS	

HANSEN YUNCKEN
STRUC. CIVIL
NORTHROP ENGINEERS
(02) 9241 4188
MECH. ELEC
STEINER WARMING
(02) 9967 2200
HYD
WOOLACOTTS
(02) 8241 9900
FIRE
MCD FIRE ENGINEERING
(04) 2392 2745

NSW
GOVERNMENT
Education

PERUMAL PEDAVOLI ARCHITECTS
T: 02 9291 0009
WEB: www.pp-a.com.au
Nominated Architect
Voice Pedavoli NSW reg No.5045

LANDSCAPING
TAYLOR BRAMMER LANDS. ARCH.
(02) 9387 8855

PERUMAL PEDAVOLI ARCHITECTS
EAST LEPPINGTON PS
NEW HIGH QUALITY CLASSROOMS
DRAWING NAME
COMPOSITE FLOOR PLAN - LEVEL
00 BLOCK A&B

PROJECT NORTH				SCALE 1:200 @ A1			
DRAWN	CHECKED	VERIFIED	DATE				
Author	Checker	Approver	2 September 2019				
DRAWING NUMBER				REVISION			
PROJECT CODE	SCH. REF.	DISC.	TYPE	SERIES#			
NHQ2 - LP - AR -SSDA-00_011				A			

2/09/2019 6:27:28 PM




JOIN LINE
00_S011

SPORTS FIELD

SHADE STRUCTURE

SUBJECT TO FURTHER DETAILED DESIGN

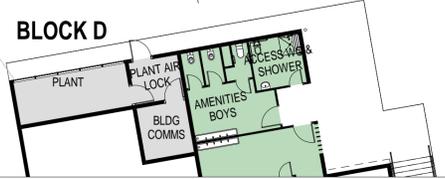

REV	BY	DATE	DESCRIPTION
A	VL	13.08.19	PRELIMINARY ISSUE FOR REVIEW
	VL	02.09.19	ISSUE FOR SSDA TOA

LEGEND
ADMIN/STAFF
AMENITIES
HALL
LIBRARY

OUTDOOR PLANT	TEACHING SPACE
SERVICES	
SPECIAL EDUCATION	
SPECIAL PROGRAMS	

HANSEN YUNCKEN
 STRUC. CIVIL
 NORTHROP ENGINEERS
 (02) 9241 4188
 MECH. ELEC
 STEINER WARMING
 (02) 9967 2200
 HYD
 WOOLACOTT'S
 (02) 8241 9900
 FIRE
 MID FIRE ENGINEERING
 (04) 2392 2745

NSW GOVERNMENT Education

PERUMAL PEDAVOLI ARCHITECTS
 T: 02 9291 0009
 WEB: www.pp-a.com.au
 Nominated Architect:
 Vince Pedavoli NSW reg No.5045

LANDSCAPING
 TAYLOR BRAMMER LANDS. ARCH.
 (02) 9387 8855

PERUMAL PEDAVOLI ARCHITECTS

EAST LEPPINGTON PS
 NEW HIGH QUALITY CLASSROOMS

DRAWING NAME
 COMPOSITE FLOOR PLAN - LEVEL
 00 BLOCK E

PROJECT NORTH				SCALE 1:200 @ A1			
DRAWN	CHECKED	VERIFIED	DATE				
Author	Checker	Approver	2 September 2019				
DRAWING NUMBER				REVISION			
PROJECT CODE	SCH. REF.	DISC.	TYPE	SERIES#			
NHQ2 - LP - AR -SSDA-00_012				A			

DRAFT ISSUE

2/09/2019 6:30:13 PM



REV	BY	DATE	DESCRIPTION
A	VL	13.08.19	PRELIMINARY ISSUE FOR REVIEW
	VL	02.09.19	ISSUE FOR SSDA TOA

LEGEND	
[Symbol]	[Description]

HANSEN YUNCKEN
 STRUC. CIVIL
 NORTHROP ENGINEERS
 (02) 9241 4188
 MECH. ELEC
 STEINER WARMING
 (02) 9967 2200
 HYD
 WOOLACOTT'S
 (02) 8241 9900
 FIRE
 MCD FIRE ENGINEERING
 (04) 2392 2245

PERUMAL PEDAVOLI ARCHITECTS
 T: 02 9291 0000
 WEB: www.pp-a.com.au
 Nominated Architect
 Since Pedavoli NSW reg No.5045

PERUMAL PEDAVOLI ARCHITECTS





**EAST LEPPINGTON PS
 NEW HIGH QUALITY CLASSROOMS**
 DRAWING NAME
**COMPOSITE FLOOR PLAN - LEVEL
 01 BLK A&B, LEVEL 00 BLK C&D**

PROJECT NORTH				SCALE 1:200 @ A1			
DRAWN	CHECKED	VERIFIED	DATE	Author	Checker	Approver	2 September 2019
DRAWING NUMBER							
PROJECT CODE SCH. REF. DISC. TYPE SERIES#							
NHQC2 - LP - AR -SSDA-00_013							A

DRAFT ISSUE

2/09/2019 6:32:38 PM

DRAFT ISSUE

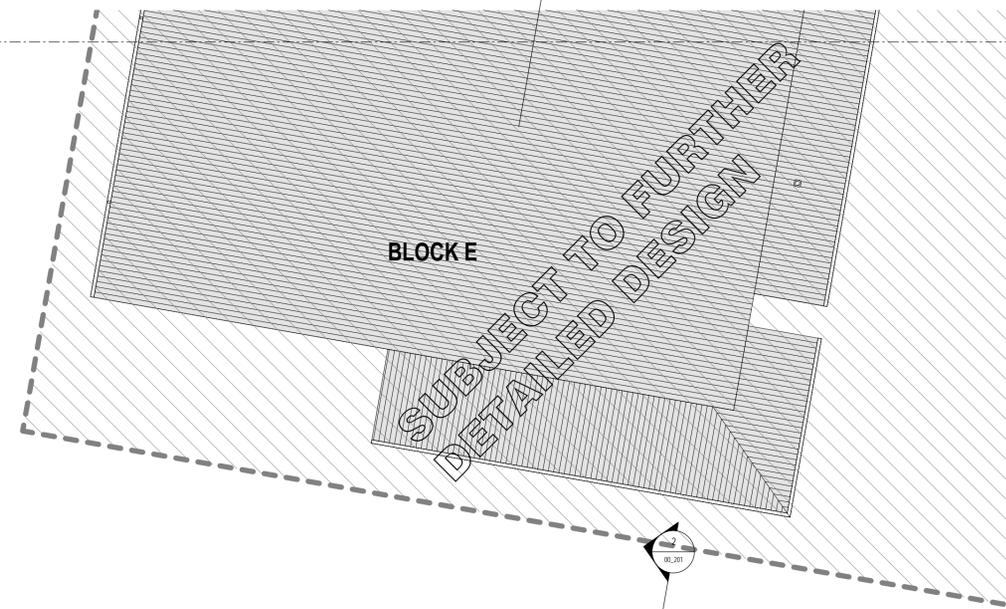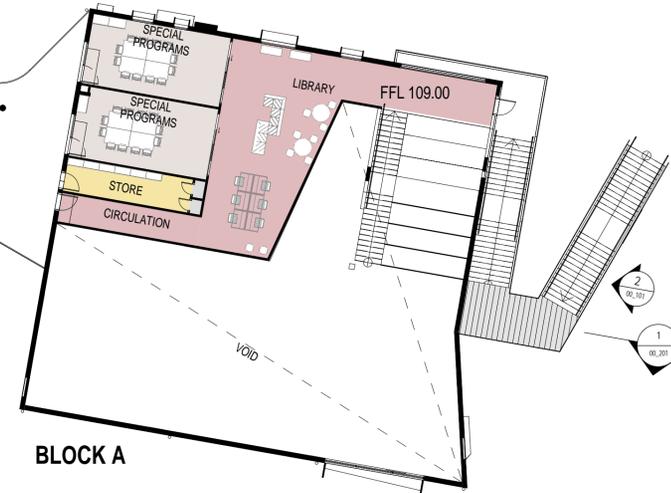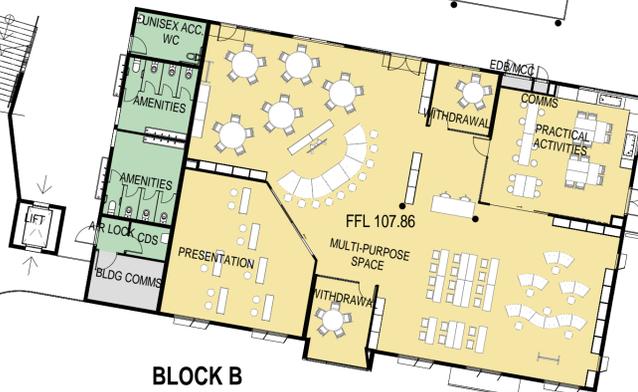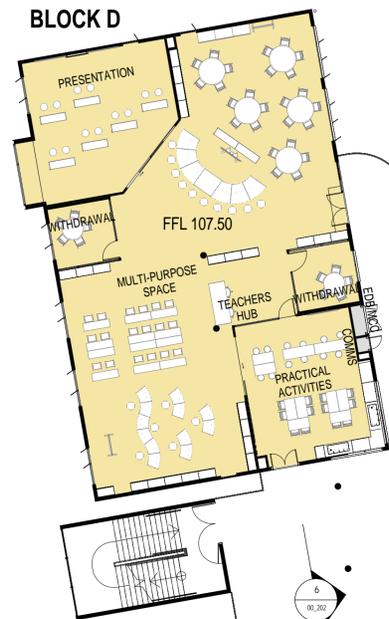

REV	BY	DATE	DESCRIPTION
A	VL	13.08.19	PRELIMINARY ISSUE FOR REVIEW
	VL	02.09.19	ISSUE FOR SSDA TOA

LEGEND



STRUC. CIVIL
 NORTHROP ENGINEERS
 (02) 9241 4188
 MECH. ELEC
 STEINER WARMING
 (02) 9967 2200
 HYD
 WOOLACOTTS
 (02) 8241 9900
 FIRE
 MCD FIRE ENGINEERING
 (04) 2392 2245

PERUMAL PEDAVOLI ARCHITECTS
 T: 02 9291 0009
 WEB: www.pp-a.com.au
 Nominated Architect
 Since Pedavoli NSW reg No.5045

PERUMAL PEDAVOLI ARCHITECTS


**EAST LEPPINGTON PS
 NEW HIGH QUALITY CLASSROOMS**
 DRAWING NAME
**COMPOSITE FLOOR PLAN - LEVEL
 02 BLK A&B, LEVEL 01 BLK C&D**



PROJECT NORTH				SCALE 1:200 @ A1			
DRAWN	CHECKED	VERIFIED	DATE				
Author	Checker	Approver	2 September 2019				
DRAWING NUMBER				REVISION			
PROJECT CODE	SCH. REF.	DISC.	TYPE	SERIES#			
NHQ2 - LP - AR -SSDA-00_014				A			

2/09/2019 6:33:59 PM

DRAFT ISSUE

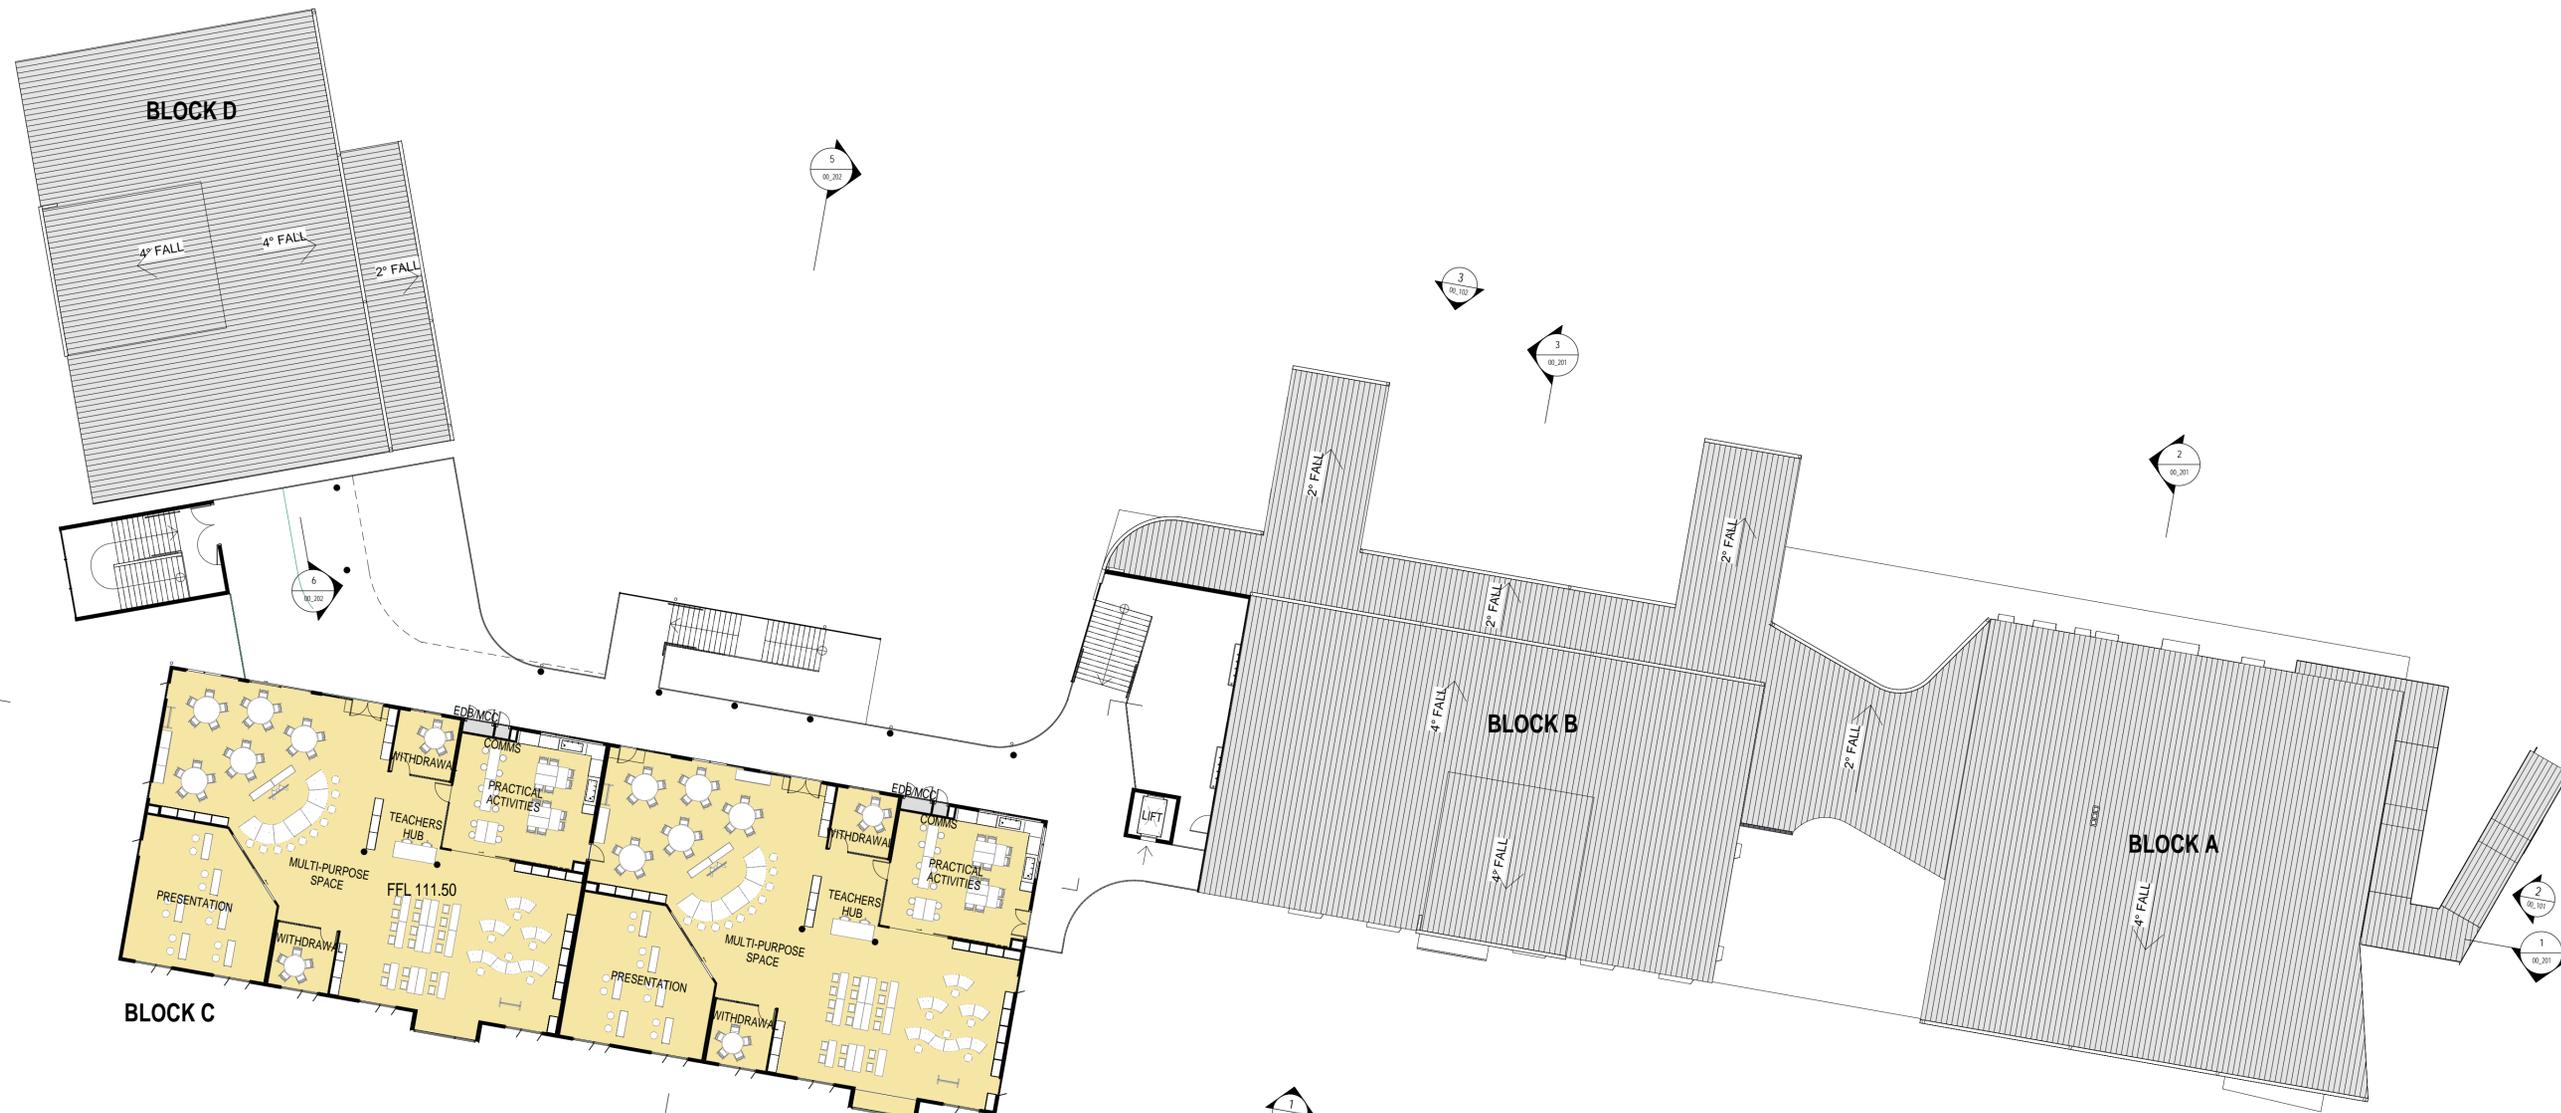

REV	BY	DATE	DESCRIPTION
VL		13.08.19	PRELIMINARY ISSUE FOR REVIEW
A	VL	02.09.19	ISSUE FOR SSDA TOA

LEGEND










STRUC. CIVIL
NORTHROP ENGINEERS
(02) 9241 4188
MECH. ELEC
STENSHAW WARMING
(02) 9967 2200
HYD
WOOLACOTT'S
(02) 8241 9900
FIRE
MCD FIRE ENGINEERING
(04) 2332 2745

PERUMAL PEDAVOLI ARCHITECTS
T: 02 9291 0000
WEB: www.pp-a.com.au
Nominated Architect
Vince Pedavoli NSW reg No.5045

PERUMAL PEDAVOLI ARCHITECTS
EAST LEPPINGTON PS
NEW HIGH QUALITY CLASSROOMS
DRAWING NAME
COMPOSITE FLOOR PLAN - LEVEL
02 BLOCK C

PROJECT NORTH				SCALE 1:200 @ A1			
DRAWN	CHECKED	VERIFIED	DATE				
Author	Checker	Approver	2 September 2019				
DRAWING NUMBER			REVISION				
NHQC2 - LP - AR -SSDA-00_015			A				

00_022
JOIN LINE

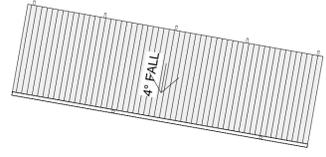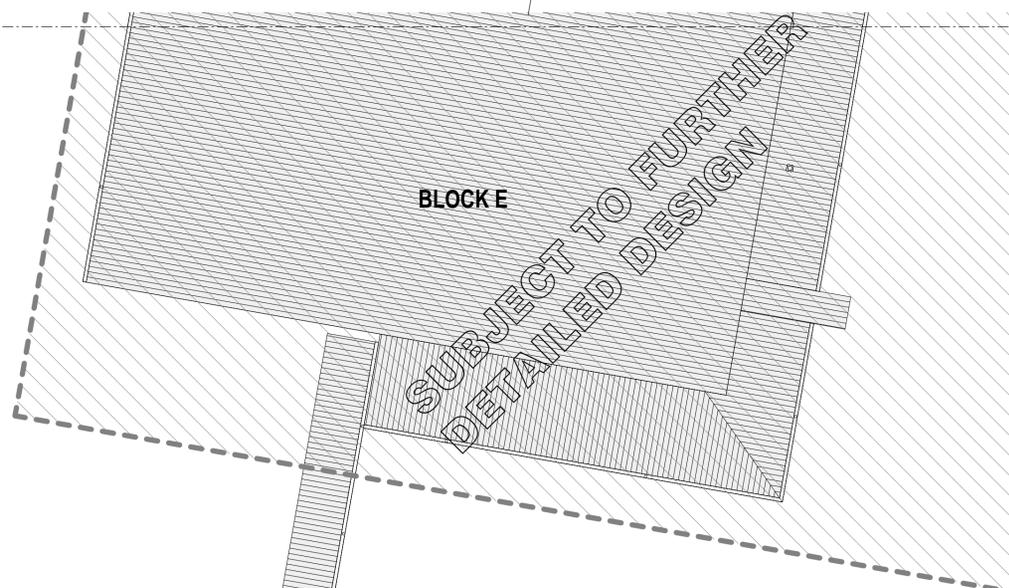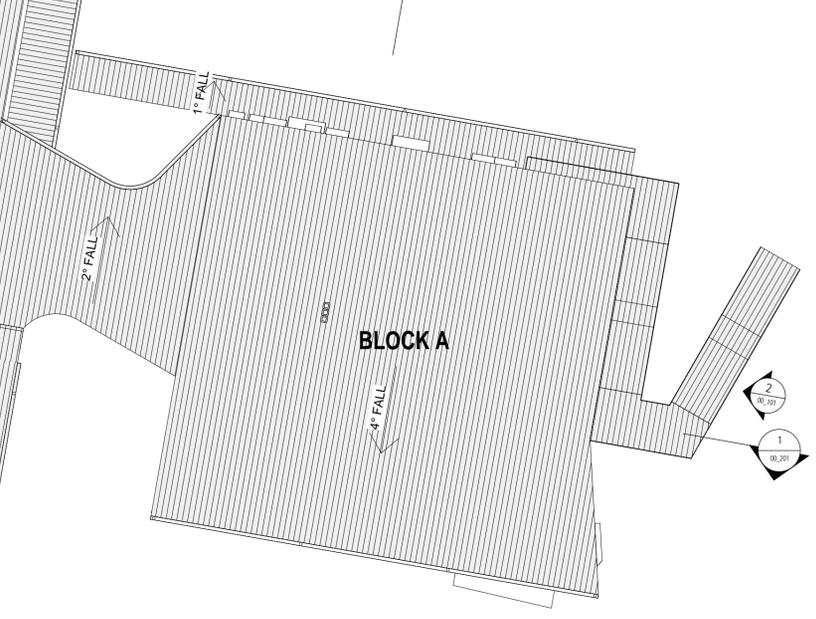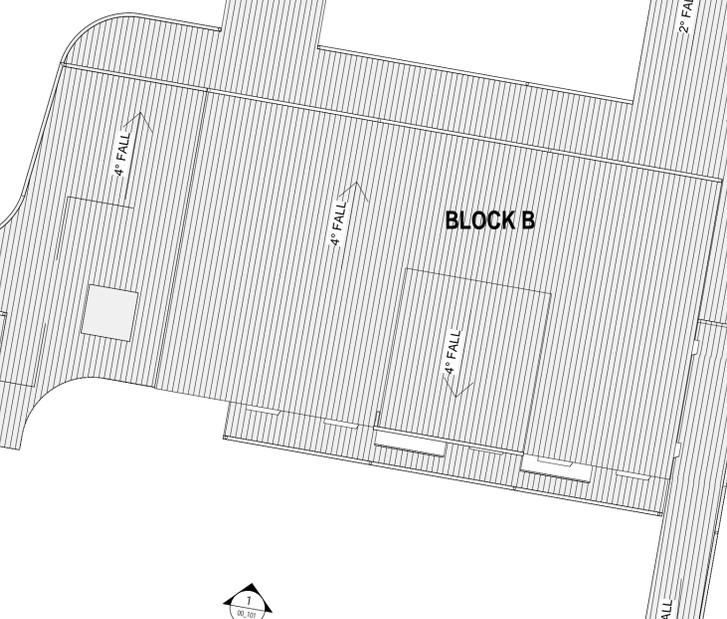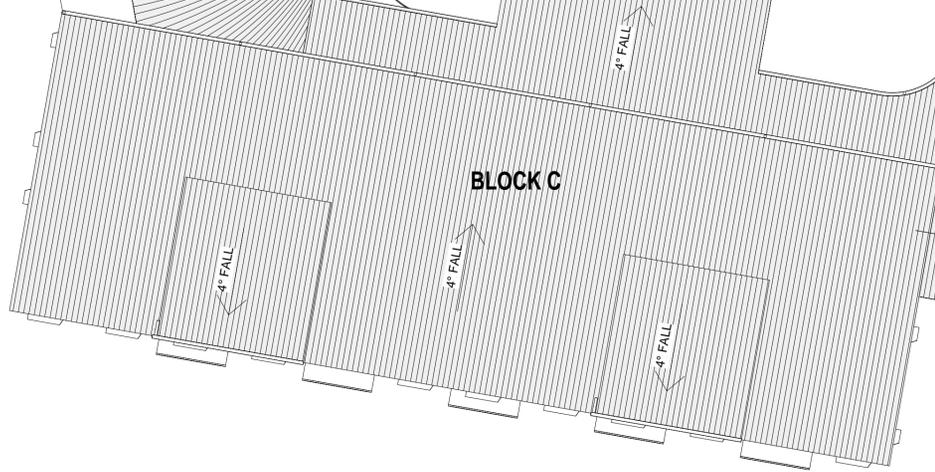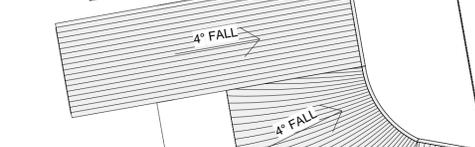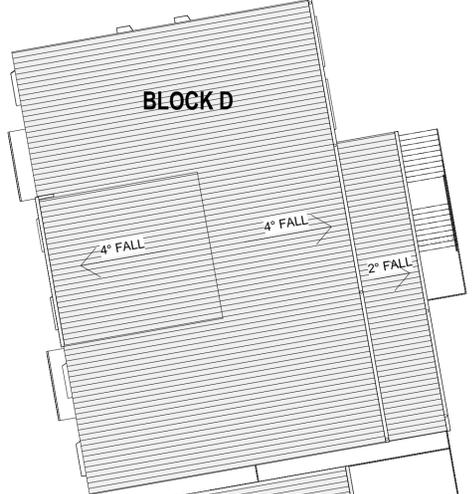

2/09/2019 6:34:18 PM

REV	BY	DATE	DESCRIPTION
VL		13.08.19	PRELIMINARY ISSUE FOR REVIEW
A	VL	02.09.19	ISSUE FOR SSDA TOA

LEGEND



STRUC. CIVIL
NORTHROP ENGINEERS
(02) 9241 4188
MECH. ELEC
STENSON WARMING
(02) 9967 2200
HYD
WOOLACOTTS
(02) 8241 9900
FIRE
MCD FIRE ENGINEERING
(04) 2392 2745

PERUMAL PEDAVOLI ARCHITECTS
T: 02 9291 0000
WEB: www.pp-a.com.au
Nominated Architect:
Vince Pedavoli NSW reg No.5045

PERUMAL PEDAVOLI ARCHITECTS
EAST LEPPINGTON PS
NEW HIGH QUALITY CLASSROOMS
DRAWING NAME
COMPOSITE ROOF PLAN - PART 1


PROJECT NORTH				SCALE 1:200 @ A1			
DRAWN	CHECKED	VERIFIED	DATE				
Author	Checker	Approver	2 September 2019				
DRAWING NUMBER				REVISION			
NHQC2 - LP - AR - SSDA - 00_021				A			

DRAFT ISSUE



SUBJECT TO FURTHER
DETAILED DESIGN

JOIN LINE
00_021

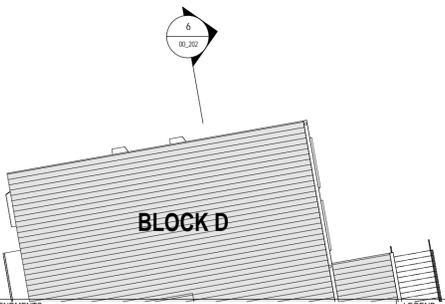

2/09/2019 6:34:30 PM

DRAFT ISSUE

AMMENDMENTS			
REV	BY	DATE	DESCRIPTION
A	VL	13.08.19	PRELIMINARY ISSUE FOR REVIEW
	VL	02.09.19	ISSUE FOR SSDA ToA

LEGEND	

 
HANSEN YUNCKEN

STRUC. CIVIL
NORTHROP ENGINEERS
(02) 9241 4188
MECH. ELEC
STENSHAM WARMING
(02) 9967 2200
HYD
WOOLACOTTS
(02) 8241 9900
FIRE
MCD FIRE ENGINEERING
(04) 2392 2745

PERUMAL PEDAVOLI ARCHITECTS
T: 02 9291 0009
WEB: www.pp-a.com.au
Nominated Architect:
Vince Pedavoli NSW reg No.5045

**PERUMAL
PEDAVOLI
ARCHITECTS**

**EAST LEPPINGTON PS
NEW HIGH QUALITY CLASSROOMS**
DRAWING NAME
COMPOSITE ROOF PLAN - PART 2



DRAWN				CHECKED				VERIFIED				DATE			
Author	Checker	Approver													
DRAWING NUMBER														REVISION	
NHQC2 - LP - AR -SSDA-00_022														A	


SCALE: 1:200 @ A1

2 September 2019

A



1 SOUTH ELEVATION
1 : 200

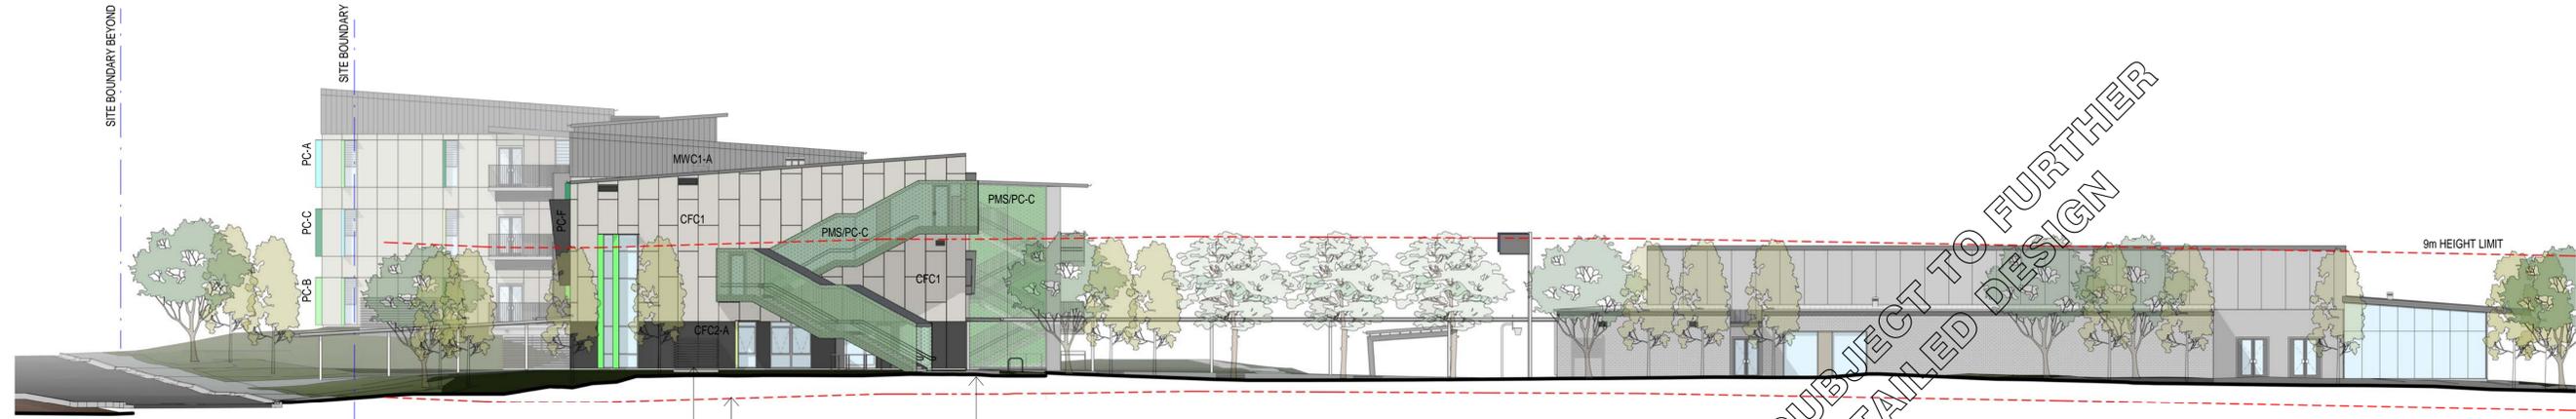

2 EAST ELEVATION
1 : 200

SUBJECT TO FURTHER
DETAILED DESIGN

2/09/2019 6:37:35 PM

DRAFT ISSUE

REV	BY	DATE	DESCRIPTION
VL		13.08.19	PRELIMINARY ISSUE FOR REVIEW
VL		02.09.19	ISSUE FOR SDA ToA

LEGEND	DESCRIPTION
CFC1	- COMPRESSED FIBRE CEMENT - BARESTONE
CFC2	- COMPRESSED FIBRE CEMENT - SURROUND
CO	- CONCRETE
MR1	- METAL ROOFING
MWC1	- METAL WALL CLADDING
PC	- POWDERCOAT

HANSEN YUNCKEN
NSW GOVERNMENT Education

STRUC. CIVIL
NORTHROP ENGINEERS
(02) 9241 4188
MECH. ELEC
STENSHAW WARMING
(02) 9967 2200
HYD
WOOLACOTTS
(02) 8241 9900
FIRE
MCD FIRE ENGINEERING
(04) 2392 2245

PERUMAL PEDAVOLI ARCHITECTS
T: 02 9291 0000
WEB: www.pp-a.com.au
Nominated Architect
Vince Pedavoli NSW reg No.5045


PERUMAL PEDAVOLI ARCHITECTS

EAST LEPPINGTON PS
NEW HIGH QUALITY CLASSROOMS
DRAWING NAME
OVERALL ELEVATIONS - SHEET 01


PROJECT NORTH				SCALE 1 : 200 @ A1	
DRAWN	CHECKED	VERIFIED	DATE		
Author	Checker	Approver	2 September 2019		
DRAWING NUMBER			REVISION		
PROJECT CODE	SCH. REF.	DISC.	TYPE	SERIES#	
NHQC2 - LP - AR - SSDA - 00_101					A



1 OVERALL SECTION 1
1 : 200

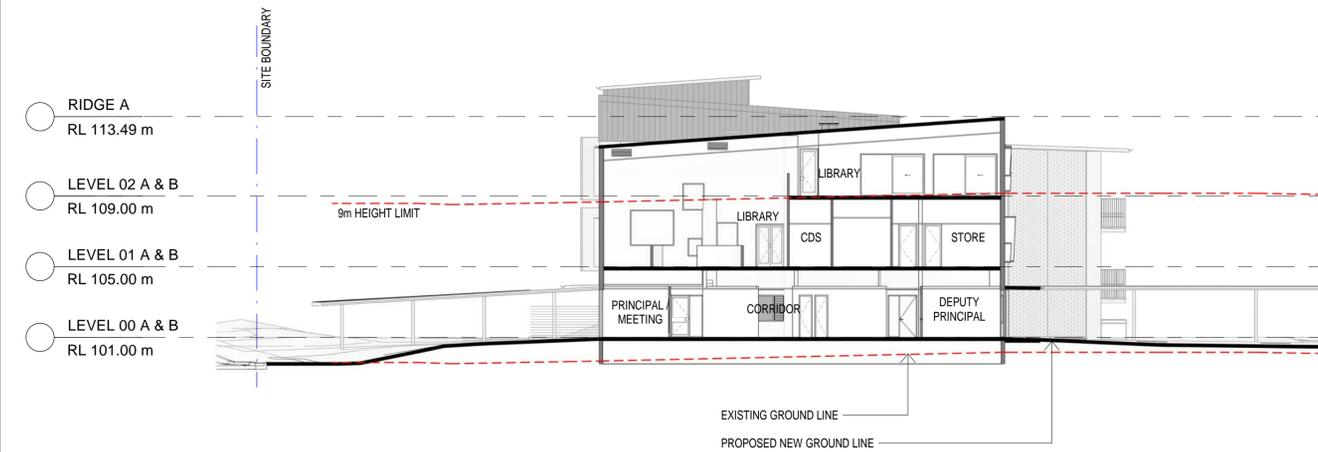

2 OVERALL SECTION 2 - BLOCK A
1 : 200

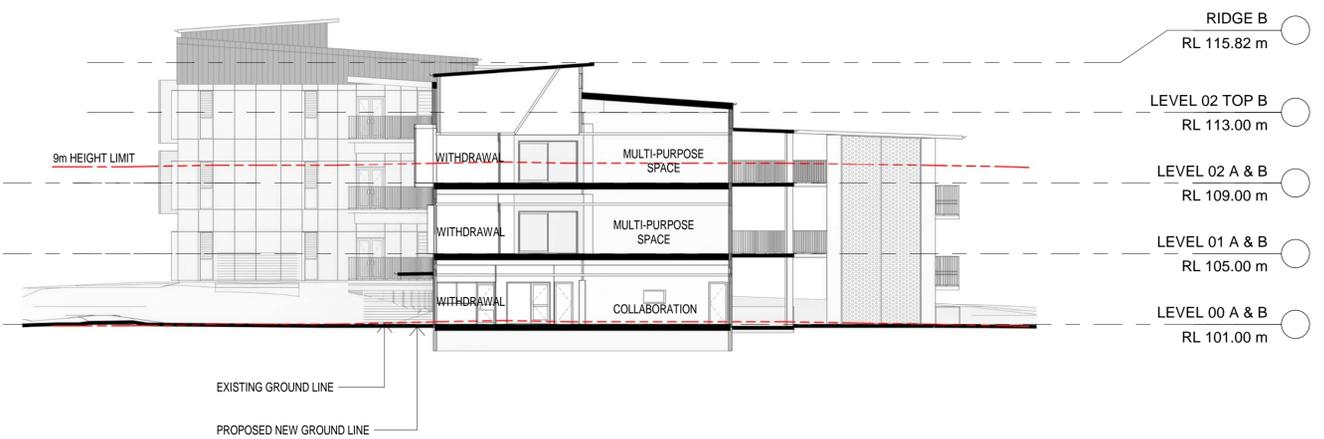

3 OVERALL SECTION 3 - BLOCK B
1 : 200

2/09/2019 6:39:19 PM

REV	BY	DATE	DESCRIPTION
VL		13.08.19	PRELIMINARY ISSUE FOR REVIEW
A	VL	02.09.19	ISSUE FOR SDA TOA

LEGEND



STRUC. CIVIL
NORTHROP ENGINEERS
(02) 9241 4188
MECH. ELEC
STENSHAW WARMING
(02) 9967 2200
HYD
WOOLACOTT'S
(02) 8241 9900
FIRE
MCD FIRE ENGINEERING
(04) 2392 2245


PERUMAL PEDAVOLI ARCHITECTS
T: 02 9291 0000
WEB: www.pp-a.com.au
Nominated Architect:
Vince Pedavoli NSW reg No. 5045

PERUMAL
PEDAVOLI
ARCHITECTS


EAST LEPPINGTON PS
NEW HIGH QUALITY CLASSROOMS
DRAWING NAME
OVERALL SECTIONS - SHEET 1

PROJECT NORTH	0	2000	4000	6000	8000	10000	20000	SCALE: 1:200 @ A1
DRAWN	CHECKED	VERIFIED	DATE					
Author	Checker	Approver	2 September 2019					
DRAWING NUMBER								REVISION
PROJECT CODE	SCH. REF.	DISC.	TYPE	SERIES#				
NHQ2 - LP - AR - SSDA - 00_201								A

DRAFT ISSUE

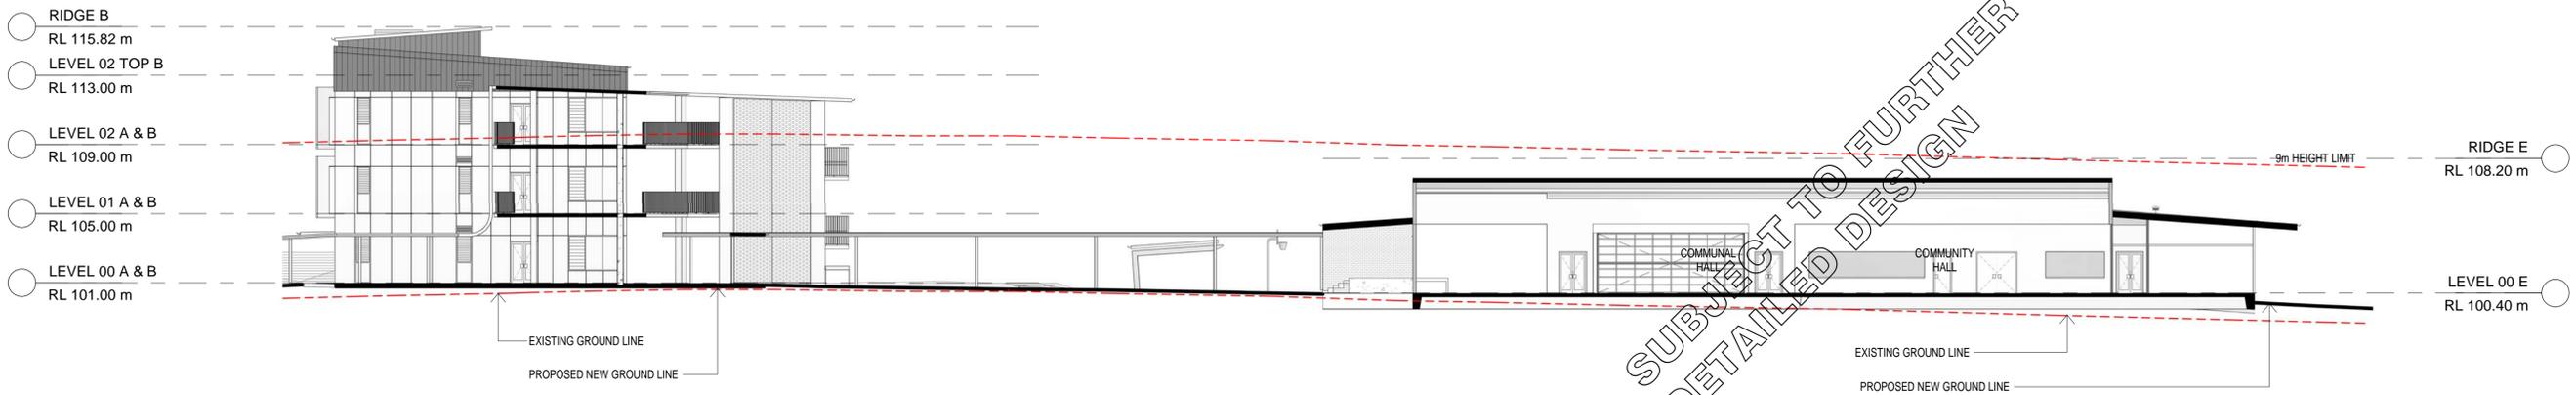

4 OVERALL SECTION 4
1:200

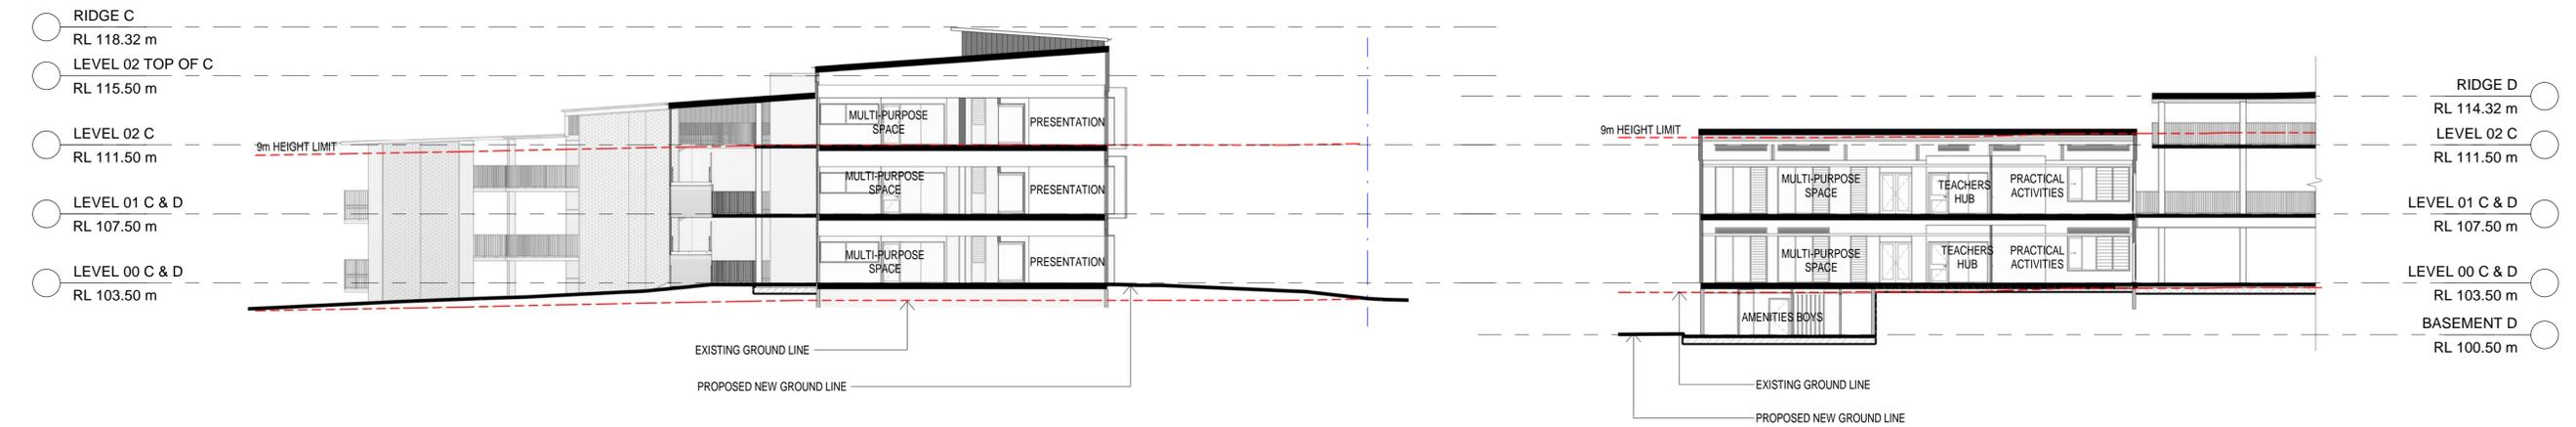

5 OVERALL SECTION 5 - BLOCK C
1:200

6 OVERALL SECTION 6 - BLOCK D
1:200

SUBJECT TO FURTHER
DETAILED DESIGN

2/09/2019 6:40:09 PM

DRAFT ISSUE

REV	BY	DATE	DESCRIPTION
VL		13.08.19	PRELIMINARY ISSUE FOR REVIEW
A	VL	02.09.19	ISSUE FOR SDA ToA

LEGEND

HANSEN YUNCKEN
NSW GOVERNMENT Education

STRUC. CIVIL
NORTHROP ENGINEERS
(02) 9241 4188
MECH. ELEC
STENSON WARMING
(02) 9967 2200
HYD
WOOLACOTT'S
(02) 8241 9900
FIRE
MCD FIRE ENGINEERING
(04) 2392 2245

PERUMAL PEDAVOLI ARCHITECTS
T: 02 9291 0000
WEB: www.pp-a.com.au
Nominated Architect:
Vince Pedavoli NSW reg No.5045

PERUMAL PEDAVOLI
ARCHITECTS

EAST LEPPINGTON PS
NEW HIGH QUALITY CLASSROOMS
DRAWING NAME
OVERALL SECTIONS - SHEET 2

PROJECT NORTH


SCALE 1:200 @ A1

DRAWN	CHECKED	VERIFIED	DATE
Author	Checker	Approver	2 September 2019

DRAWING NUMBER

PROJECT CODE	SCH. REF.	DISC.	TYPE	SERIES#	REVISION
NHQC2 - LP - AR - SSSA - 00_202					A

2/09/2019 6:41:31 PM

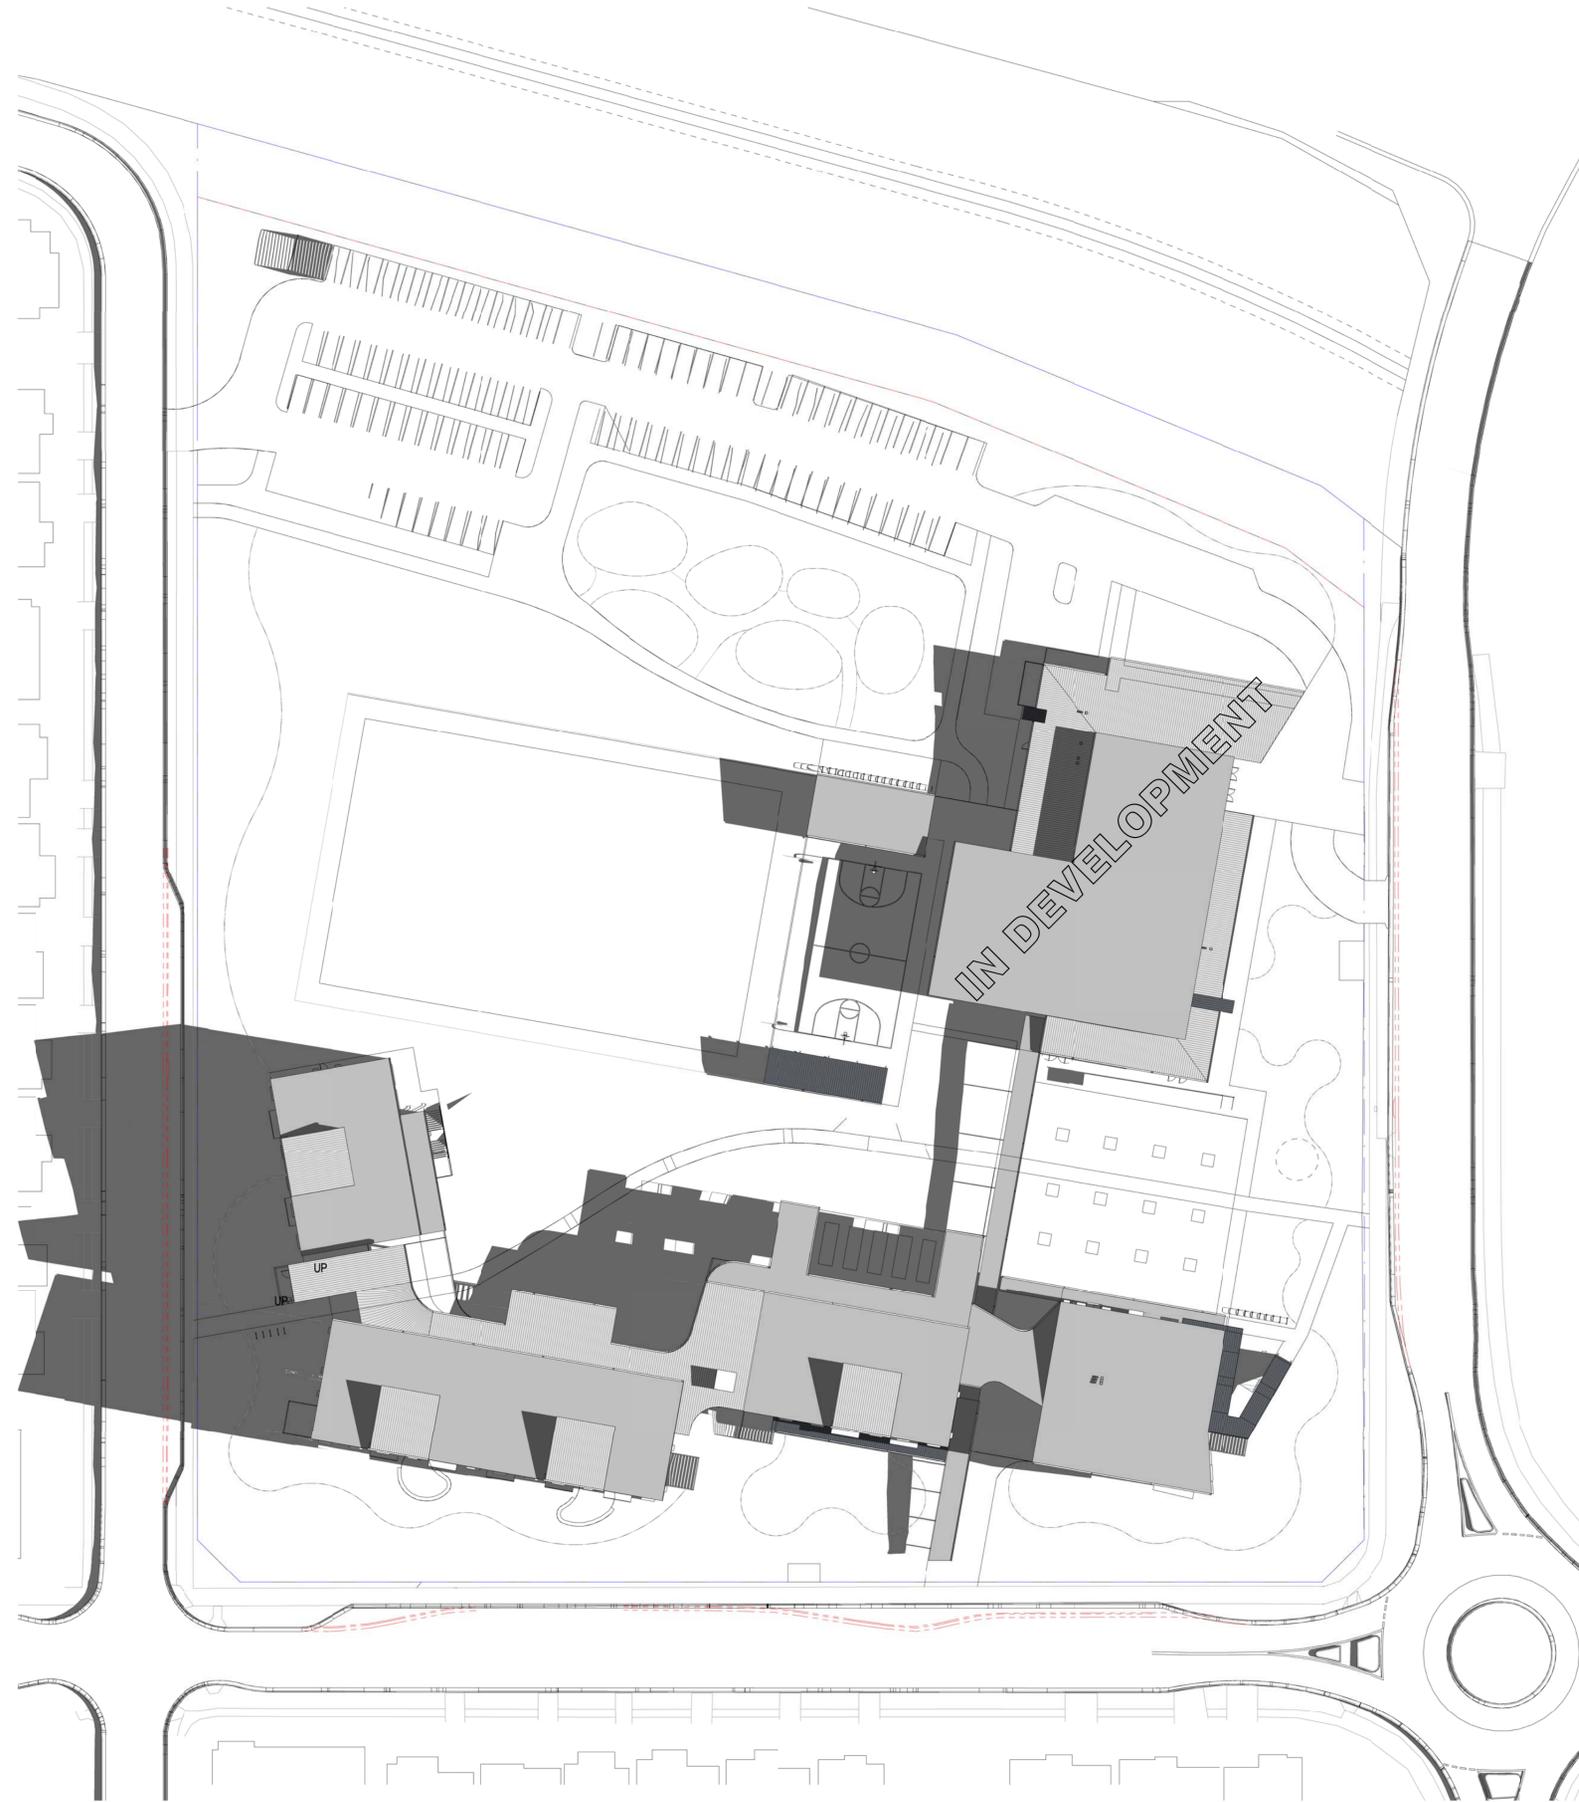

AMMENDMENTS			
REV	BY	DATE	DESCRIPTION
VL		13.08.19	PRELIMINARY ISSUE FOR REVIEW
VL		02.09.19	ISSUE FOR SDA TOA

LEGEND



STRUC. CIVIL
NORTHROP ENGINEERS
(02) 9241 4188
MECH. ELEC.
STENSHEN WARMING
(02) 9967 2200
HYD.
WOOLACOTTS
(02) 8241 9900
FIRE
MCD FIRE ENGINEERING
(04) 2392 2245

PERUMAL PEDAVOLI ARCHITECTS
T: (02) 9291 0000
WEB: www.pp-a.com.au
Nominated Architect:
Vince Pedavoli NSW reg No. 5045
LANDSCAPING
TAYLOR BRAMMER LANDS. ARCH.
(02) 9387 8855

**PERUMAL
PEDAVOLI**
ARCHITECTS

**EAST LEPPINGTON PS
NEW HIGH QUALITY CLASSROOMS**
DRAWING NAME
**SHADOW EXISTING & PROPOSED -
21 JUNE 9 AM**


PROJECT NORTH

DRAWN	CHECKED	VERIFIED	DATE
Author	Checker	Approver	2 September 2019

DRAWING NUMBER	PROJECT CODE	SCH. REF.	DISC.	TYPE	SERIES#	REVISION
NHQ2 - LP - AR -SSDA-00_301						A

DRAFT ISSUE

2/09/2019 6:42:51 PM

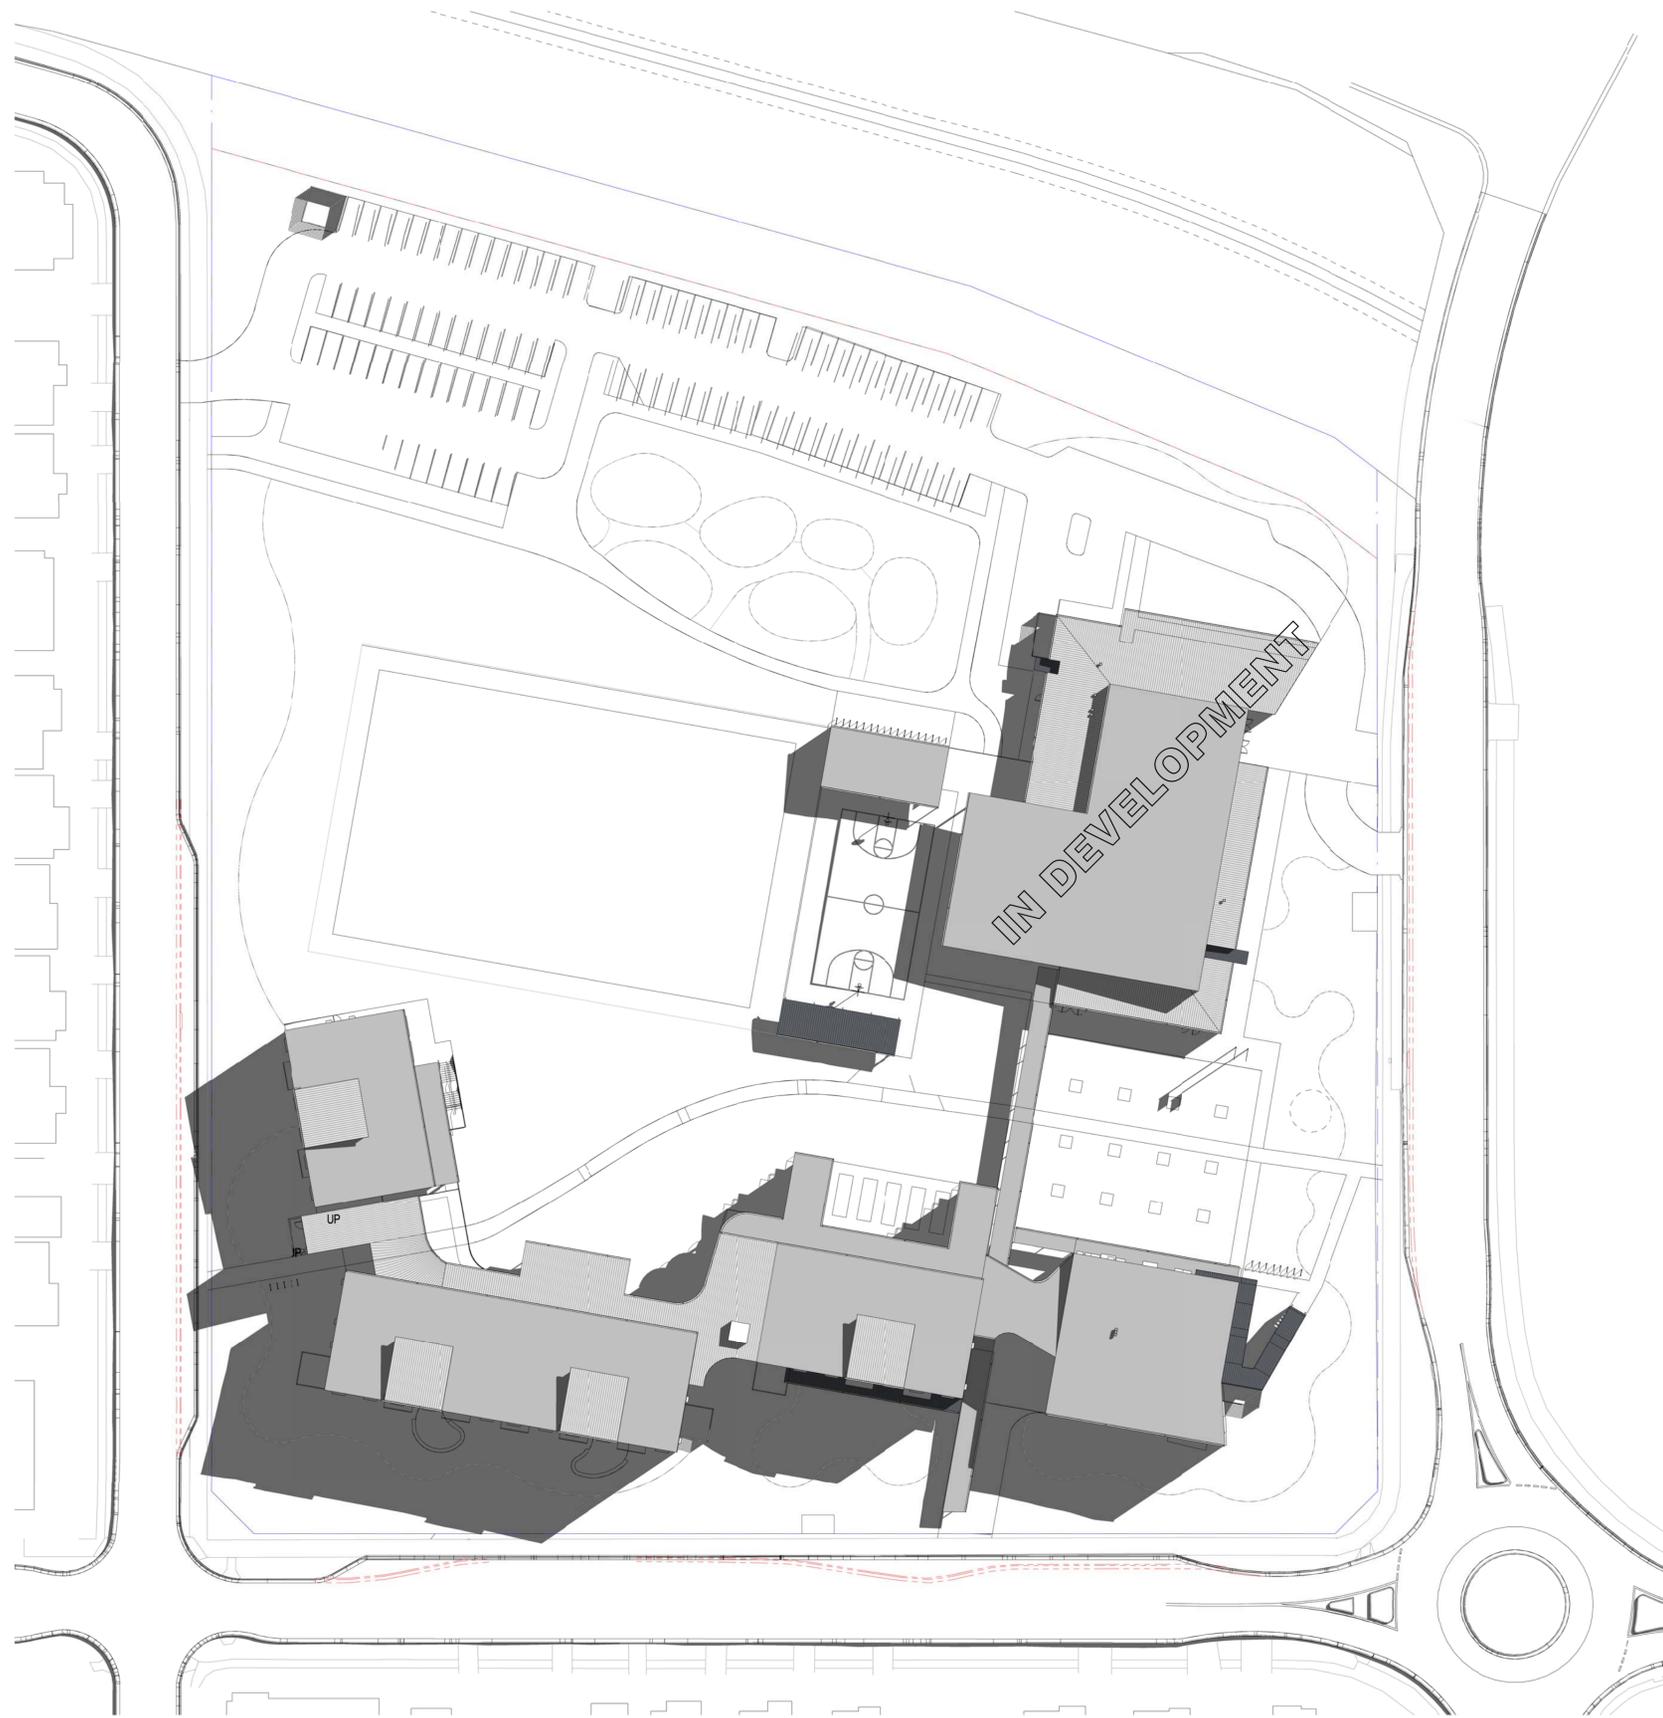

REV	BY	DATE	DESCRIPTION
VL		13.08.19	PRELIMINARY ISSUE FOR REVIEW
VL		02.09.19	ISSUE FOR SDA TOA

LEGEND



STRUC. CIVIL
NORTHROP ENGINEERS
(02) 9241 4188
MECH. ELEC
STENSHAW WARMING
(02) 9967 2200
HYD
WOOLACOTT'S
(02) 8241 9900
FIRE
MCD FIRE ENGINEERING
(04) 2392 2745

PERUMAL PEDAVOLI ARCHITECTS
T: 02 9291 0000
WEB: www.pp-a.com.au
Nominated Architect
Vince Pedavoli NSW reg No. 5045

**PERUMAL
PEDAVOLI
ARCHITECTS**

**EAST LEPPINGTON PS
NEW HIGH QUALITY CLASSROOMS**
DRAWING NAME
**SHADOW EXISTING & PROPOSED -
21 JUNE 12 PM**


PROJECT NORTH

DRAWN	CHECKED	VERIFIED	DATE
Author	Checker	Approver	2 September 2019

DRAWING NUMBER	PROJECT CODE	SCH. REF.	DISC.	TYPE	SERIES#	REVISION
NHQ2 - LP - AR -SSDA-00_302						A

DRAFT ISSUE

2/09/2019 6:44:20 PM

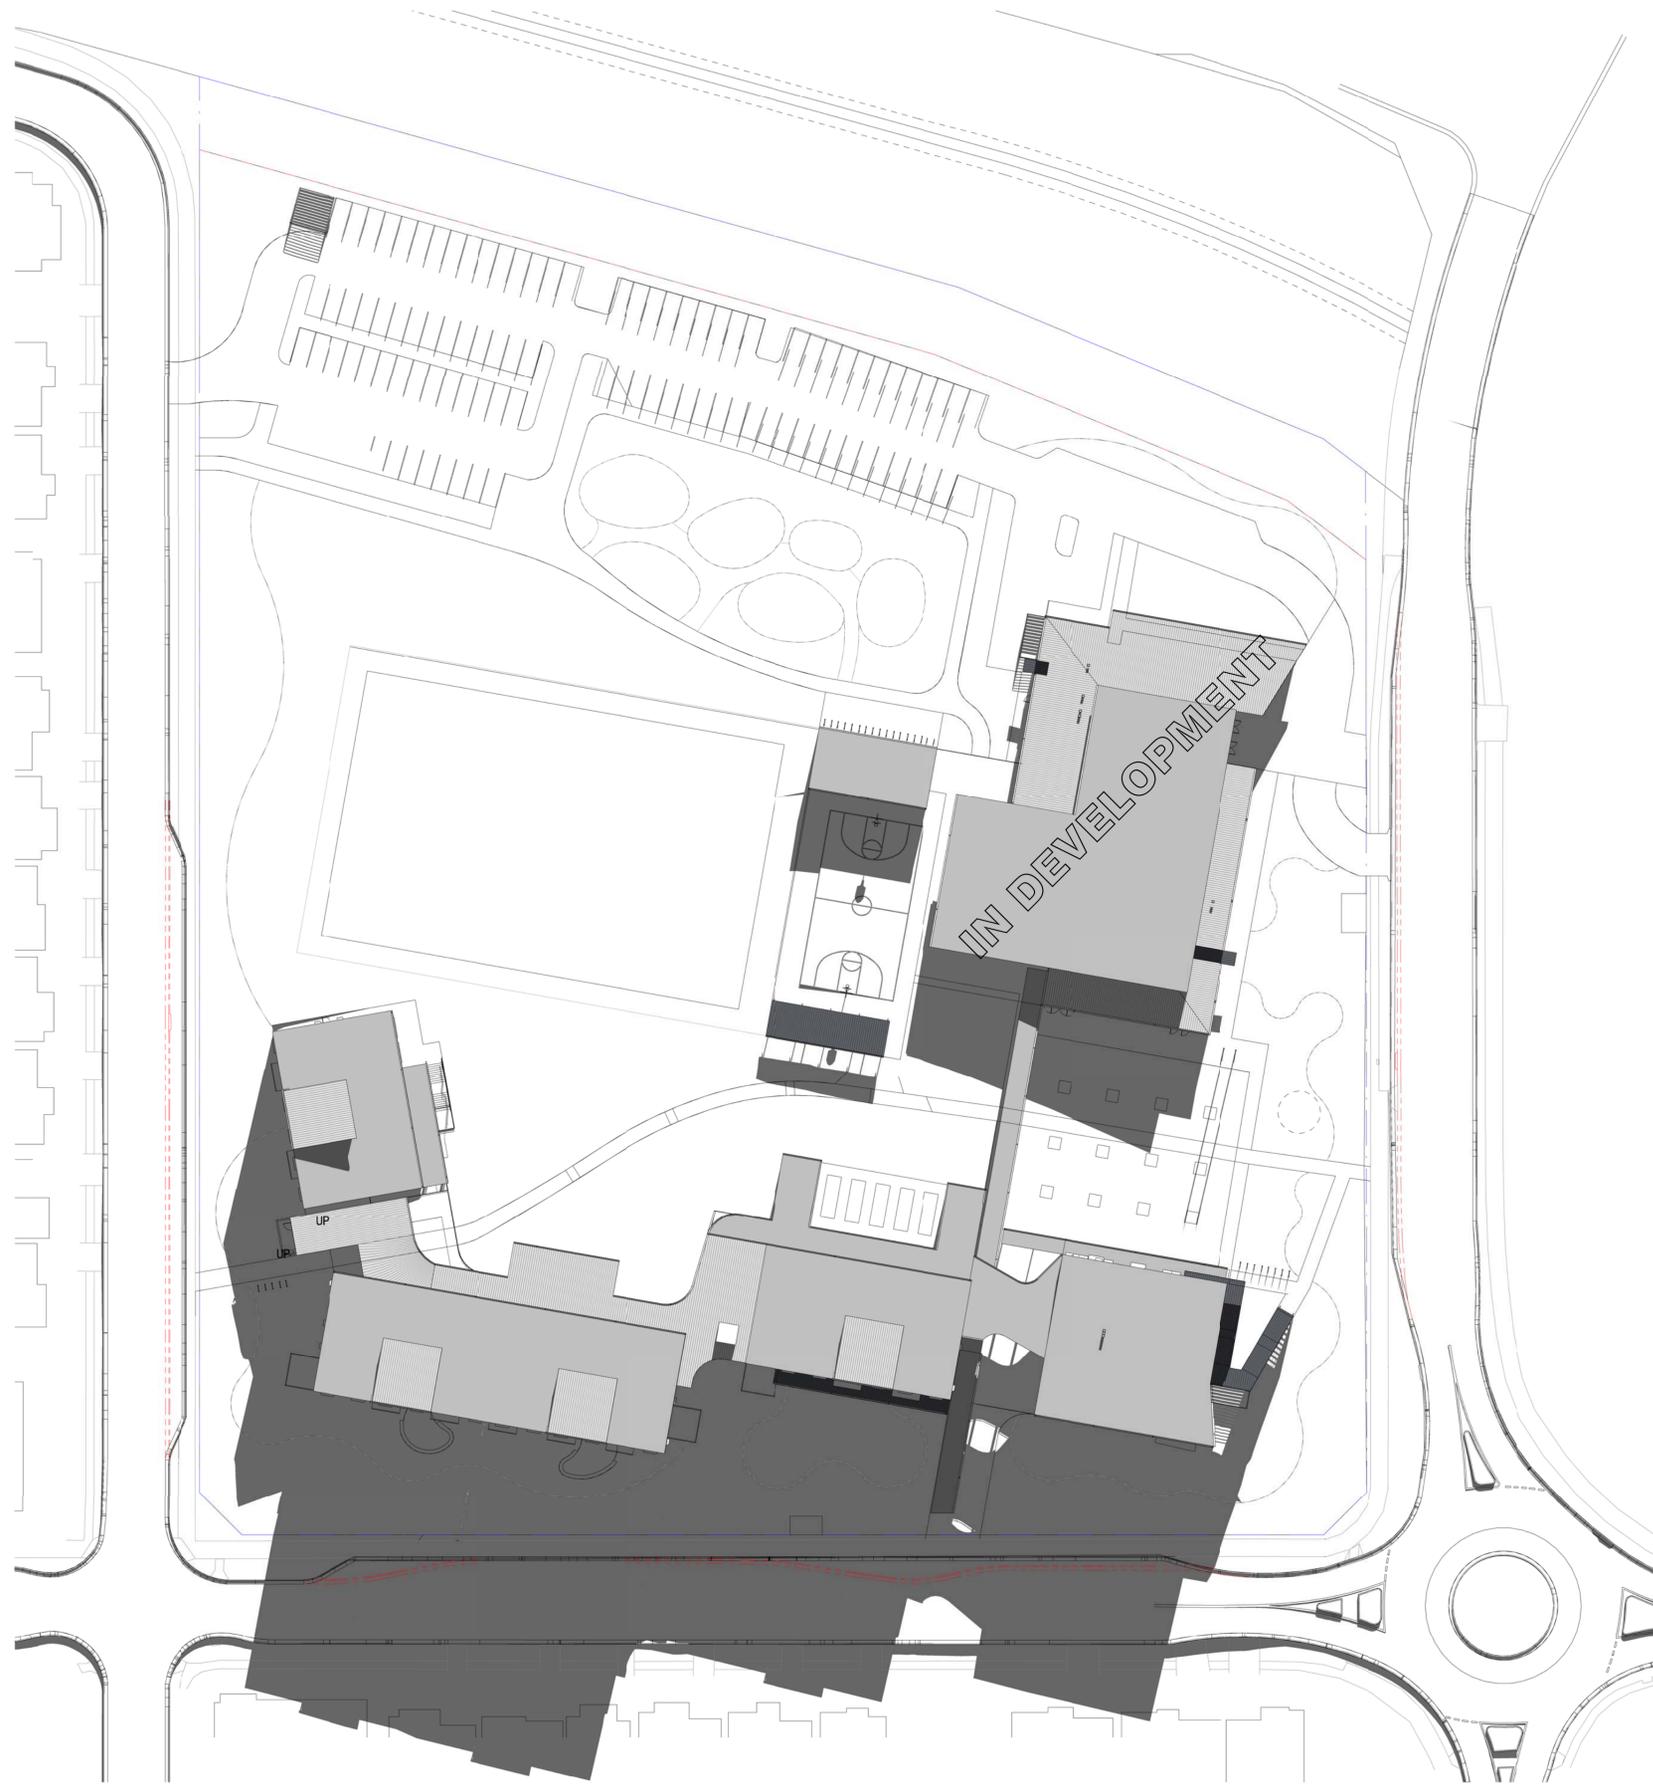

AMMENDMENTS			
REV	BY	DATE	DESCRIPTION
VL		13.08.19	PRELIMINARY ISSUE FOR REVIEW
A	VL	02.09.19	ISSUE FOR SSDA TOA

LEGEND

 
HANSENYUNCKEN
 NSW GOVERNMENT Education

STRUC. CIVIL
 NORTHROP ENGINEERS
 (02) 9241 4188
 MECH. ELEC
 STEINER WARMING
 (02) 9967 2200
 HYD
 WOOLACOTTS
 (02) 8241 9900
 FIRE
 MCD FIRE ENGINEERING
 (04) 2392 2745

PERUMAL PEDAVOLI ARCHITECTS
 T: 02 9291 0000
 WEB: www.pp-a.com.au
 Nominated Architect
 Vice President NSW reg No. 5045

**PERUMAL
 PEDAVOLI**
 ARCHITECTS


**EAST LEPPINGTON PS
 NEW HIGH QUALITY CLASSROOMS**
 DRAWING NAME
**SHADOW EXISTING & PROPOSED -
 21 JUNE 3 PM**




PROJECT NORTH						
0	5000	10000	15000	20000	25000	30000
SCALE 1:500 @ A1						
DRAWN	CHECKED	VERIFIED	DATE			
Author	Checker	Approver	2 September 2019			
DRAWING NUMBER						
NHQ2 - LP - AR - SSDA - 00_303						
PROJECT CODE SCH. REF. DISC. TYPE SERIES#						REVISION
						A

DRAFT ISSUE

2/09/2019 6:44:48 PM

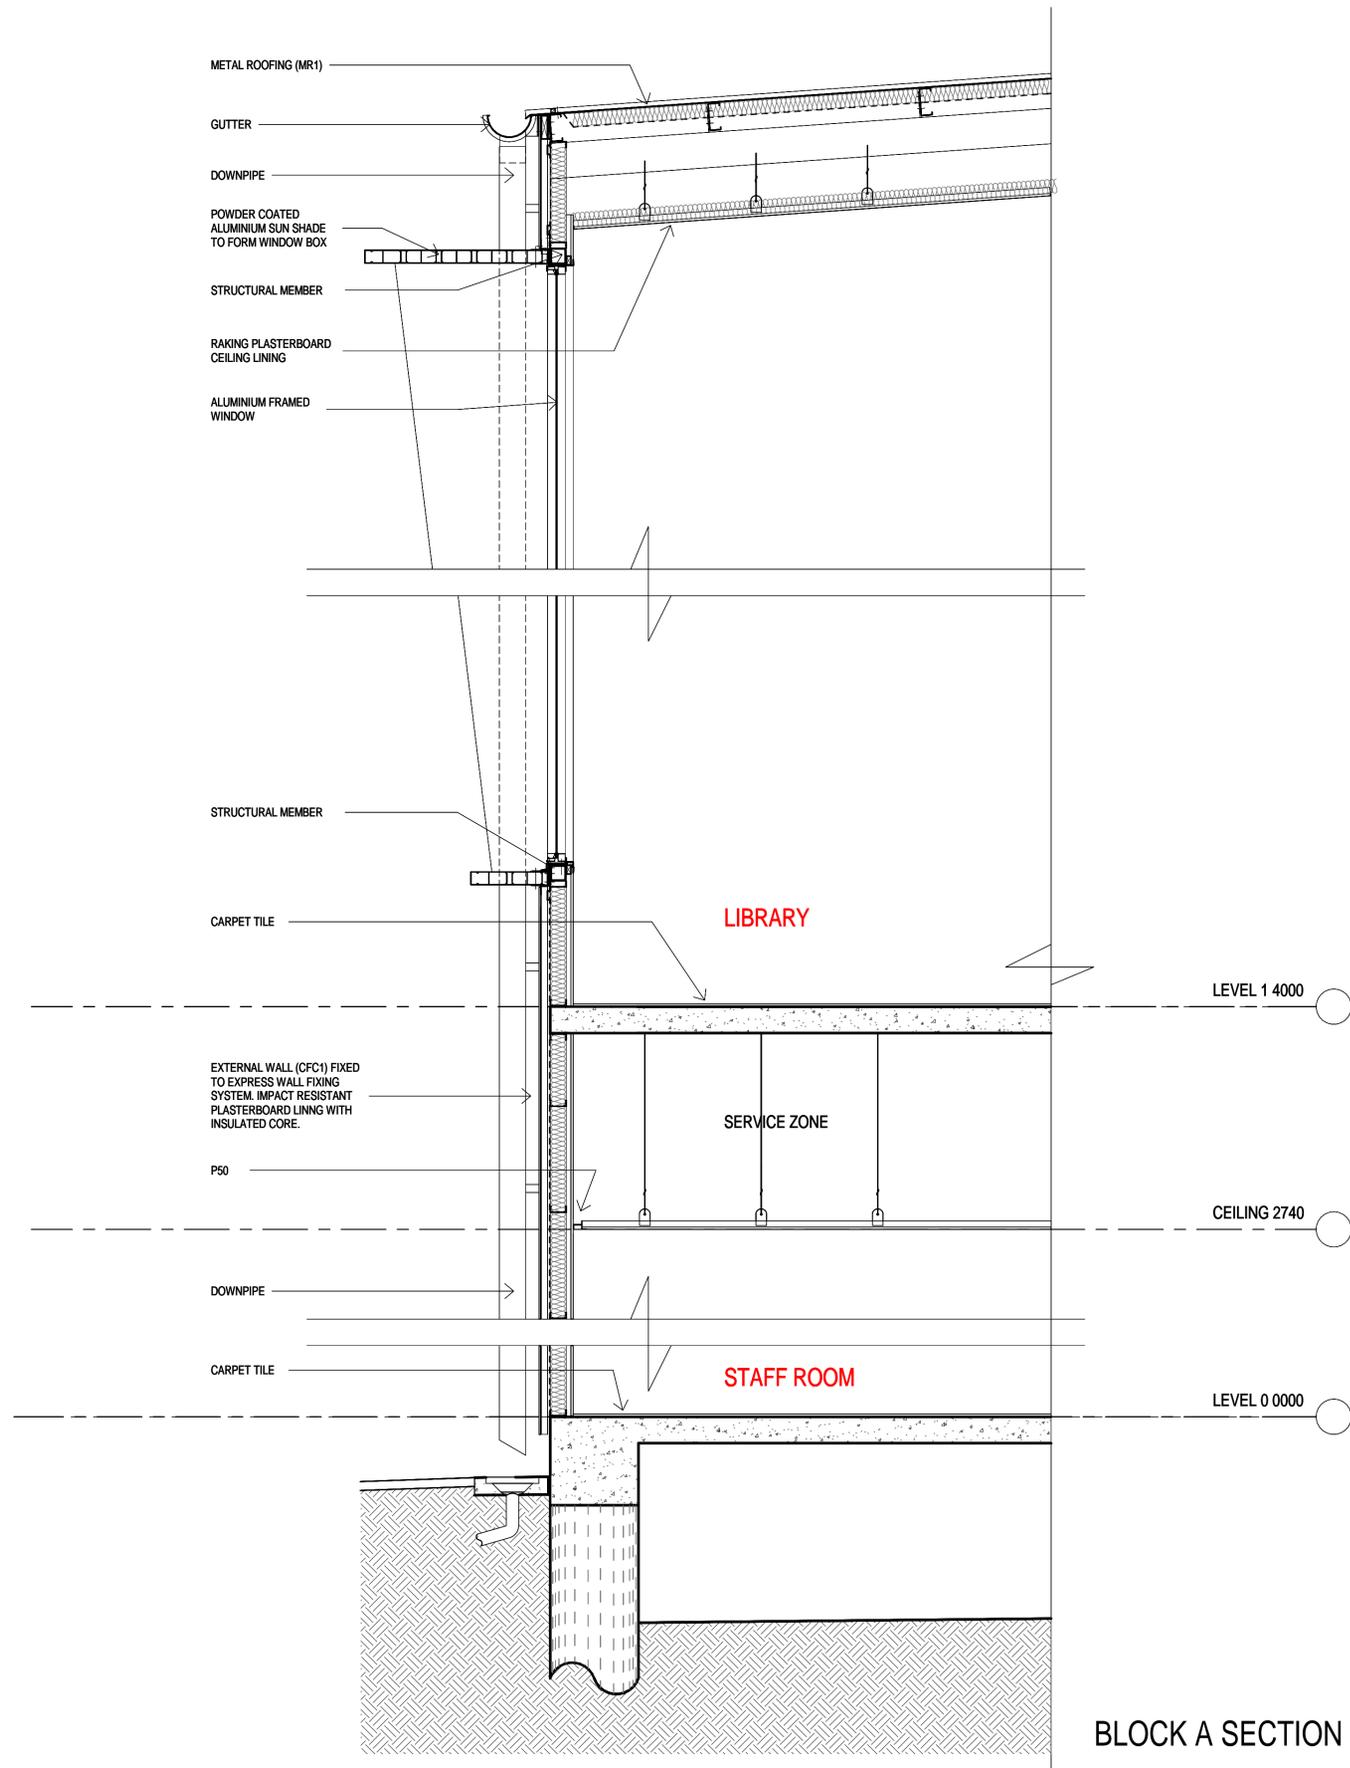

BLOCK A SECTION

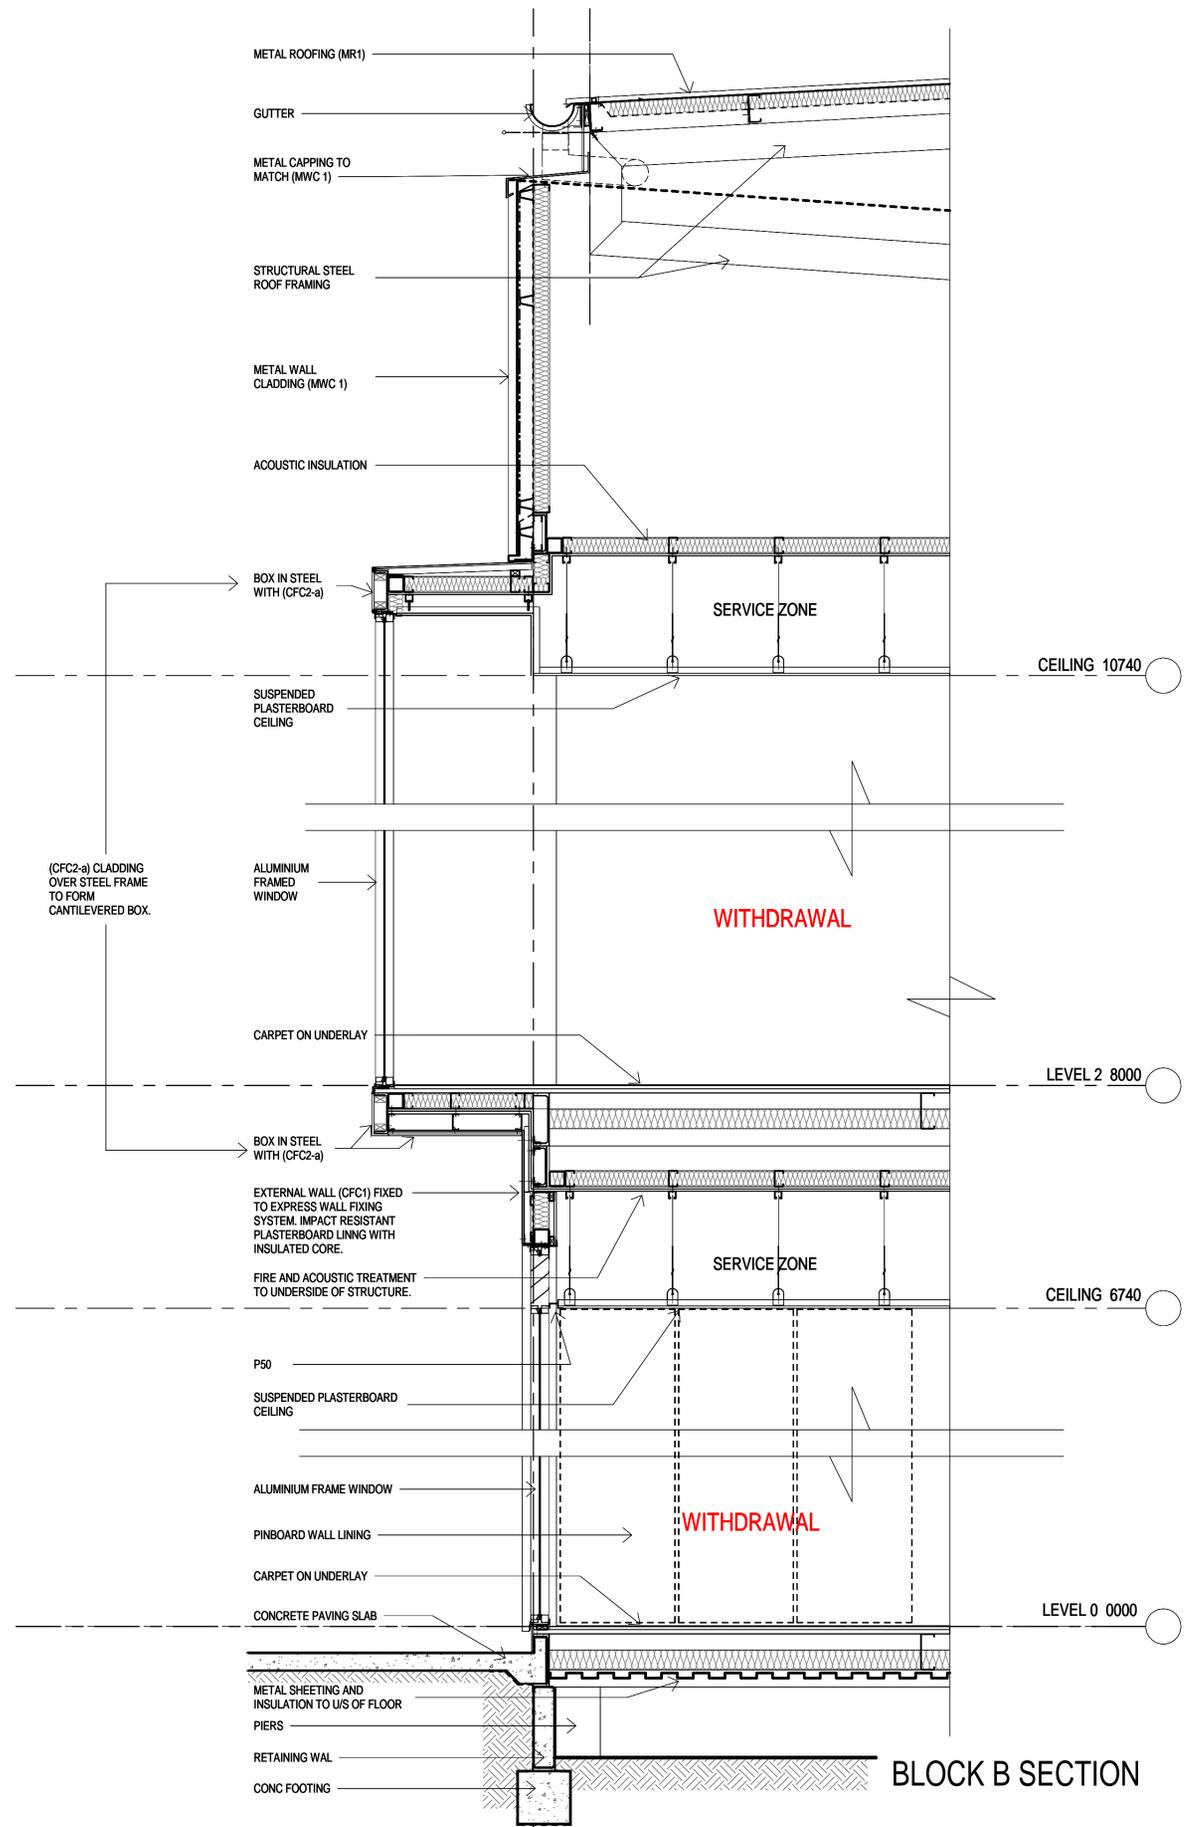

BLOCK B SECTION

REV	BY	DATE	DESCRIPTION
VL	13.08.19		PRELIMINARY ISSUE FOR REVIEW
A	02.09.19		ISSUE FOR SSDA TOA

LEGEND

HANSEN YUNCKEN
 STRUC. CIVIL
 NORTHROP ENGINEERS
 (02) 9241 4188
 MECH. ELEC
 STEINER WARMING
 (02) 9967 2200
 HYD
 WOOLACOTTS
 (02) 8241 9900
 FIRE
 MCD FIRE ENGINEERING
 (04) 2392 2745

NSW
 GOVERNMENT
Education

PERUMAL PEDAVOLI ARCHITECTS
 T: 02 9291 0000
 WEB: www.pp-a.com.au
 Nominated Architect
 Since Pedavoli NSW reg No. 5045

PERUMAL PEDAVOLI ARCHITECTS

PERUMAL PEDAVOLI ARCHITECTS

EAST LEPPINGTON PS
 NEW HIGH QUALITY CLASSROOMS

DRAWING NAME
 WALL SECTIONS - SHEET 01

PROJECT NORTH

0 200 400 600 800 1000 2000
 SCALE 1:20 @ A1

DRAWN	CHECKED	VERIFIED	DATE
Author	Checker	Approver	2 September 2019

DRAWING NUMBER
 PROJECT CODE SCH. REF. DISC. TYPE SERIES# REVISION

NHQ2 - LP - AR - SSDA - 00_801

A

DRAFT ISSUE