

1:40:01 AM														Access Consultant Cheung Access Code Compliance B M + G Pty Ltd
6/2016 1														Comms/Security Engineer JHA Consulting Engineers
6/2	G	FOR INFORMATION	MS	13.09.2016	0	1m							10m A1	Electrical Engineer
9/1		DESCRIPTION OF CHANGE	CHKD	DATE	Ĭ	T.	I	I	1	I	I	1		JHA Consulting Engineers

 Electrical Engineer
 Landscape Architects

 JHA Consulting Engineers
 OCULUS Pty Ltd

 ESD Consultant
 Mechanical Engineer

 JHA Consulting Engineers
 JHA Consulting Engineers

 Façade Engineer
 Plumbing Engineer

 Surface Design Consult. Pty Ltd
 JHA Consulting Engineers
 Fire Engineer Defire Pty Limited

Structural Engineer Northrop Engineers Pty Ltd

	5			7		8
			BUILDING			
			SERVICES PLANT ZONE 1			
EAT WET SEARCH ARY LAB 4.007				GOODS LIF LOBBY D5.132		CI LLABORATION 04.059
EAT WET FARCH ARY LAB 4.005			WET COLLABORATION ZONE 04-998	GOODS LIFT LOBBY 05.069	COMMON	COMMON KITCHEN 04.058
			COLLABORATION ZONE	GOODS LIFT LOBBY 04.095	OFFICE 04.062	MEETING RM 04.110 CILABORATION 04.093
		96-SEAT WET TEACHING LAB				
		144 SEAT WET TEACHING LAB 03.005				
		144 SEAT WET TEACHING LAB				
DRRIDOR 05.074						LOADING DOCK 02.006

CLIENT






ARCHITECTS



PROJECT LEES1 BUILDING (F07) THE UNIVERSITY OF SYDNEY CITY ROAD, CAMPERDOWN


Level 1, 110 Walker Street, North Sydney NSW 2060, Australia +61 2 9956 2666 | hdrricedaubney.com | hdrinc.com PROJECT NUMBER 271821_15H

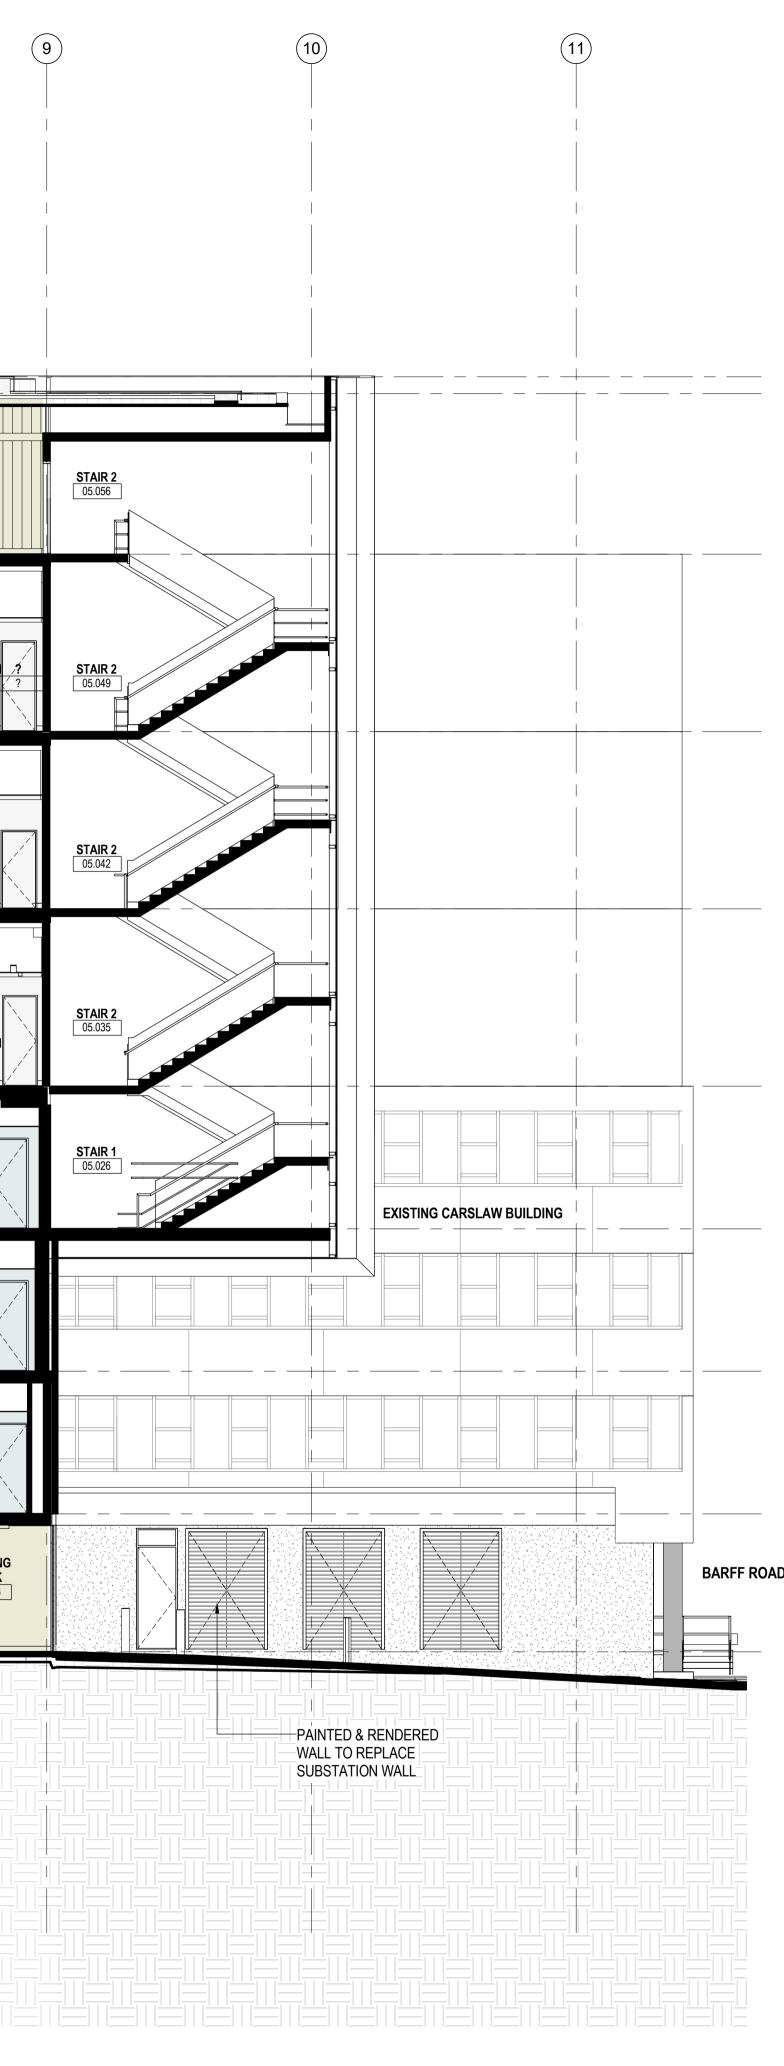

DRAWING TITLE	
SECTION	1

SCALE	CHECKED	DATE
1 : 100 @ A1	MS	13.09.2016
T. 100 @ AT	MS	13.09.2010
CONTRACT NUMBER	DRAWING NUMBER	ISSUE
TBC	HDR-AR-DWG-DA10	G
ALL INFORMATION ILLUSTRATED ON T	OF THE RICE DAUBNEY GROUP (NSW) PTY. LTD. THIS DOCUMENT IS TO BE CHECKED AND VERIFIED ON SITE FFER TO ARCHITECT PRIOR TO COMMENCEMENT OF THE V	-

DO NOT SCALE DRAWINGS MANUALLY OR ELECTRONICALLY. C:\rvt\2016\15H LEES 1_BASE BUILDING_sameh.hosny@hdrinc.com.rvt

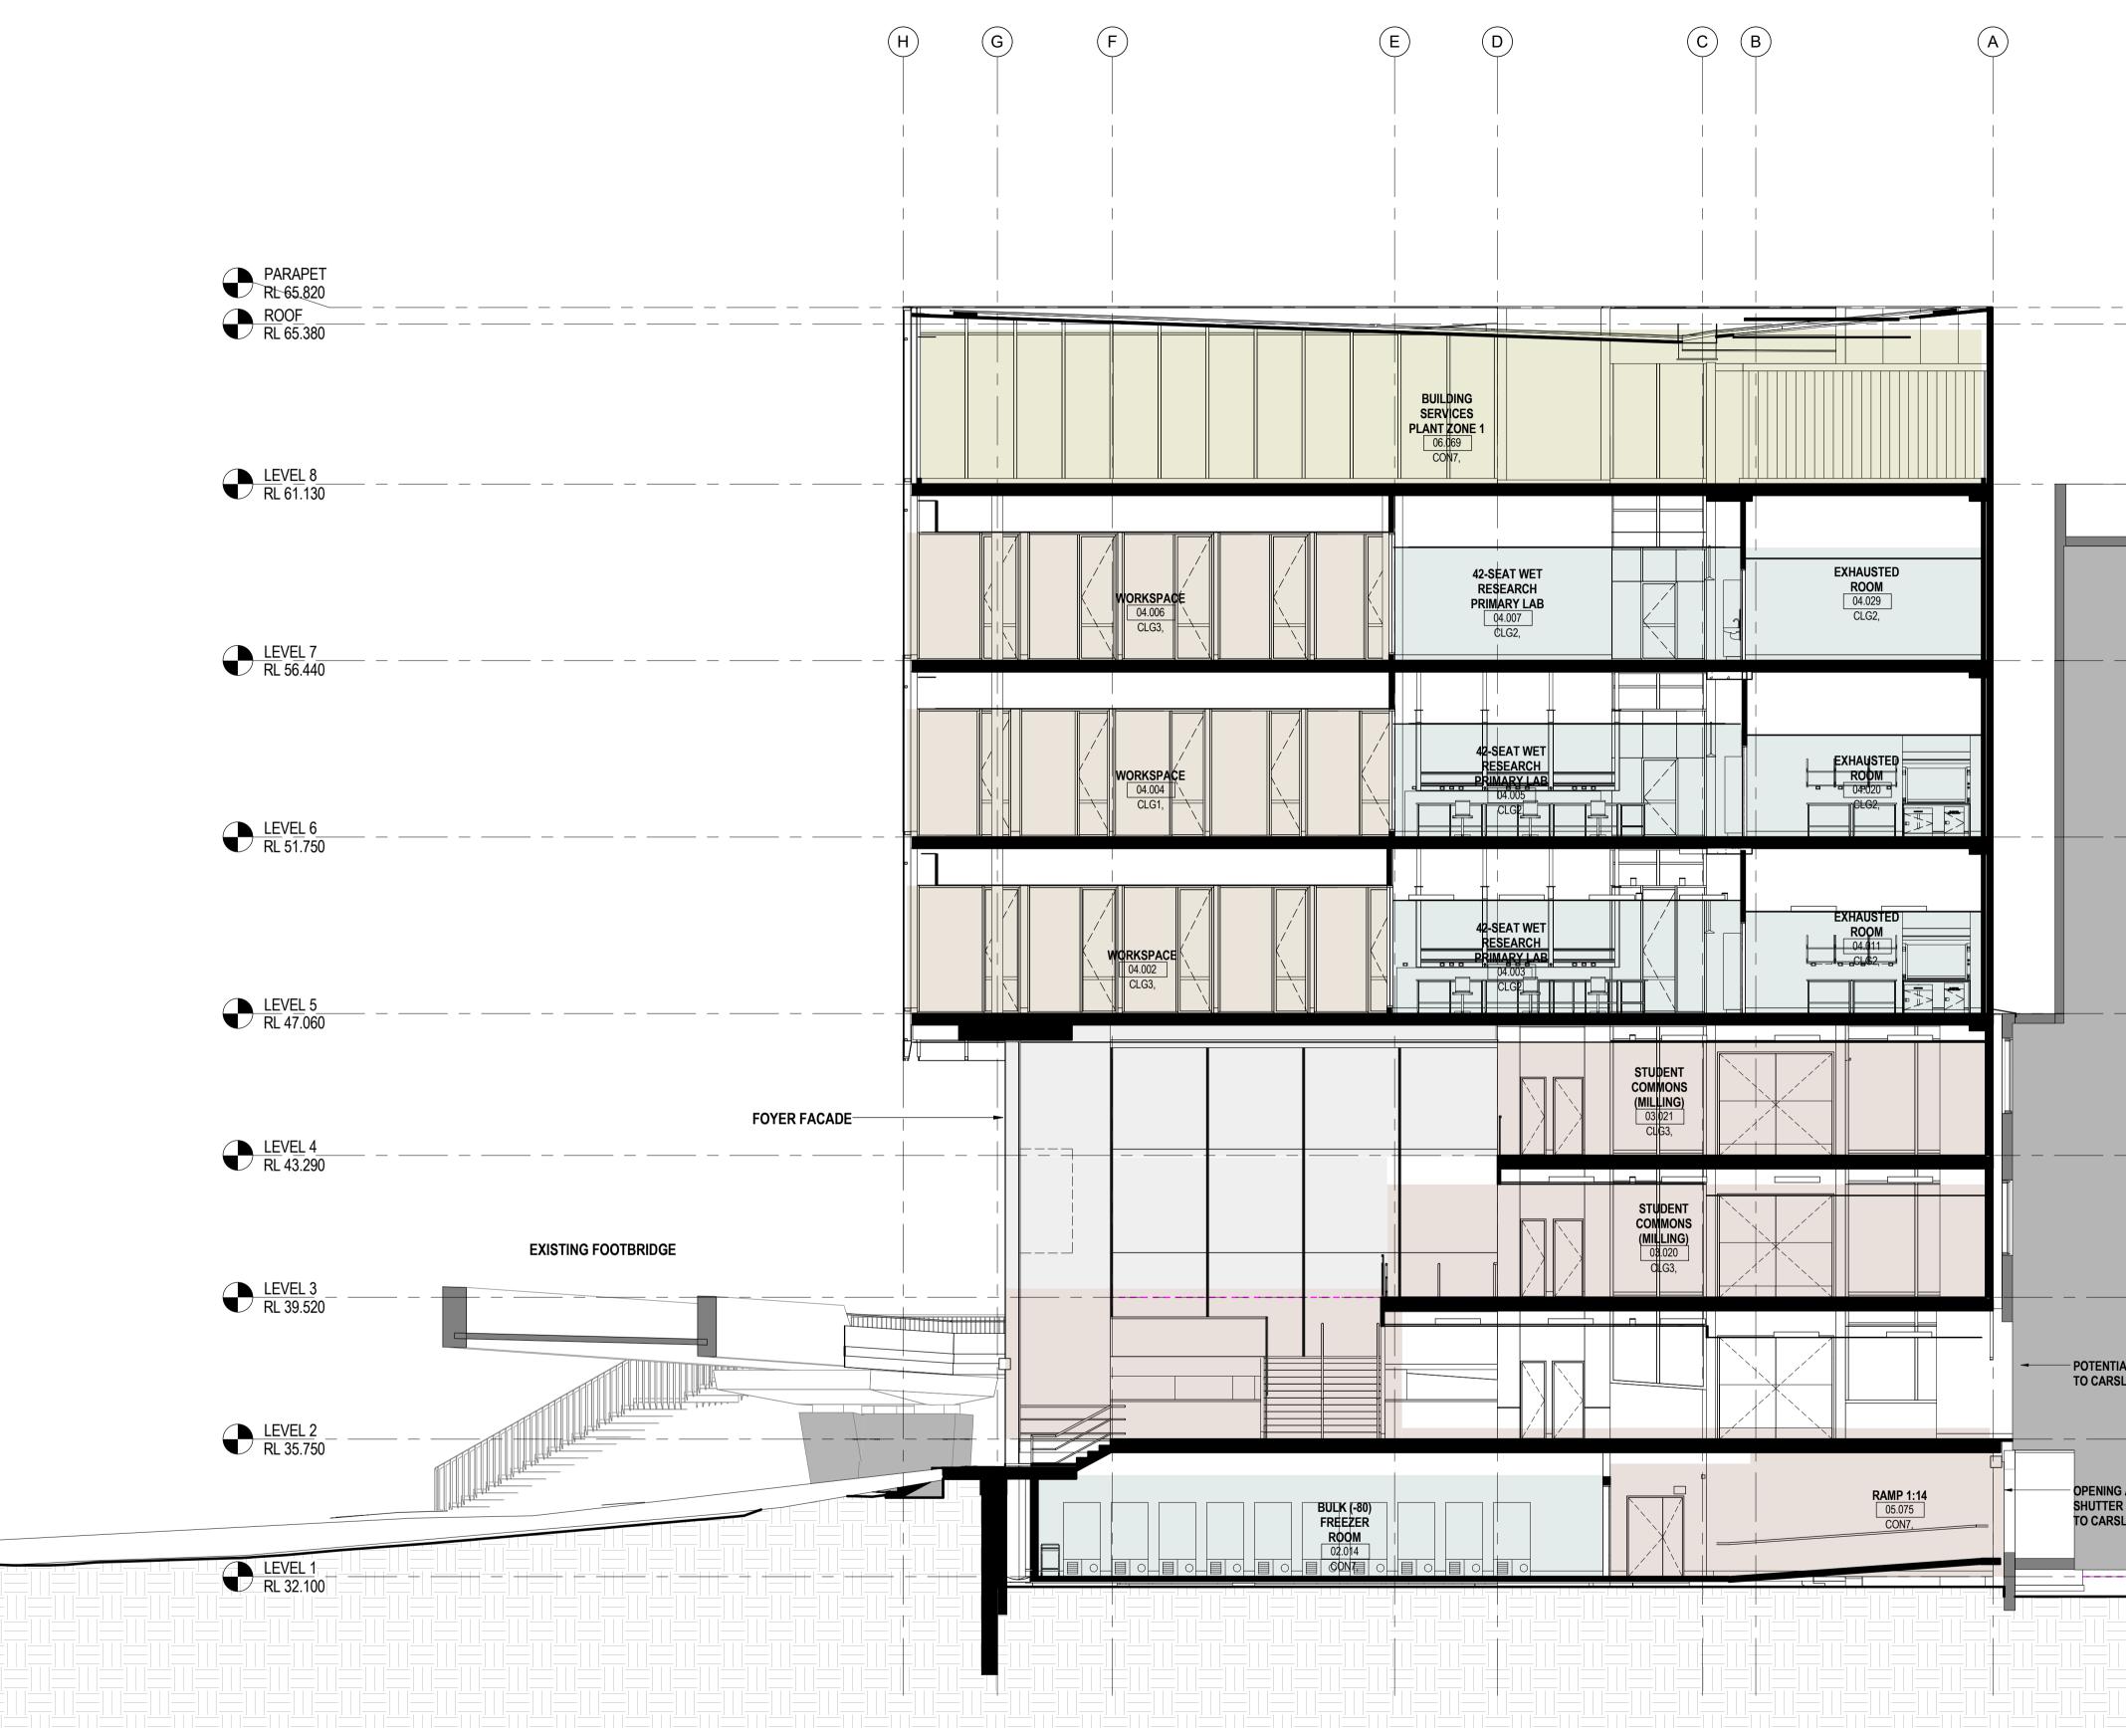

											CONSULTANT		
¥.											Access Consultant Cheung Access	ESD Consultant JHA Consulting Engineers	Mechanical Engineer JHA Consulting Engineers
11:40:06 AM											Code Compliance B M + G Pty Ltd	Façade Engineer Surface Design Consult. Pty Ltd	Plumbing Engineer JHA Consulting Engineers
9/16/2016 11: Aa D											Comms/Security Engineer JHA Consulting Engineers	Fire Engineer Defire Pty Limited	Structural Engineer Northrop Engineers Pty Ltd
G [20	FOR INFORMATION	MS	13.09.2016	0	1m					10m A1	Electrical Engineer	Landscape Architects	
S REV	DESCRIPTION OF CHANGE	CHKD	DATE	ĭ			I		I		JHA Consulting Engineers	OCULUS Pty Ltd	



HD7 Level 1, 110 Walker Street, North Sydney NSW 2060, Australia +61 2 9956 2666 | hdrricedaubney.com | hdrinc.com


ARCHITECTS



PROJECT LEES1 BUILDING (F07) THE UNIVERSITY OF SYDNEY CITY ROAD, CAMPERDOWN

·	
EXISTING CARSLAW BUILDING	
AL FUTURE CONNECTION LAW BUILDING	
AND FIRE CONNECTION AW BUILDING	
	— — — — []

RAWING TITLE	SCALE	CHECKED	DATE	
ECTION 2	1 : 100 @ A1	MS	13.09.2016	
	CONTRACT NUMBER	DRAWING NUMBER	ISSUE	
	TBC	HDR-AR-DWG-DA11	G	
	ALL INFORMATION ILLUSTRATED	SHT OF THE RICE DAUBNEY GROUP (NSW) PTY. LTD. ON THIS DOCUMENT IS TO BE CHECKED AND VERIFIED ON SIT S REFER TO ARCHITECT PRIOR TO COMMENCEMENT OF THE ' IALLY OR ELECTRONICALLY.		

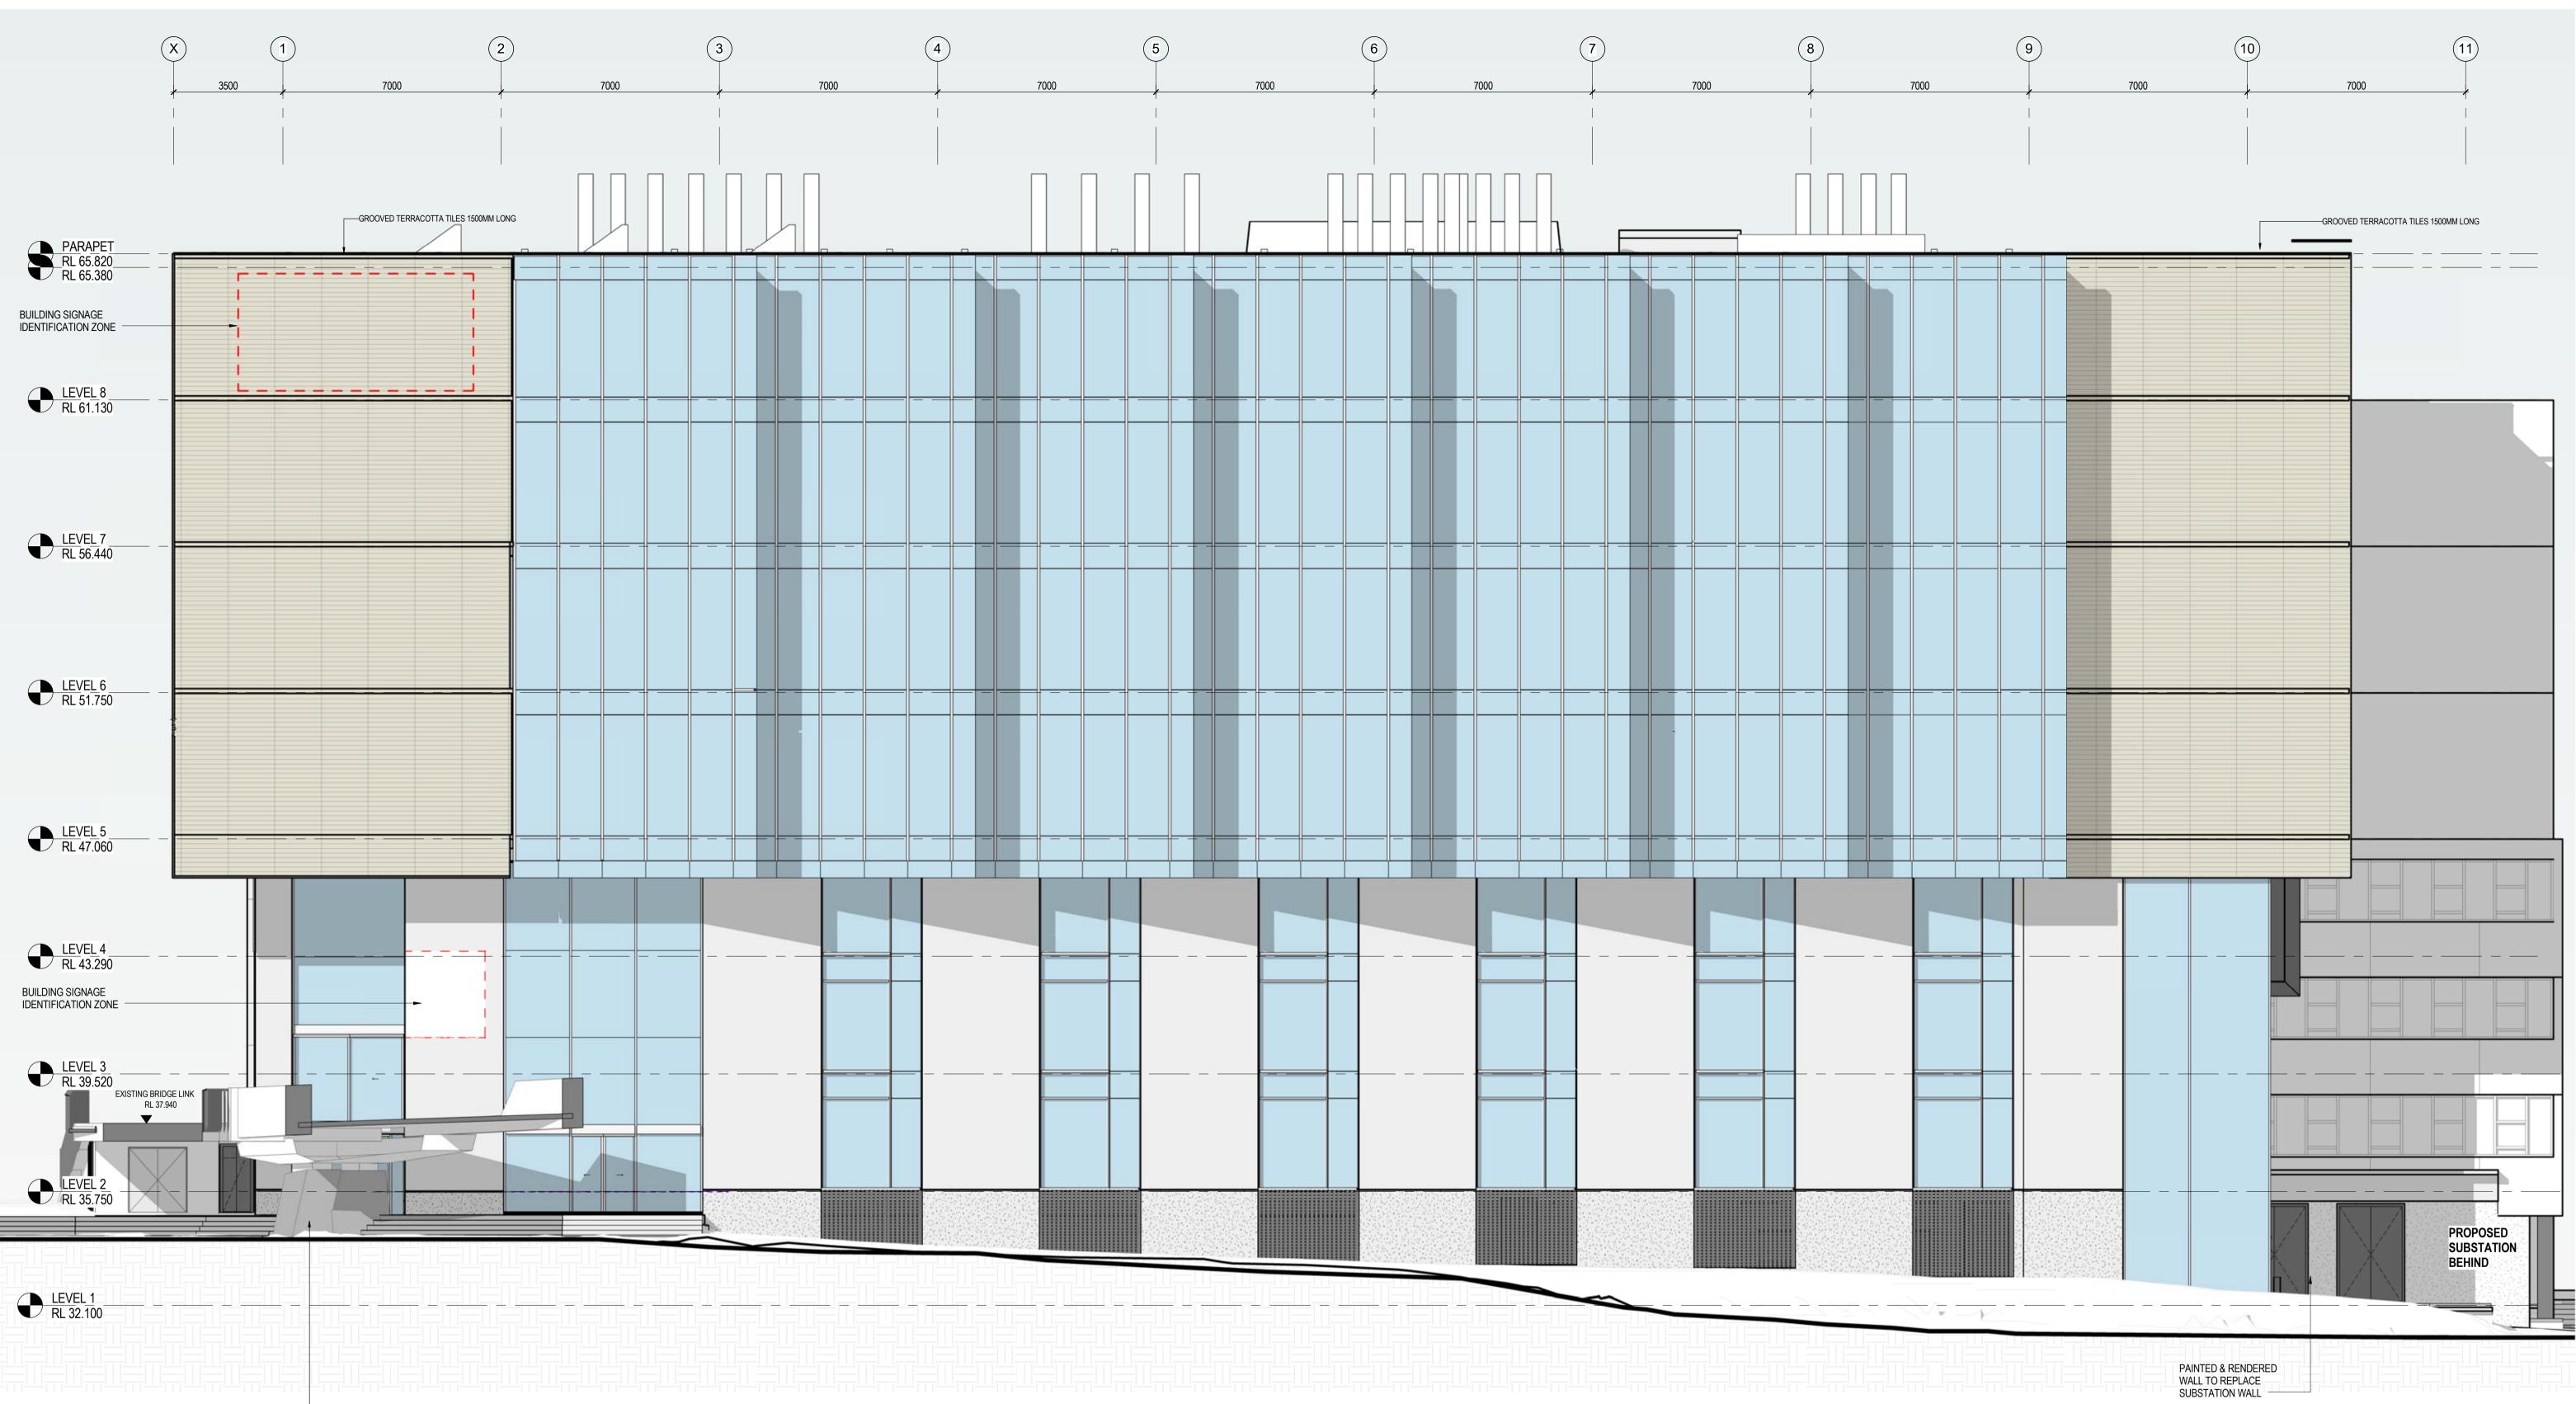

Γ														CONSULTANT		
MA														Access Consultant Cheung Access	ESD Consultant JHA Consulting Engineers	Mechanical Engineer JHA Consulting Engineers
11:54 /														Code Compliance B M + G Pty Ltd	Façade Engineer Surface Design Consult. Pty Ltd	Plumbing Engineer JHA Consulting Engineers
6/2016 11:4														Comms/Security Engineer JHA Consulting Engineers	Fire Engineer Defire Pty Limited	Structural Engineer Northrop Engineers Pty Ltd
6/2(3	FOR INFORMATION	MS	13.09.2016	0	1m							10m A1	Electrical Engineer	Landscape Architects	
9/1		DESCRIPTION OF CHANGE	CHKD	DATE	Ĭ	1	I	I		I	I	I		JHA Consulting Engineers	OCULUS Pty Ltd	

CLIENT



FS Level 1, 110 Walker Street, North Sydney NSW 2060, Australia +61 2 9956 2666 | hdrricedaubney.com | hdrinc.com

ARCHITECTS




PROJECT LEES1 BUILDING (F07) THE UNIVERSITY OF SYDNEY CITY ROAD, CAMPERDOWN

PROJECT NUMBER 271821_15H

	ALL INFORMATION ILLUSTRATED	IE COPYRIGHT OF THE RICE DAUBNEY GROUP (NSW) PTY. LTD. JSTRATED ON THIS DOCUMENT IS TO BE CHECKED AND VERIFIED ON SITE. REPANCIES REFER TO ARCHITECT PRIOR TO COMMENCEMENT OF THE WORK				
	TBC	HDR-AR-DWG-DA12	G			
	CONTRACT NUMBER	DRAWING NUMBER	ISSUE			
SOUTH ELEVATION	1 : 100 @ A1	MS	13.09.2016			
DRAWING TITLE	SCALE	CHECKED	DATE			

DO NOT SCALE DRAWINGS MANUALLY OR ELECTRONICALLY. C:\rvt\2016\15H LEES 1_BASE BUILDING_sameh.hosny@hdrinc.com.rvt

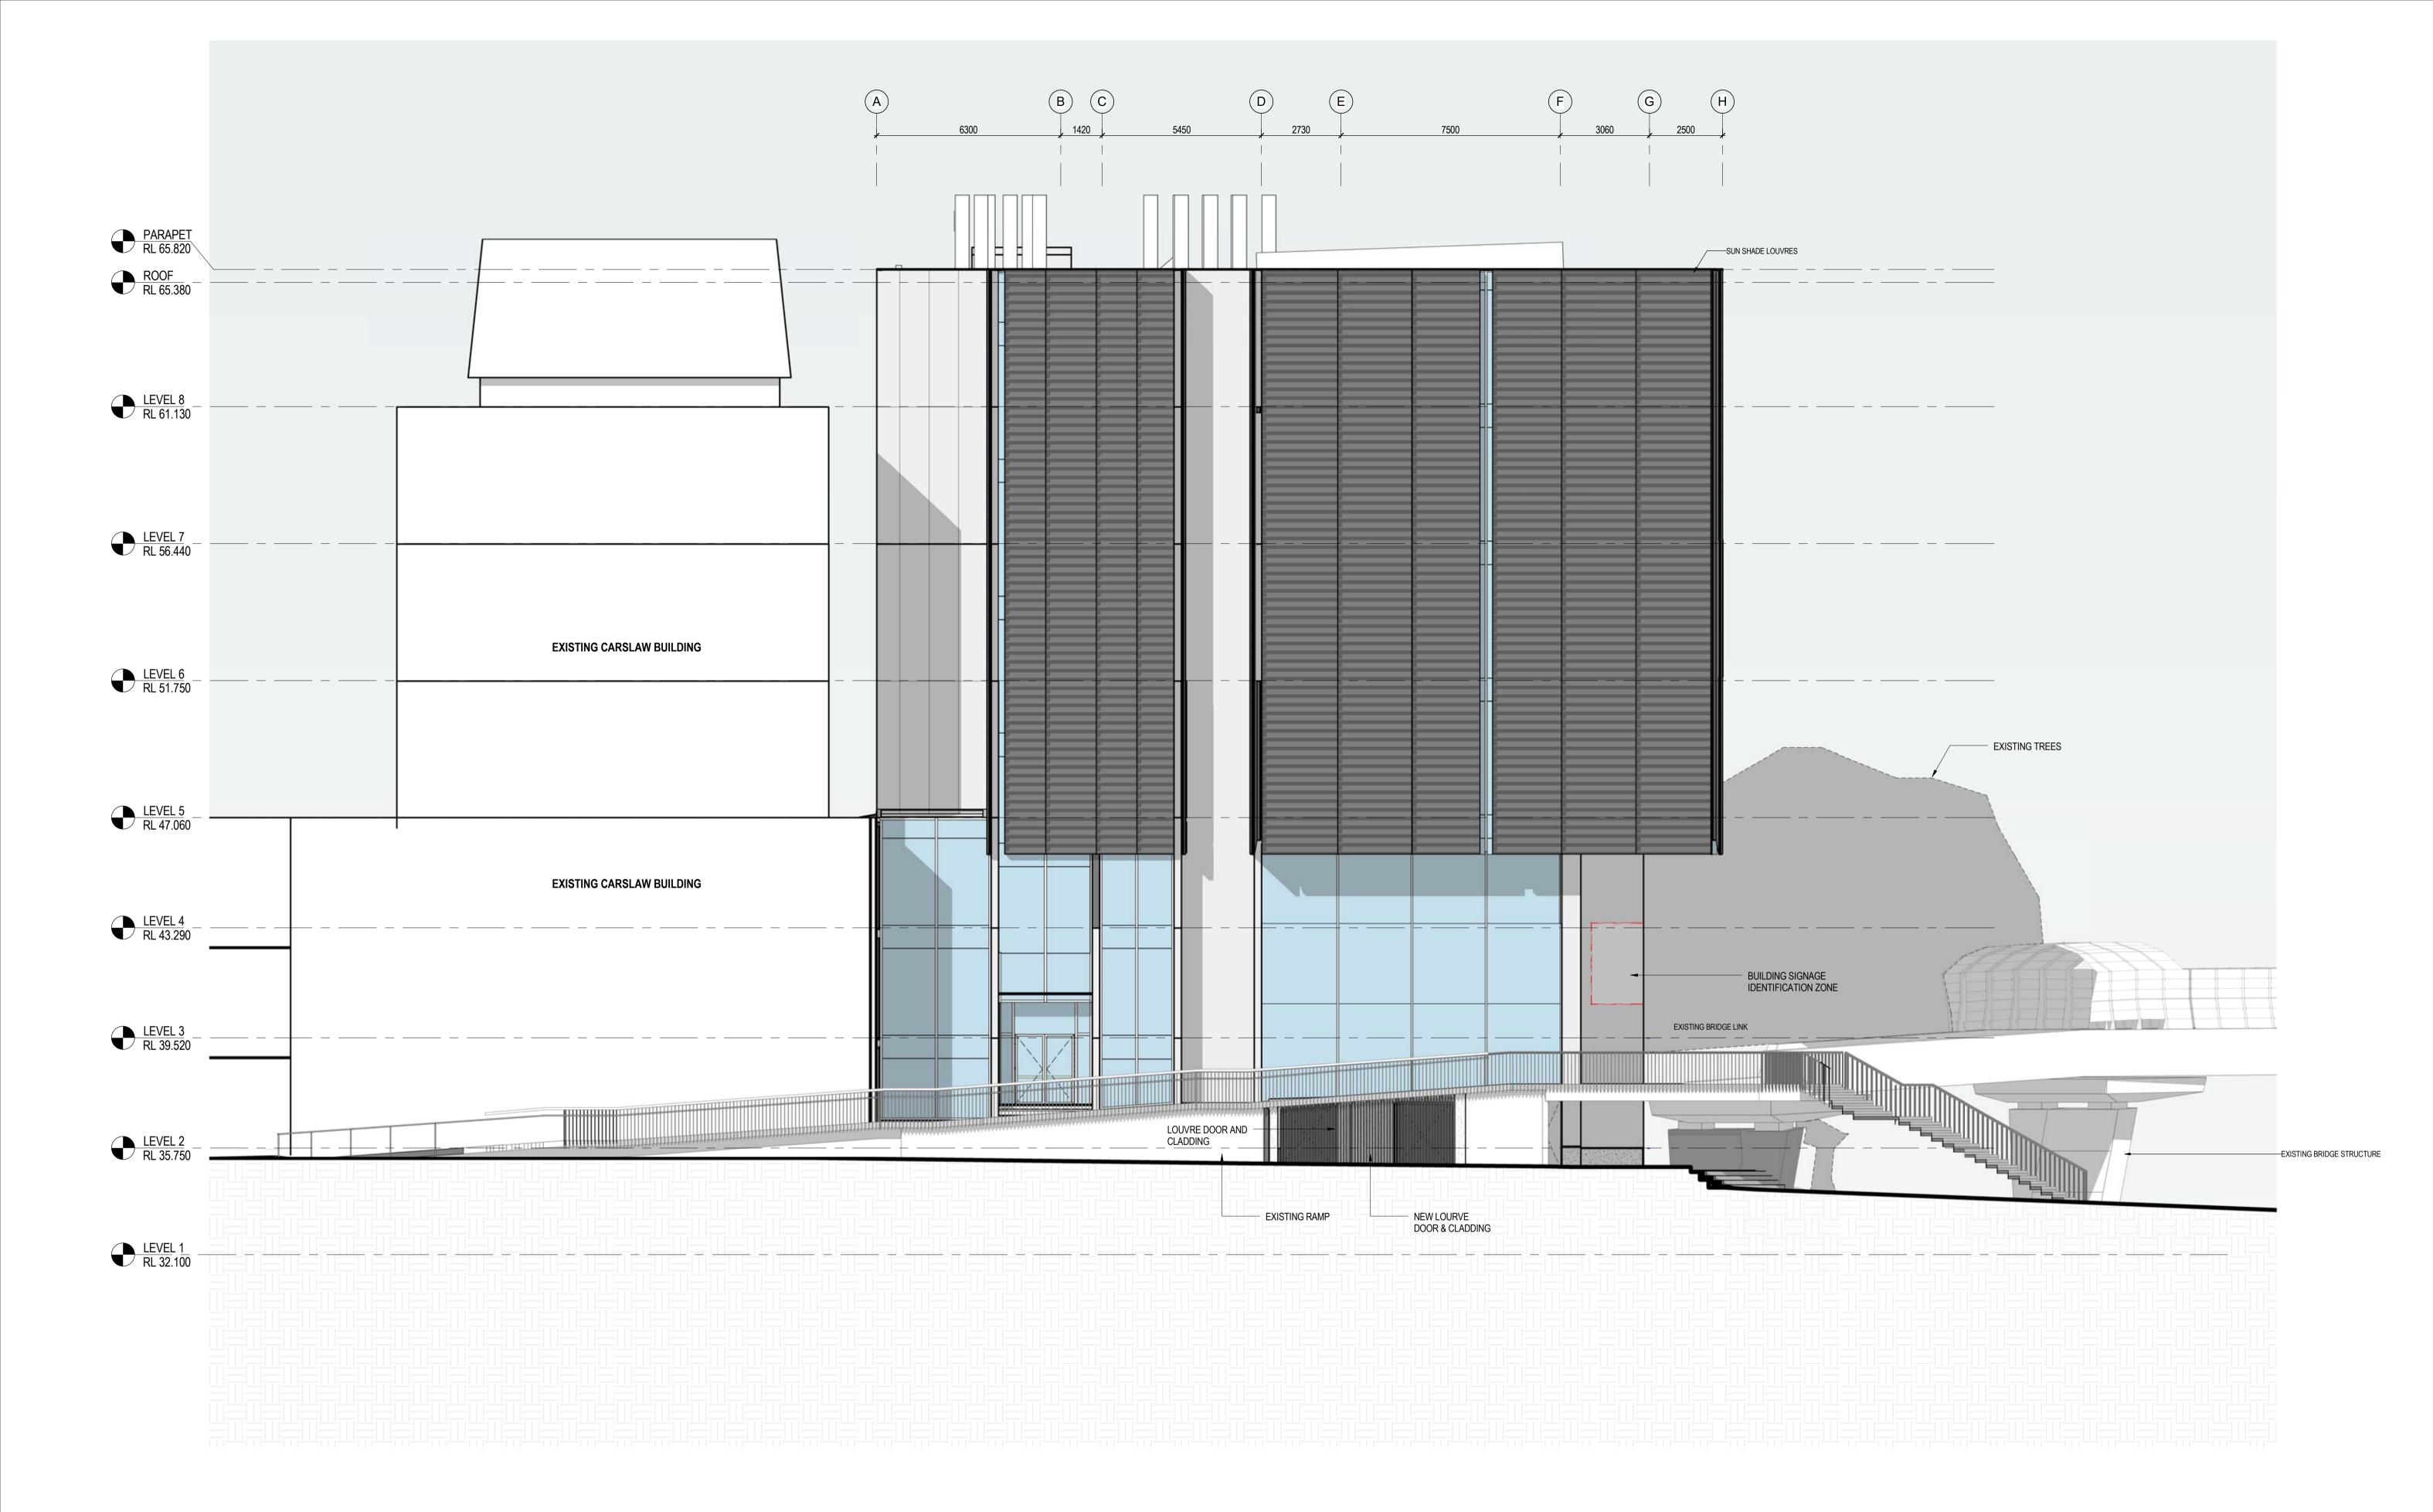

												CONSULTANT		
W												Access Consultant Cheung Access	ESD Consultant JHA Consulting Engineers	Mechanical Engineer JHA Consulting Engineers
9/16/2016 11:43:40 AM 												Code Compliance B M + G Pty Ltd	Façade Engineer Surface Design Consult. Pty Ltd	Plumbing Engineer JHA Consulting Engineers
016 11:												Comms/Security Engineer JHA Consulting Engineers	Fire Engineer Defire Pty Limited	Structural Engineer Northrop Engineers Pty Ltd
9/2(FOR INFORMATION	MS	13.09.2016	0	1m					10m A1	Electrical Engineer	Landscape Architects	
S REV	V	DESCRIPTION OF CHANGE	CHKD	DATE	ĭ [T	I				- · · ·	JHA Consulting Engineers	OCULUS Pty Ltd	






ARCHITECTS



PROJECT LEES1 BUILDING (F07) THE UNIVERSITY OF SYDNEY CITY ROAD, CAMPERDOWN

	ALL INFORMATION ILLUSTRATED IN THE EVENT OF DISCREPANCIE	THIS DOCUMENT IS THE COPYRIGHT OF THE RICE DAUBNEY GROUP (NSW) PTY. LTD. ALL INFORMATION ILLUSTRATED ON THIS DOCUMENT IS TO BE CHECKED AND VERIFIED ON SITE. IN THE EVENT OF DISCREPANCIES REFER TO ARCHITECT PRIOR TO COMMENCEMENT OF THE WORK. DO NOT SCALE DRAWINGS MANUALLY OR ELECTRONICALLY.							
	TBC	HDR-AR-DWG-DA13	G						
	CONTRACT NUMBER	DRAWING NUMBER	ISSUE						
WEST ELEVATION	1 : 100 @ A1	MS	13.09.2016						
DRAWING TITLE	SCALE	CHECKED	DATE						

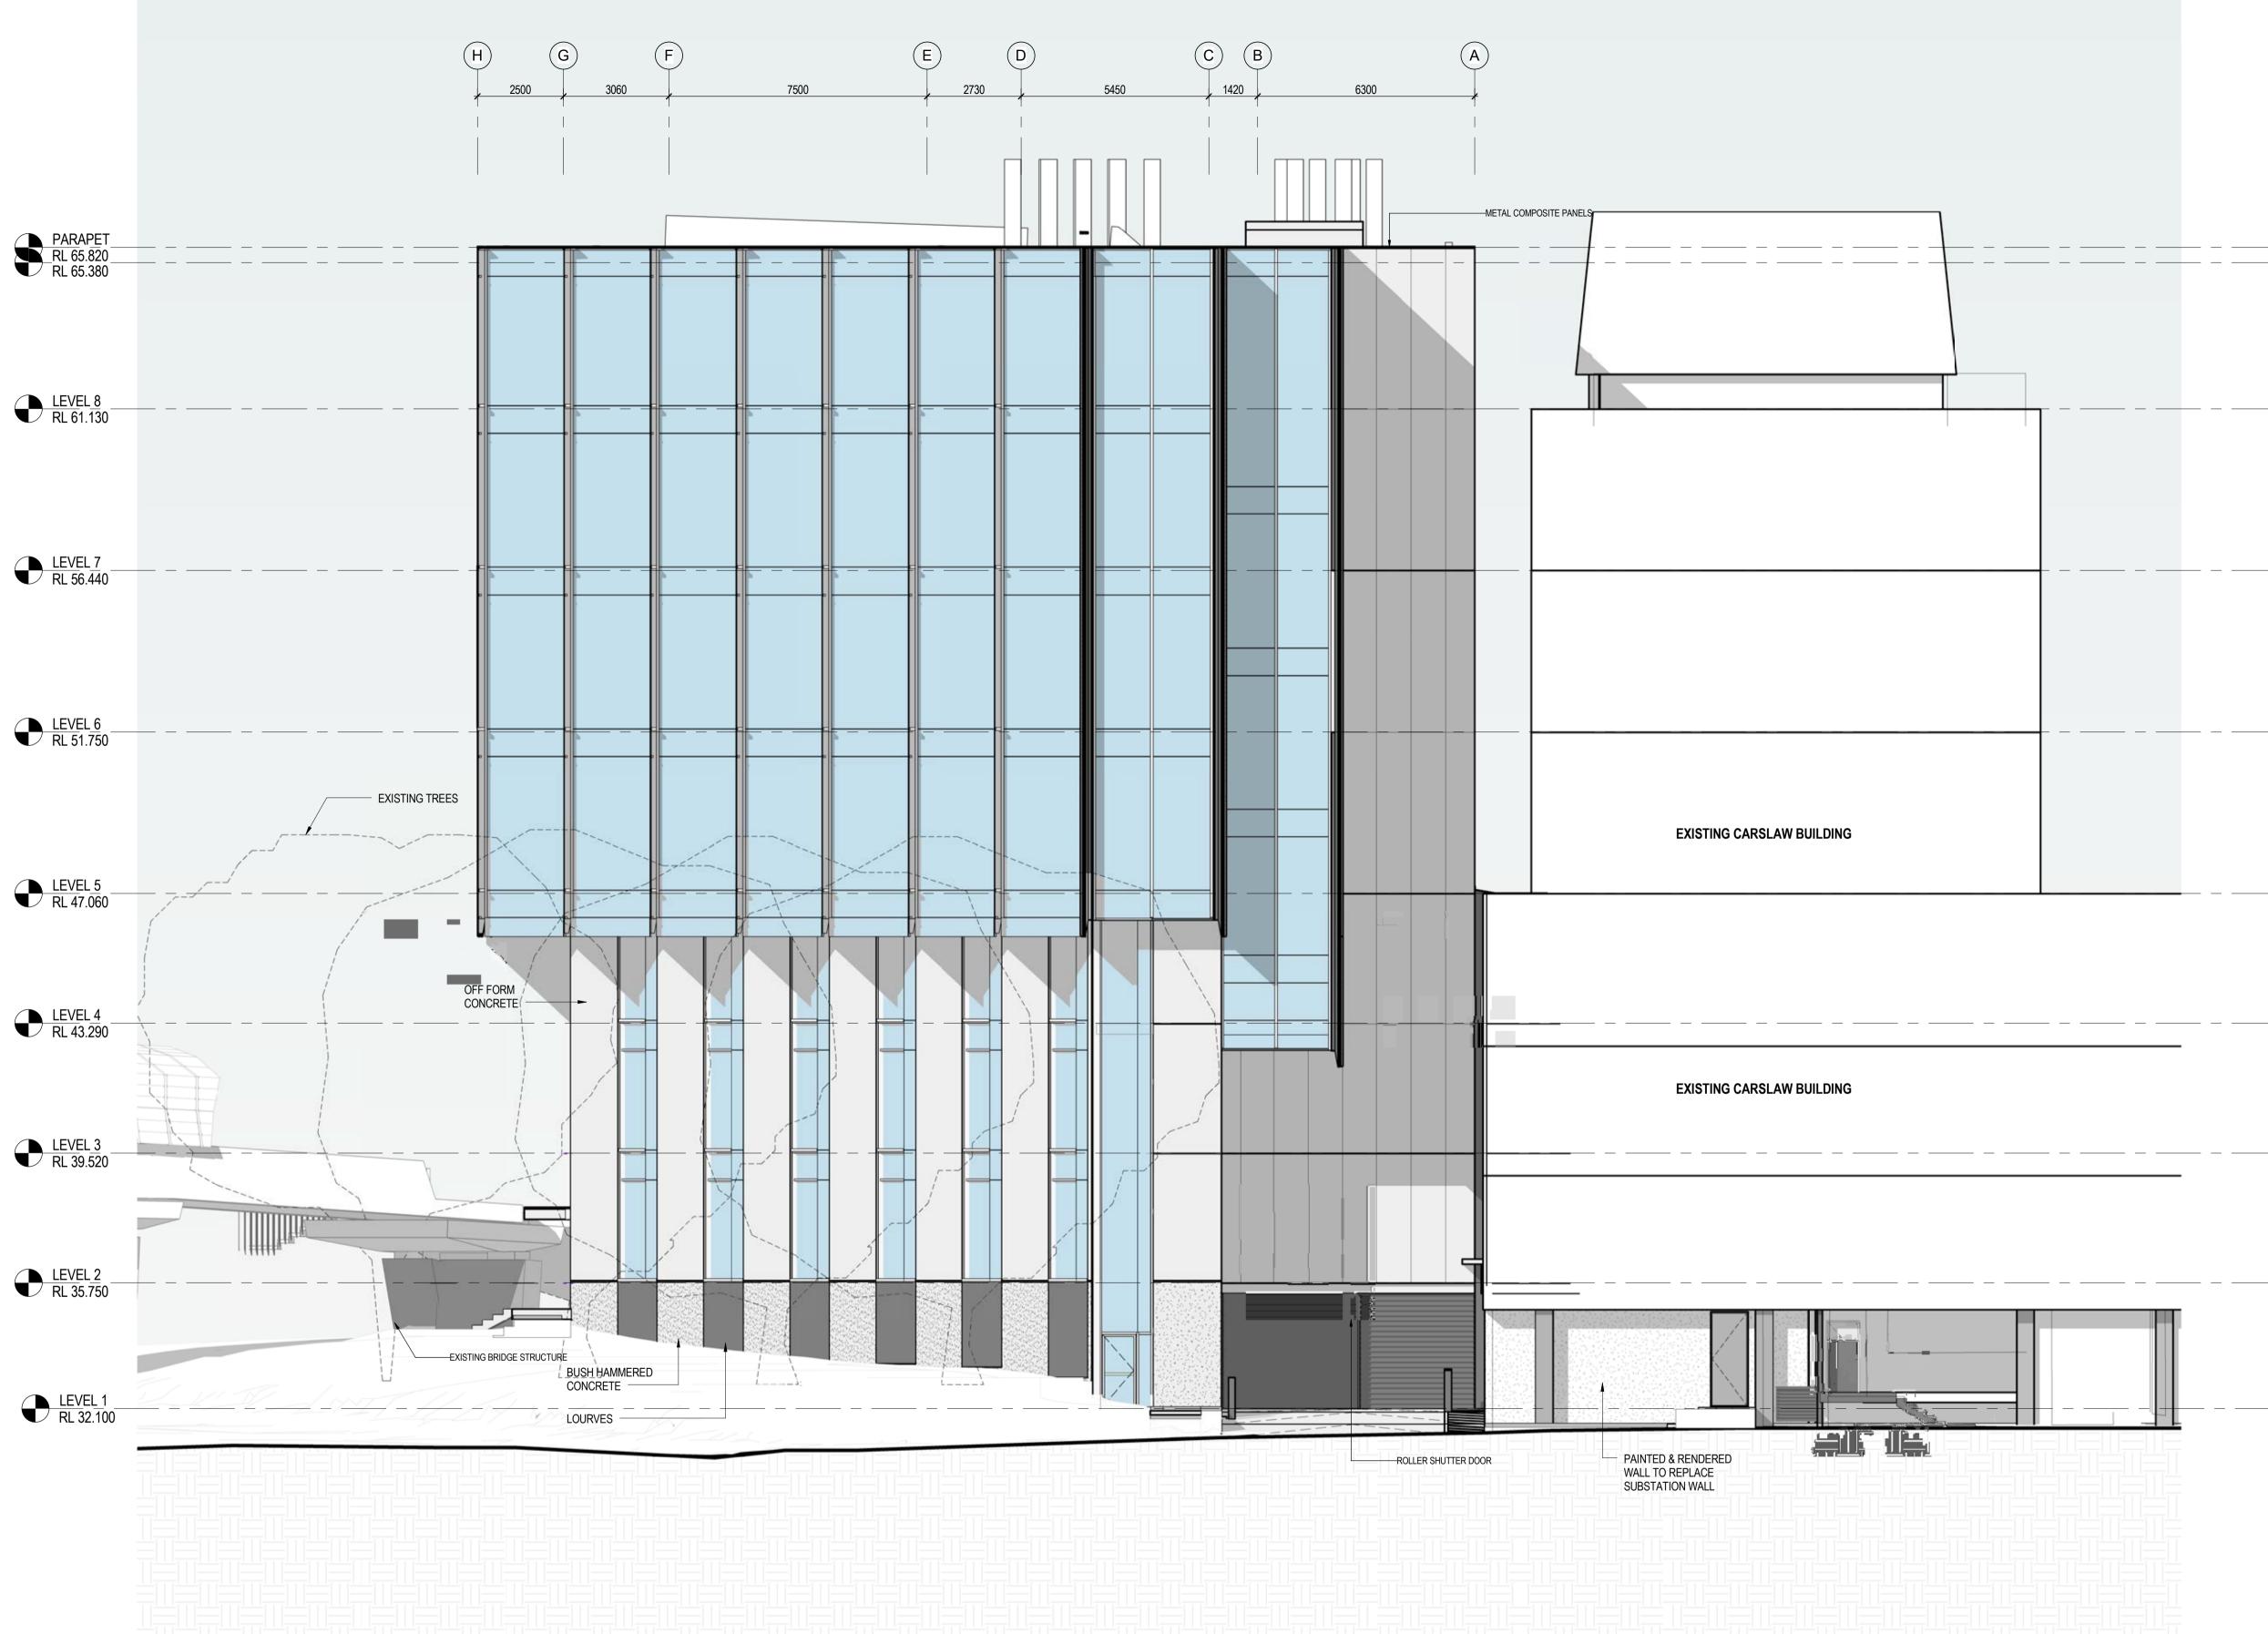

														CONSULTANT		
														Access Consultant	ESD Consultant	Mechanical Engineer
⋝														Cheung Access	JHA Consulting Engineers	JHA Consulting Engineers
AM														, v	0 0	00
.19														Code Compliance	Façade Engineer	Plumbing Engineer
45														B M + G Pty Ltd	Surface Design Consult. Pty Ltd	JHA Consulting Engineers
11:45:18 ,														Comms/Security Engineer	Fire Engineer	Structural Engineer
16/2016														JHA Consulting Engineers	Defire Pty Limited	Northrop Engineers Pty Ltd
2 6	FOR INFORMATION	MS	13.09.2016										40 44	Electrical Engineer	Landscape Architects	5 - 5 - 5 - 5 - 5 - 5 - 5 - 5 - 5 - 5 -
9 0		-		0	1m								<u>10</u> m A1		•	
is Rev	DESCRIPTION OF CHANGE	CHKD	DATE	1	1	I	I	1	1	1	1	1	I	JHA Consulting Engineers	OCULUS Pty Ltd	




HD7 Level 1, 110 Walker Street, North Sydney NSW 2060, Australia +61 2 9956 2666 | hdrricedaubney.com | hdrinc.com

ARCHITECTS



PROJECT LEES1 BUILDING (F07) THE UNIVERSITY OF SYDNEY CITY ROAD, CAMPERDOWN

DRAWING TITLE EAST ELEVATION	SCALE 1 : 100 @ A1	CHECKED MS	DATE 13.09.2016			
	CONTRACT NUMBER	DRAWING NUMBER	ISSUE			
	TBC	HDR-AR-DWG-DA14	G			
	THIS DOCUMENT IS THE COPYRIGHT OF THE RICE DAUBNEY GROUP (NSW) PTY. LTD. ALL INFORMATION ILLUSTRATED ON THIS DOCUMENT IS TO BE CHECKED AND VERIFIED ON SITE. IN THE EVENT OF DISCREPANCIES REFER TO ARCHITECT PRIOR TO COMMENCEMENT OF THE WORK. DO NOT SCALE DRAWINGS MANUALLY OR ELECTRONICALLY.					

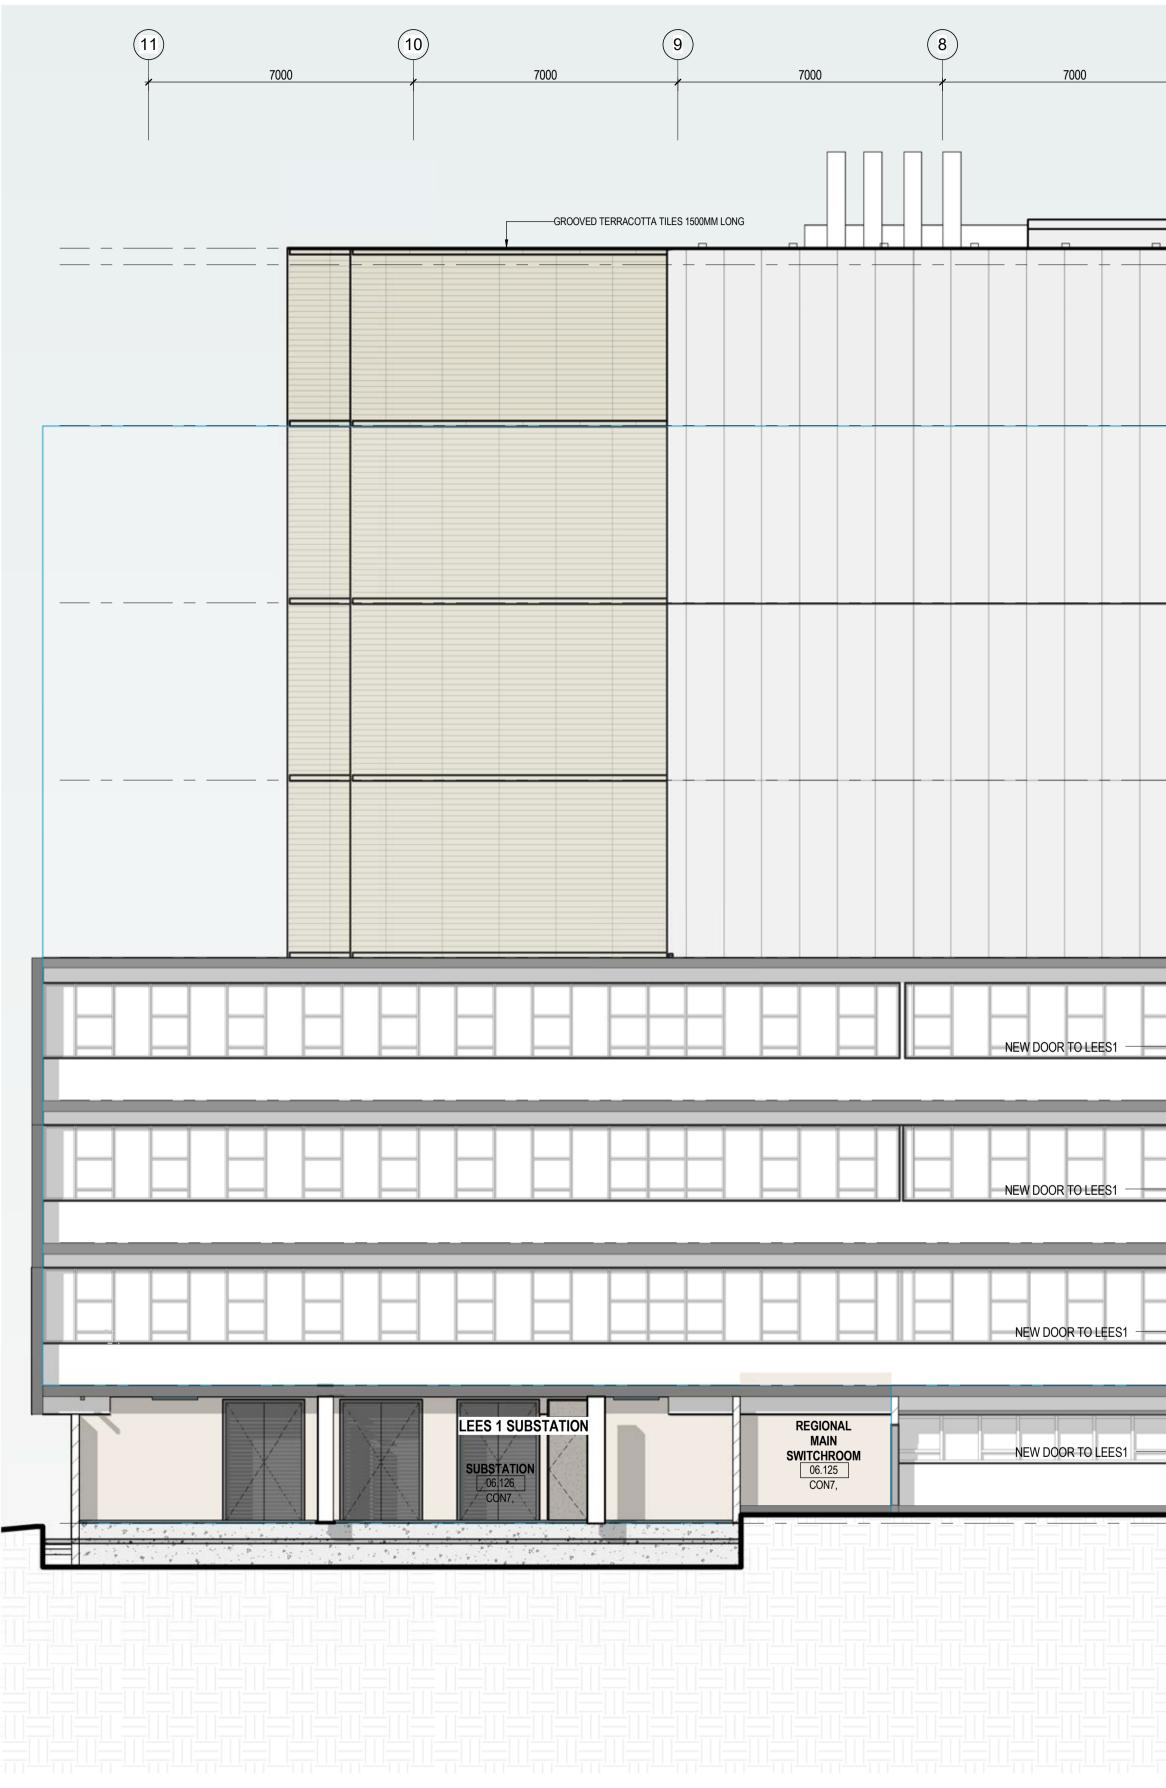

											CONSULTANT		
×											Access Consultant Cheung Access	ESD Consultant JHA Consulting Engineers	Mechanical Engineer JHA Consulting Engineers
4:28 PI											Code Compliance B M + G Pty Ltd	Façade Engineer Surface Design Consult. Pty Ltd	Plumbing Engineer JHA Consulting Engineers
016 4:3											Comms/Security Engineer JHA Consulting Engineers	Fire Engineer Defire Pty Limited	Structural Engineer Northrop Engineers Pty Ltd
5/20	G	FOR INFORMATION	MS	13.09.2016	0 1m				10m	A1	Electrical Engineer	Landscape Architects	
9/1	REV	DESCRIPTION OF CHANGE	CHKD	DATE	T 1			1			JHA Consulting Engineers	OCULUS Pty Ltd	

7	6	5	7000	4	7000	3	7000	2	7000	1 X 3500	
									GR	COOVED TERRACOTTA TILES 1500MM LONG	PARAPET RL 65.820 RL 65.380
											LEVEL 8 RL 61.130
											LEVEL 7 RL 56.440
											LEVEL 6 RL 51.750
	EXISTING CARSLAW BUILDING										LEVEL 5 RL 47.060
	EXISTING CARSLAW BUILDING										LEVEL 4 RL 43.290
	EXISTING CARSLAW BUILDING						EW OPENING TO CARSLAW				LEVEL 3 RL 39.520
	EXISTING CARSLAW BUILDING				XISTING DOOR						LEVEL 1 RL 32.100
											RL 32.100








PROJECT LEES1 BUILDING (F07) THE UNIVERSITY OF SYDNEY CITY ROAD, CAMPERDOWN


DRAWING TITLE	SCALE	CHECKED	DATE			
NORTH ELEVATION	1 : 100 @ A1	MS	13.09.2016			
	CONTRACT NUMBER	DRAWING NUMBER	ISSUE			
	TBC	HDR-AR-DWG-DA15	G			
	THIS DOCUMENT IS THE COPYRIGHT OF THE RICE DAUBNEY GROUP (NSW) PTY. LTD. ALL INFORMATION ILLUSTRATED ON THIS DOCUMENT IS TO BE CHECKED AND VERIFIED ON SITE. IN THE EVENT OF DISCREPANCIES REFER TO ARCHITECT PRIOR TO COMMENCEMENT OF THE WORK. DO NOT SCALE DRAWINGS MANUALLY OR ELECTRONICALLY.					

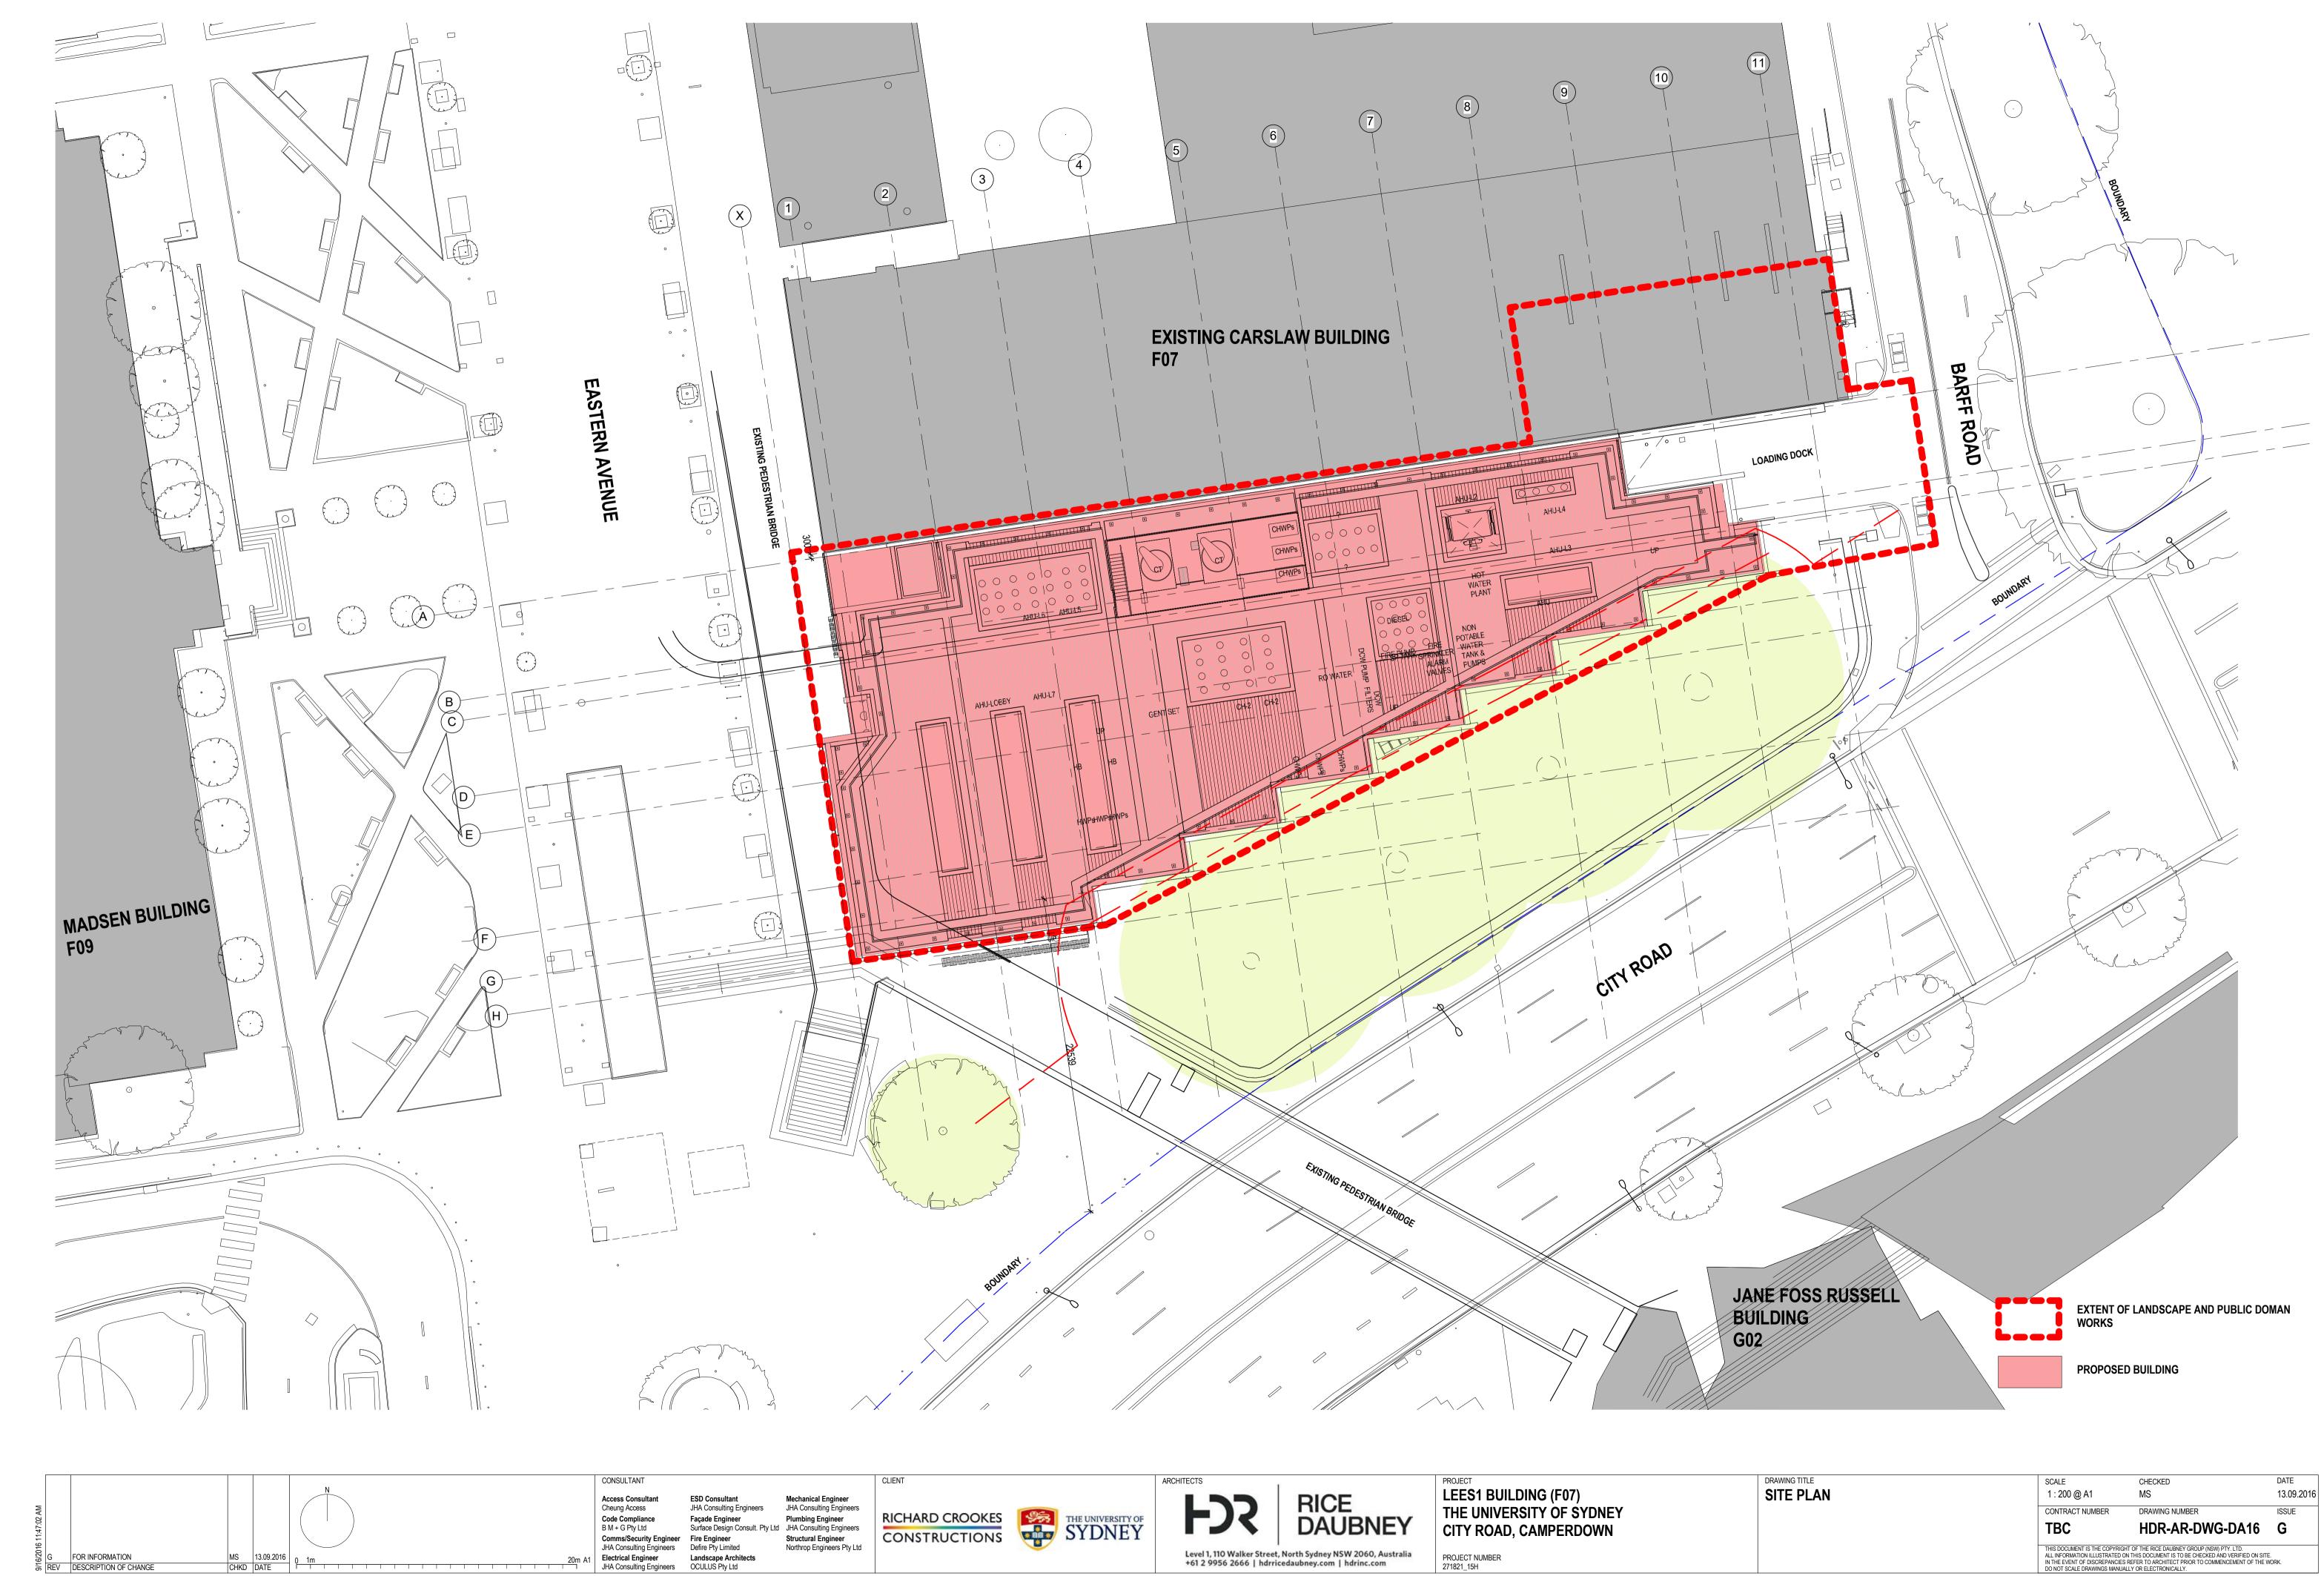







C:\rvt\2016\15H LEES 1_BASE BUILDING_sameh.hosny@hdrinc.com.rvt

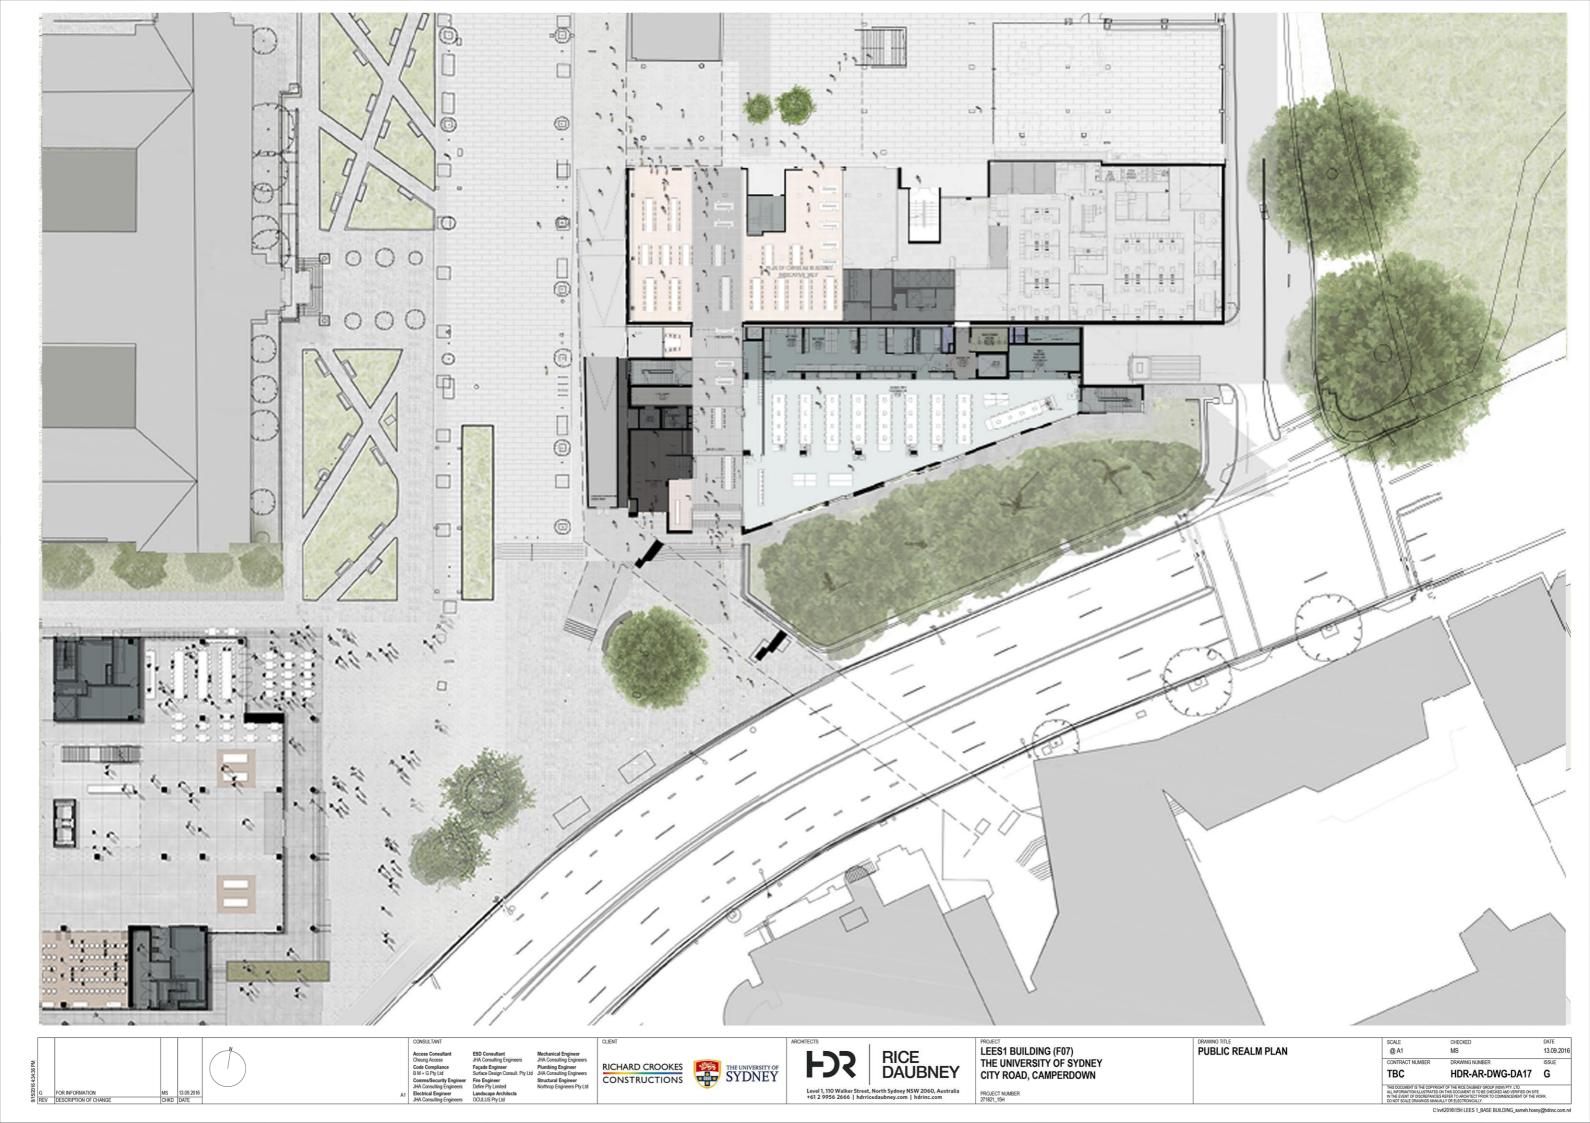


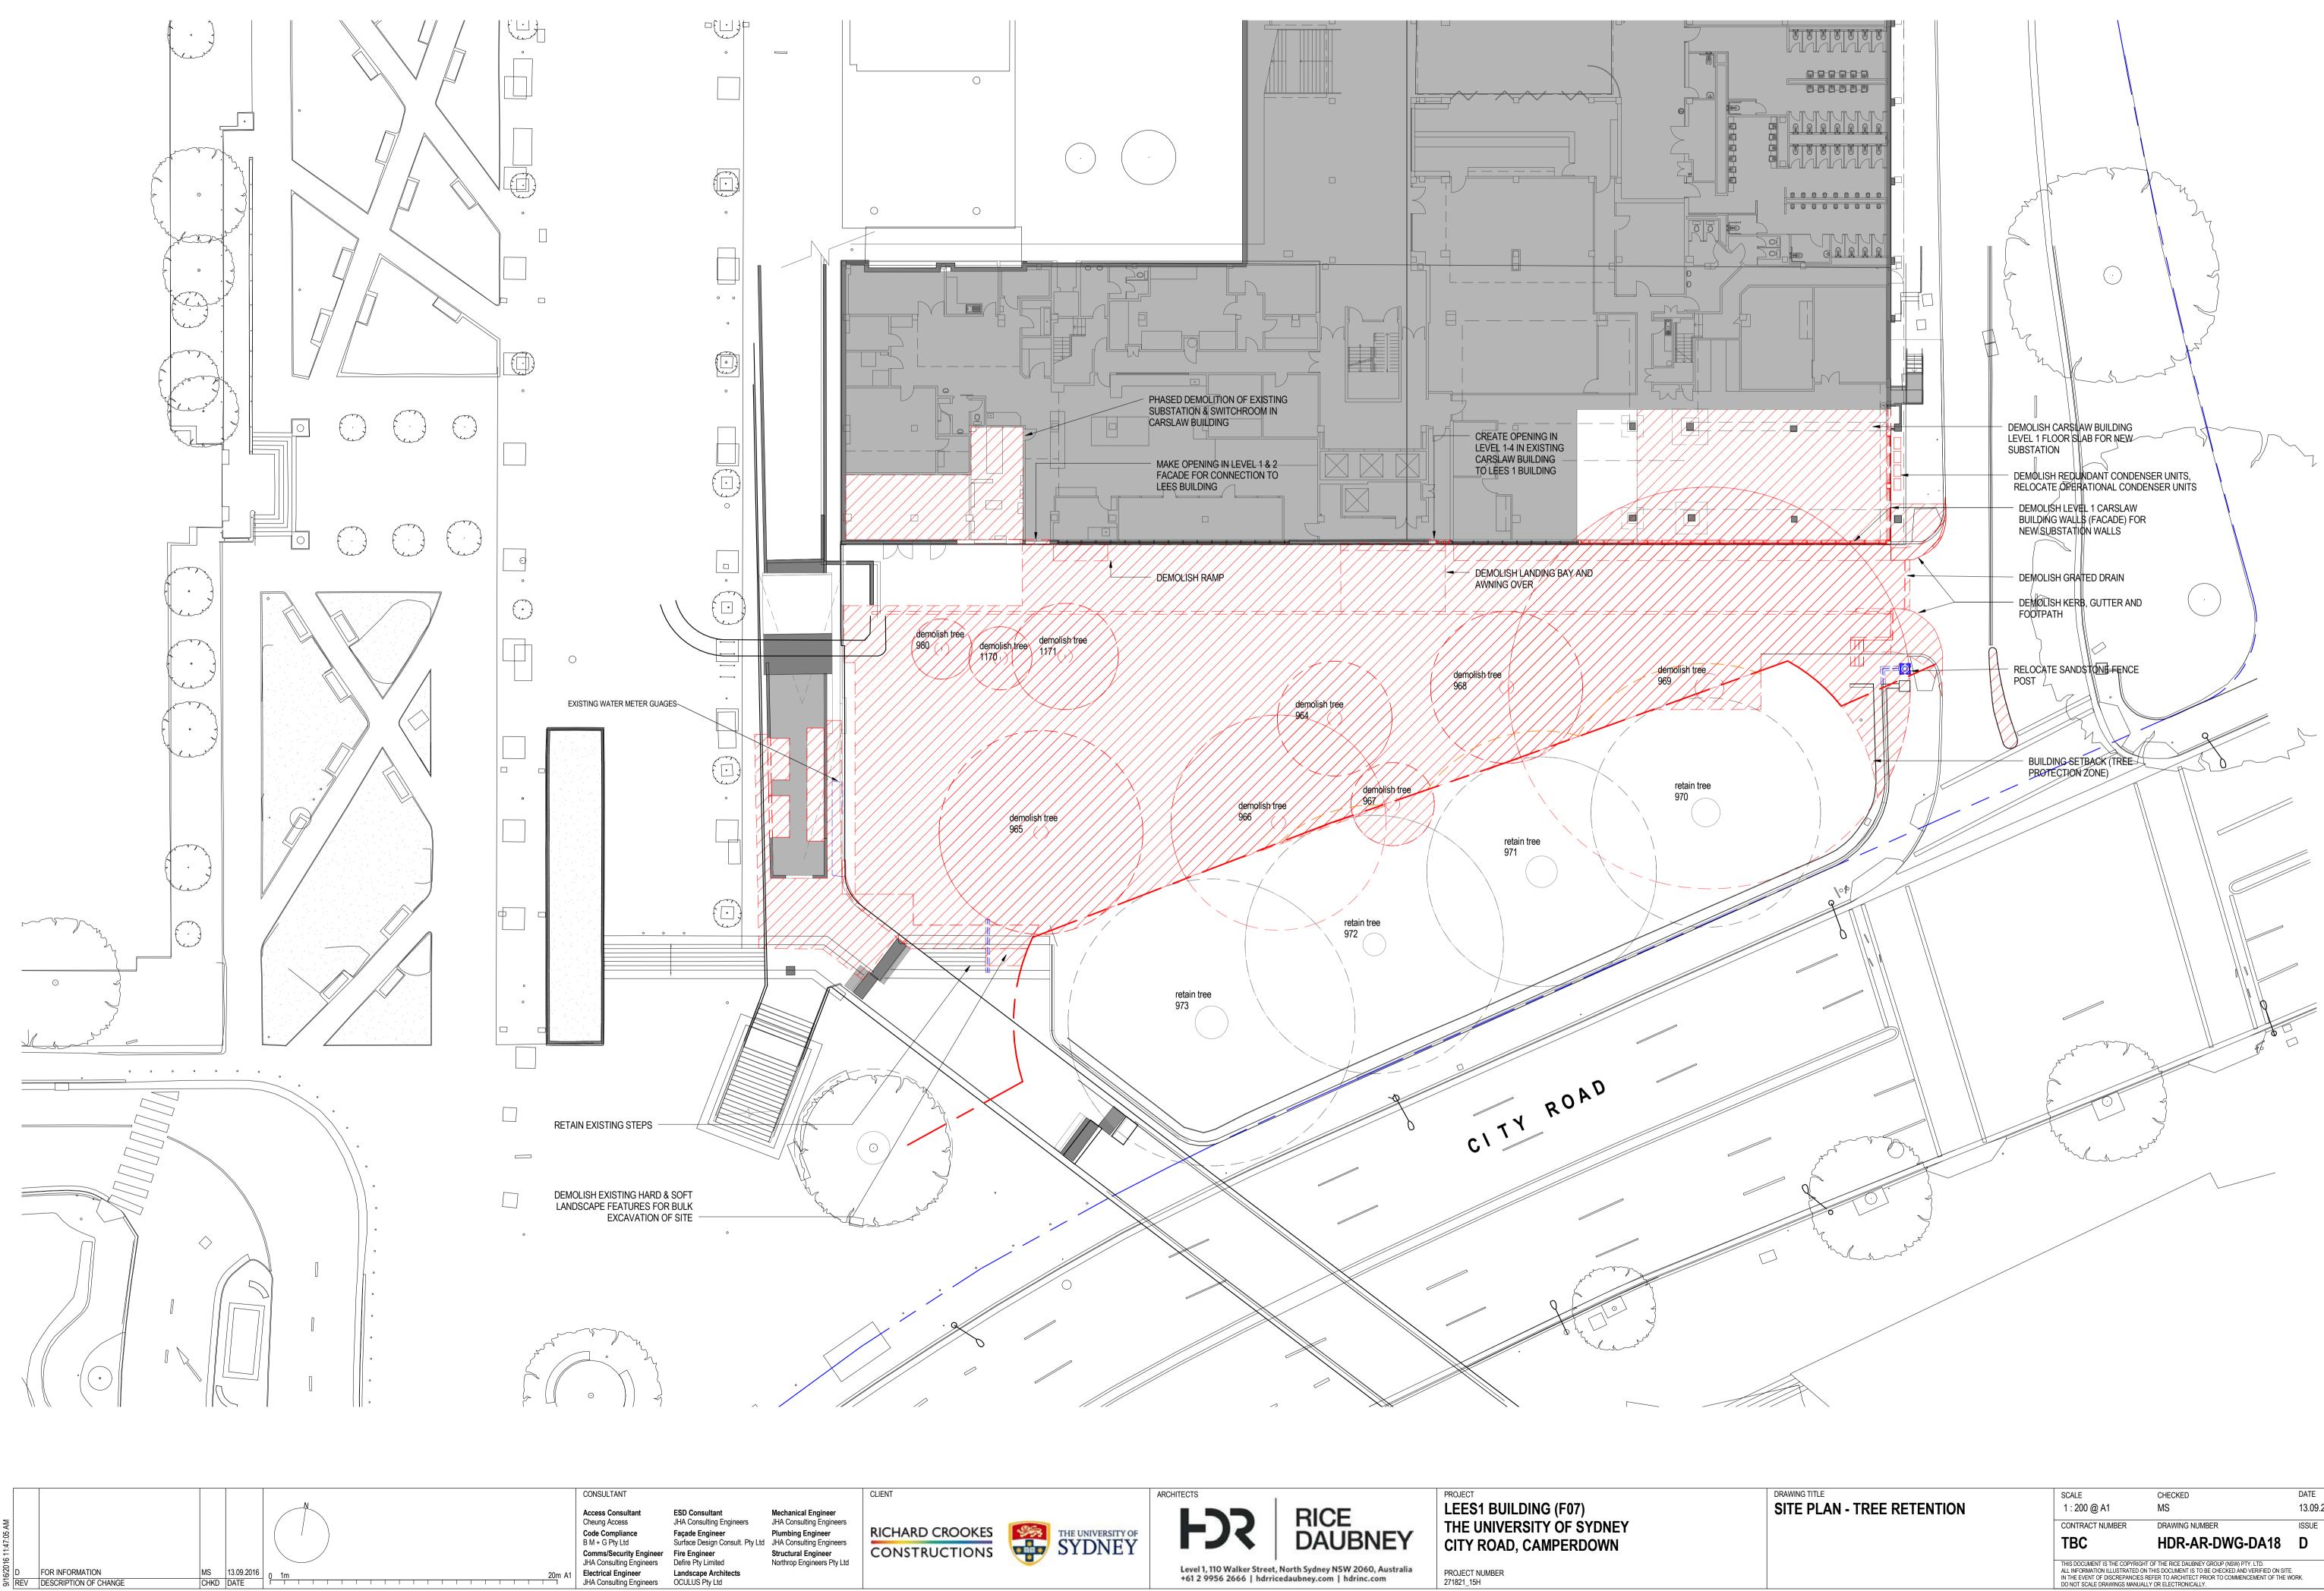

NG TITLE	SCALE	CHECKED	DATE			
E PLAN - TREE RETENTION	1 : 200 @ A1	MS	13.09.2016			
	CONTRACT NUMBER	DRAWING NUMBER	ISSUE			
	TBC	HDR-AR-DWG-DA18	D			
	THIS DOCUMENT IS THE COPYRIGHT OF THE RICE DAUBNEY GROUP (NSW) PTY. LTD. ALL INFORMATION ILLUSTRATED ON THIS DOCUMENT IS TO BE CHECKED AND VERIFIED ON SITE. IN THE EVENT OF DISCREPANCIES REFER TO ARCHITECT PRIOR TO COMMENCEMENT OF THE WORK. DO NOT SCALE DRAWINGS MANUALLY OR ELECTRONICALLY.					

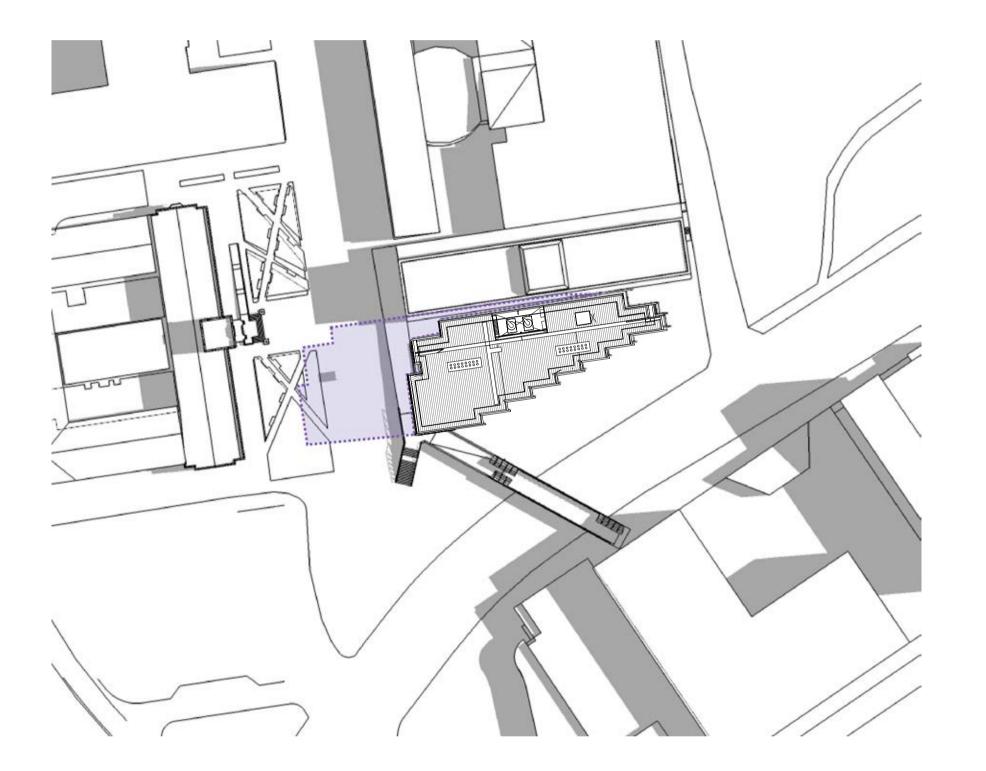

9AM-22 DECEMBER

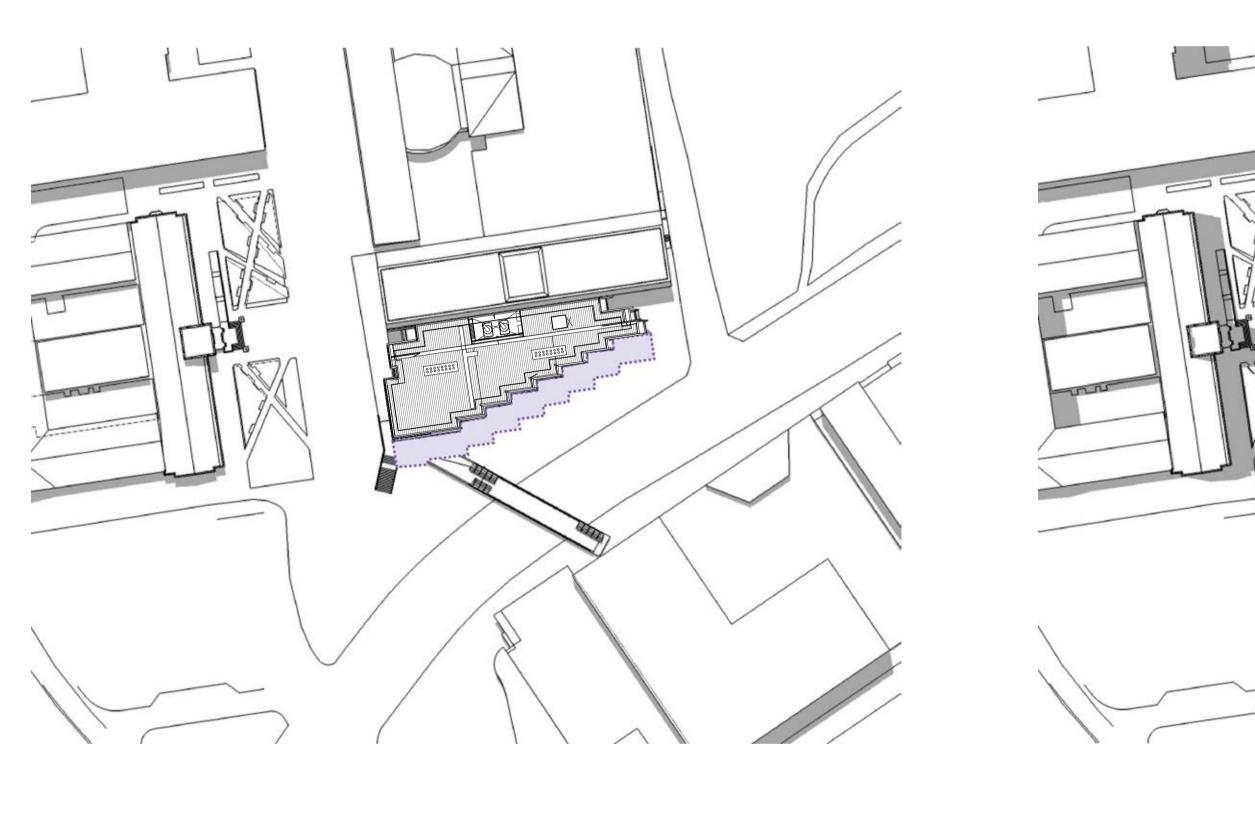

12PM- 22 DECEMBER

2PM- 22 DECEMBER

CLIENT






ARCHITECTS



PROJECT LEES1 BUILDING (F07) THE UNIVERSITY OF SYDNEY CITY ROAD, CAMPERDOWN

PROJECT NUMBER 271821_15H

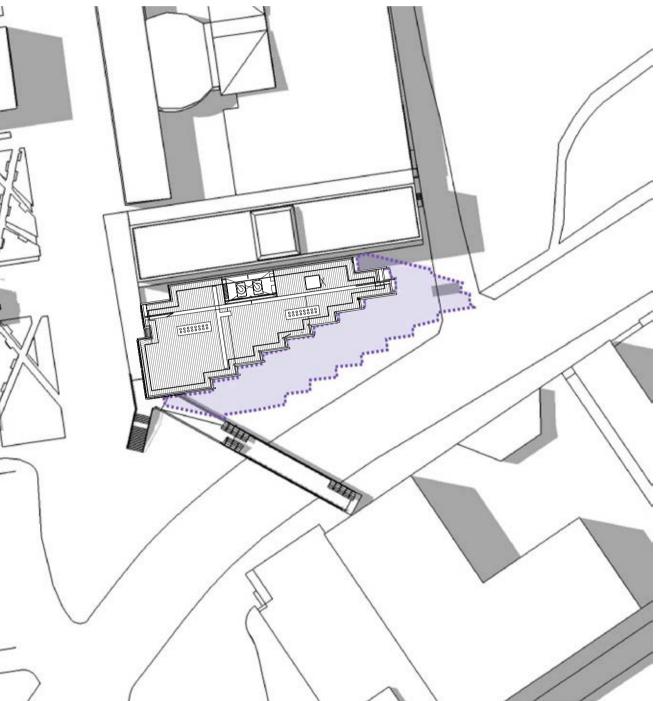


DRAWING TITLE
SHADOW DIAGRAMS - SUMMER
SOLSTICE

SCALE 1 : 1000 @ A1 CONTRACT NUMBER TBC

CHECKED AM DRAWING NUMBER


FOR INFORMATION DATE 15.08.2016 ISSUE HDR-AR-DWG-DA19 C

THIS DOCUMENT IS THE COPYRIGHT OF THE RICE DAUBNEY GROUP (NSW) PTY. LTD. ALL INFORMATION ILLUSTRATED ON THIS DOCUMENT IS TO BE CHECKED AND VERIFIED ON SITE. IN THE EVENT OF DISCREPANCIES REFER TO ARCHITECT PRIOR TO COMMENCEMENT OF THE WORK. DO NOT SCALE DRAWINGS MANUALLY OR ELECTRONICALLY. C:\rvt\2016\15H LEES 1_BASE BUILDING_chloe.zheng@hdrinc.com.rvt

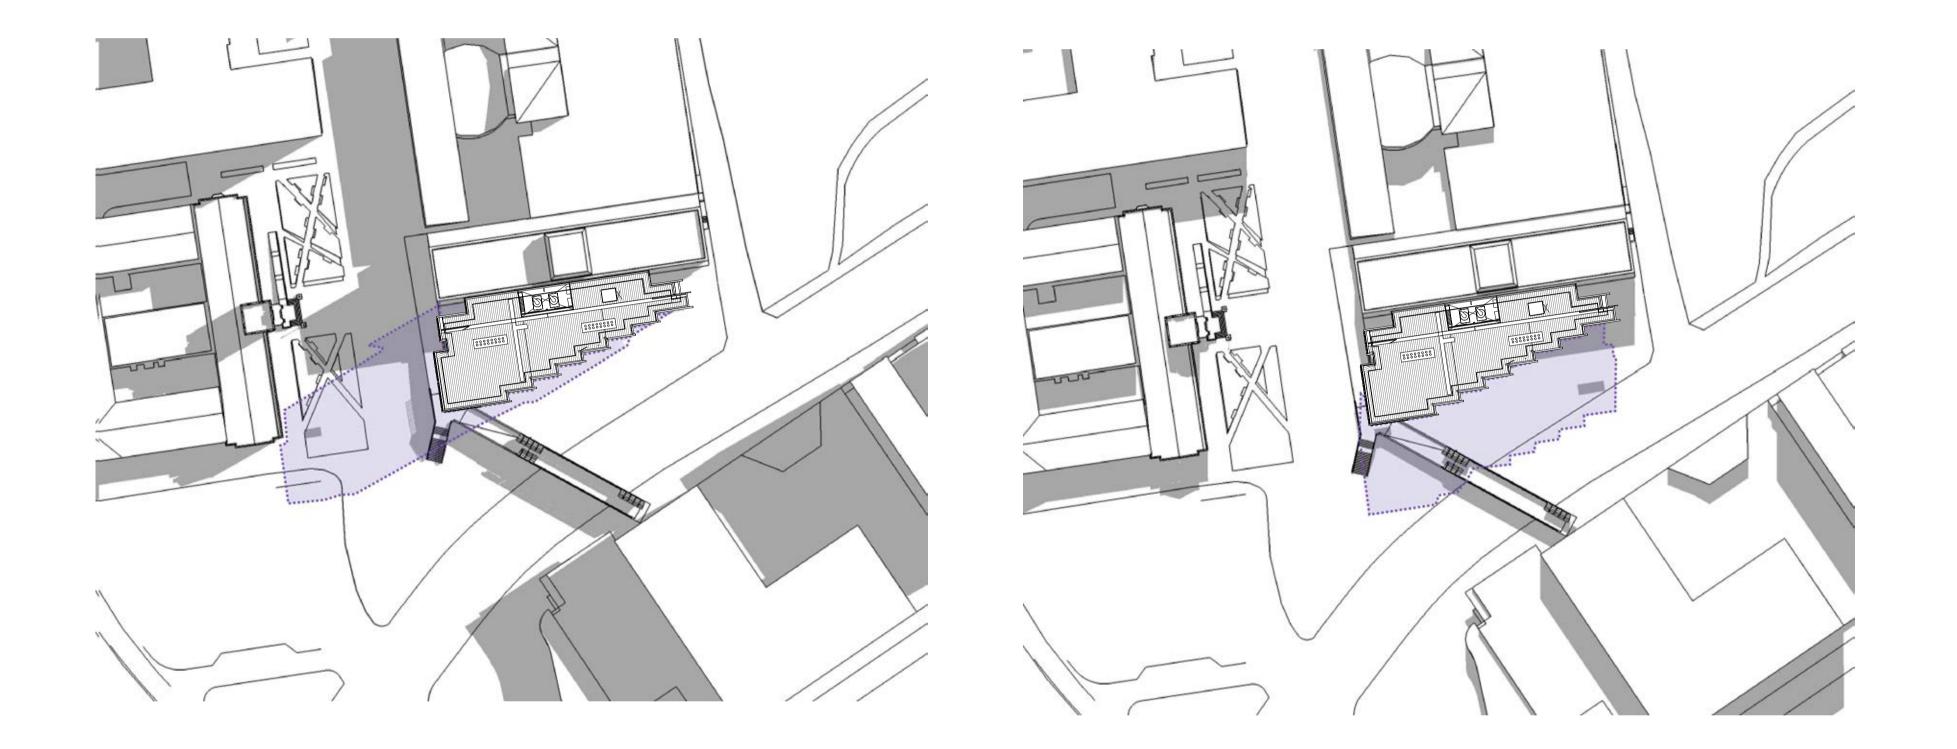

9AM- 21 MARCH

			KEY PLAN	CONSULTANT	CLIEN
8/15/2016 5:00:32 PM AB 9 0 AB	FOR INFORMATION ISSUED FOR DA ISSUED FOR DA DESCRIPTION OF CHANGE	AM 15.08.20 GG 17.05.20 AM 14.04.20 CHKD DATE	6	5m A1	RIC

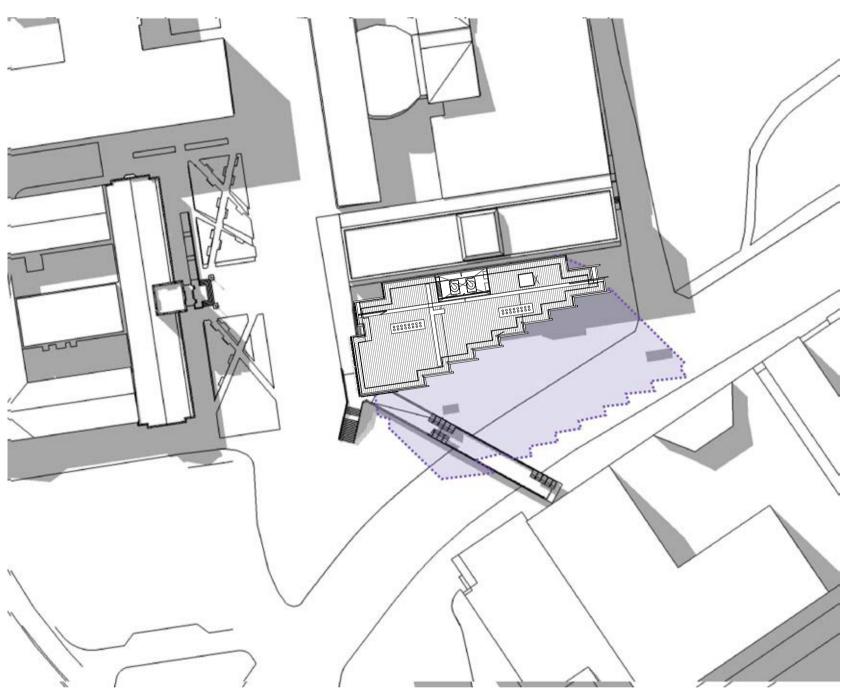

12PM- 21 MARCH

2PM-21 MARCH

LIENT





ARCHITECTS



Level 1, 110 Walker Street, North Sydney NSW 2060, Australia +61 2 9956 2666 | hdrricedaubney.com | hdrinc.com

PROJECT LEES1 BUILDING (F07) THE UNIVERSITY OF SYDNEY CITY ROAD, CAMPERDOWN

PROJECT NUMBER 271821_15H

DRAWING TITLE SHADOW DIAGRAMS - AUTUMN EQUINOX


SCALE 1 : 1000 @ A1 CONTRACT NUMBER TBC

CHECKED AM DRAWING NUMBER


FOR INFORMATION DATE 15.08.2016 ISSUE HDR-AR-DWG-DA20 C

THIS DOCUMENT IS THE COPYRIGHT OF THE RICE DAUBNEY GROUP (NSW) PTY. LTD. ALL INFORMATION ILLUSTRATED ON THIS DOCUMENT IS TO BE CHECKED AND VERIFIED ON SITE. IN THE EVENT OF DISCREPANCIES REFER TO ARCHITECT PRIOR TO COMMENCEMENT OF THE WORK. DO NOT SCALE DRAWINGS MANUALLY OR ELECTRONICALLY.


C:\rvt\2016\15H LEES 1_BASE BUILDING_chloe.zheng@hdrinc.com.rvt

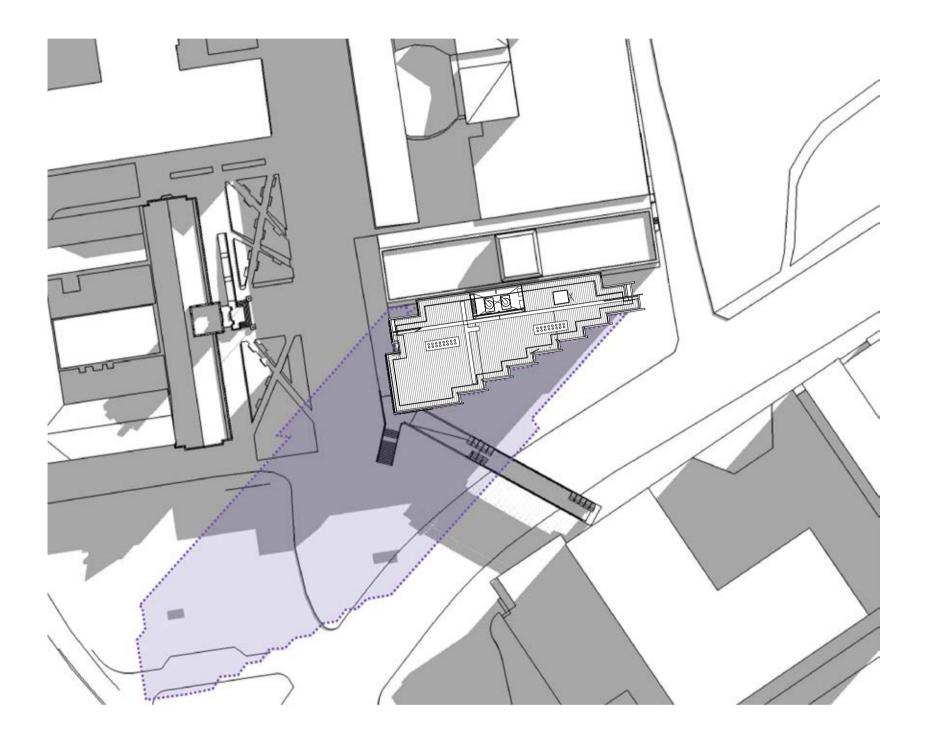

9AM- 21 JUNE

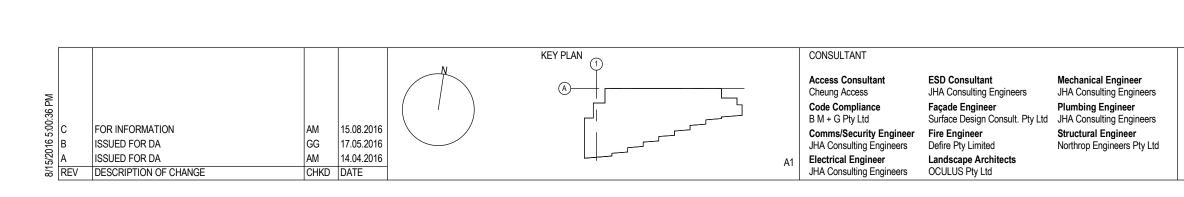



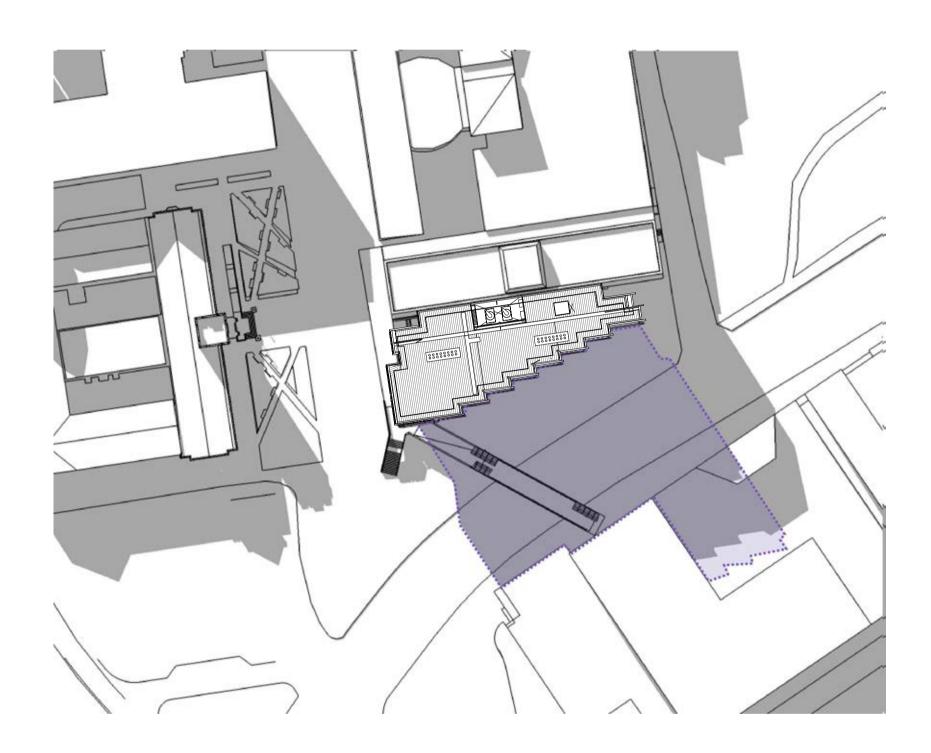

12PM- 21 JUNE

2PM- 21 JUNE

CLIENT





ARCHITECTS



Level 1, 110 Walker Street, North Sydney NSW 2060, Australia +61 2 9956 2666 | hdrricedaubney.com | hdrinc.com

PROJECT LEES1 BUILDING (F07) THE UNIVERSITY OF SYDNEY CITY ROAD, CAMPERDOWN

PROJECT NUMBER 271821_15H

DRAWING TITLE	
SHADOW DIAGRAMS - WINTER	
SOLSTICE	

SCALE 1 : 1000 @ A1 CONTRACT NUMBER TBC

CHECKED AM DRAWING NUMBER

FOR INFORMATION DATE 15.08.2016 ISSUE HDR-AR-DWG-DA21 C

THIS DOCUMENT IS THE COPYRIGHT OF THE RICE DAUBNEY GROUP (NSW) PTY. LTD. ALL INFORMATION ILLUSTRATED ON THIS DOCUMENT IS TO BE CHECKED AND VERIFIED ON SITE. IN THE EVENT OF DISCREPANCIES REFER TO ARCHITECT PRIOR TO COMMENCEMENT OF THE WORK. DO NOT SCALE DRAWINGS MANUALLY OR ELECTRONICALLY. C:\rvt\2016\15H LEES 1_BASE BUILDING_chloe.zheng@hdrinc.com.rvt